
 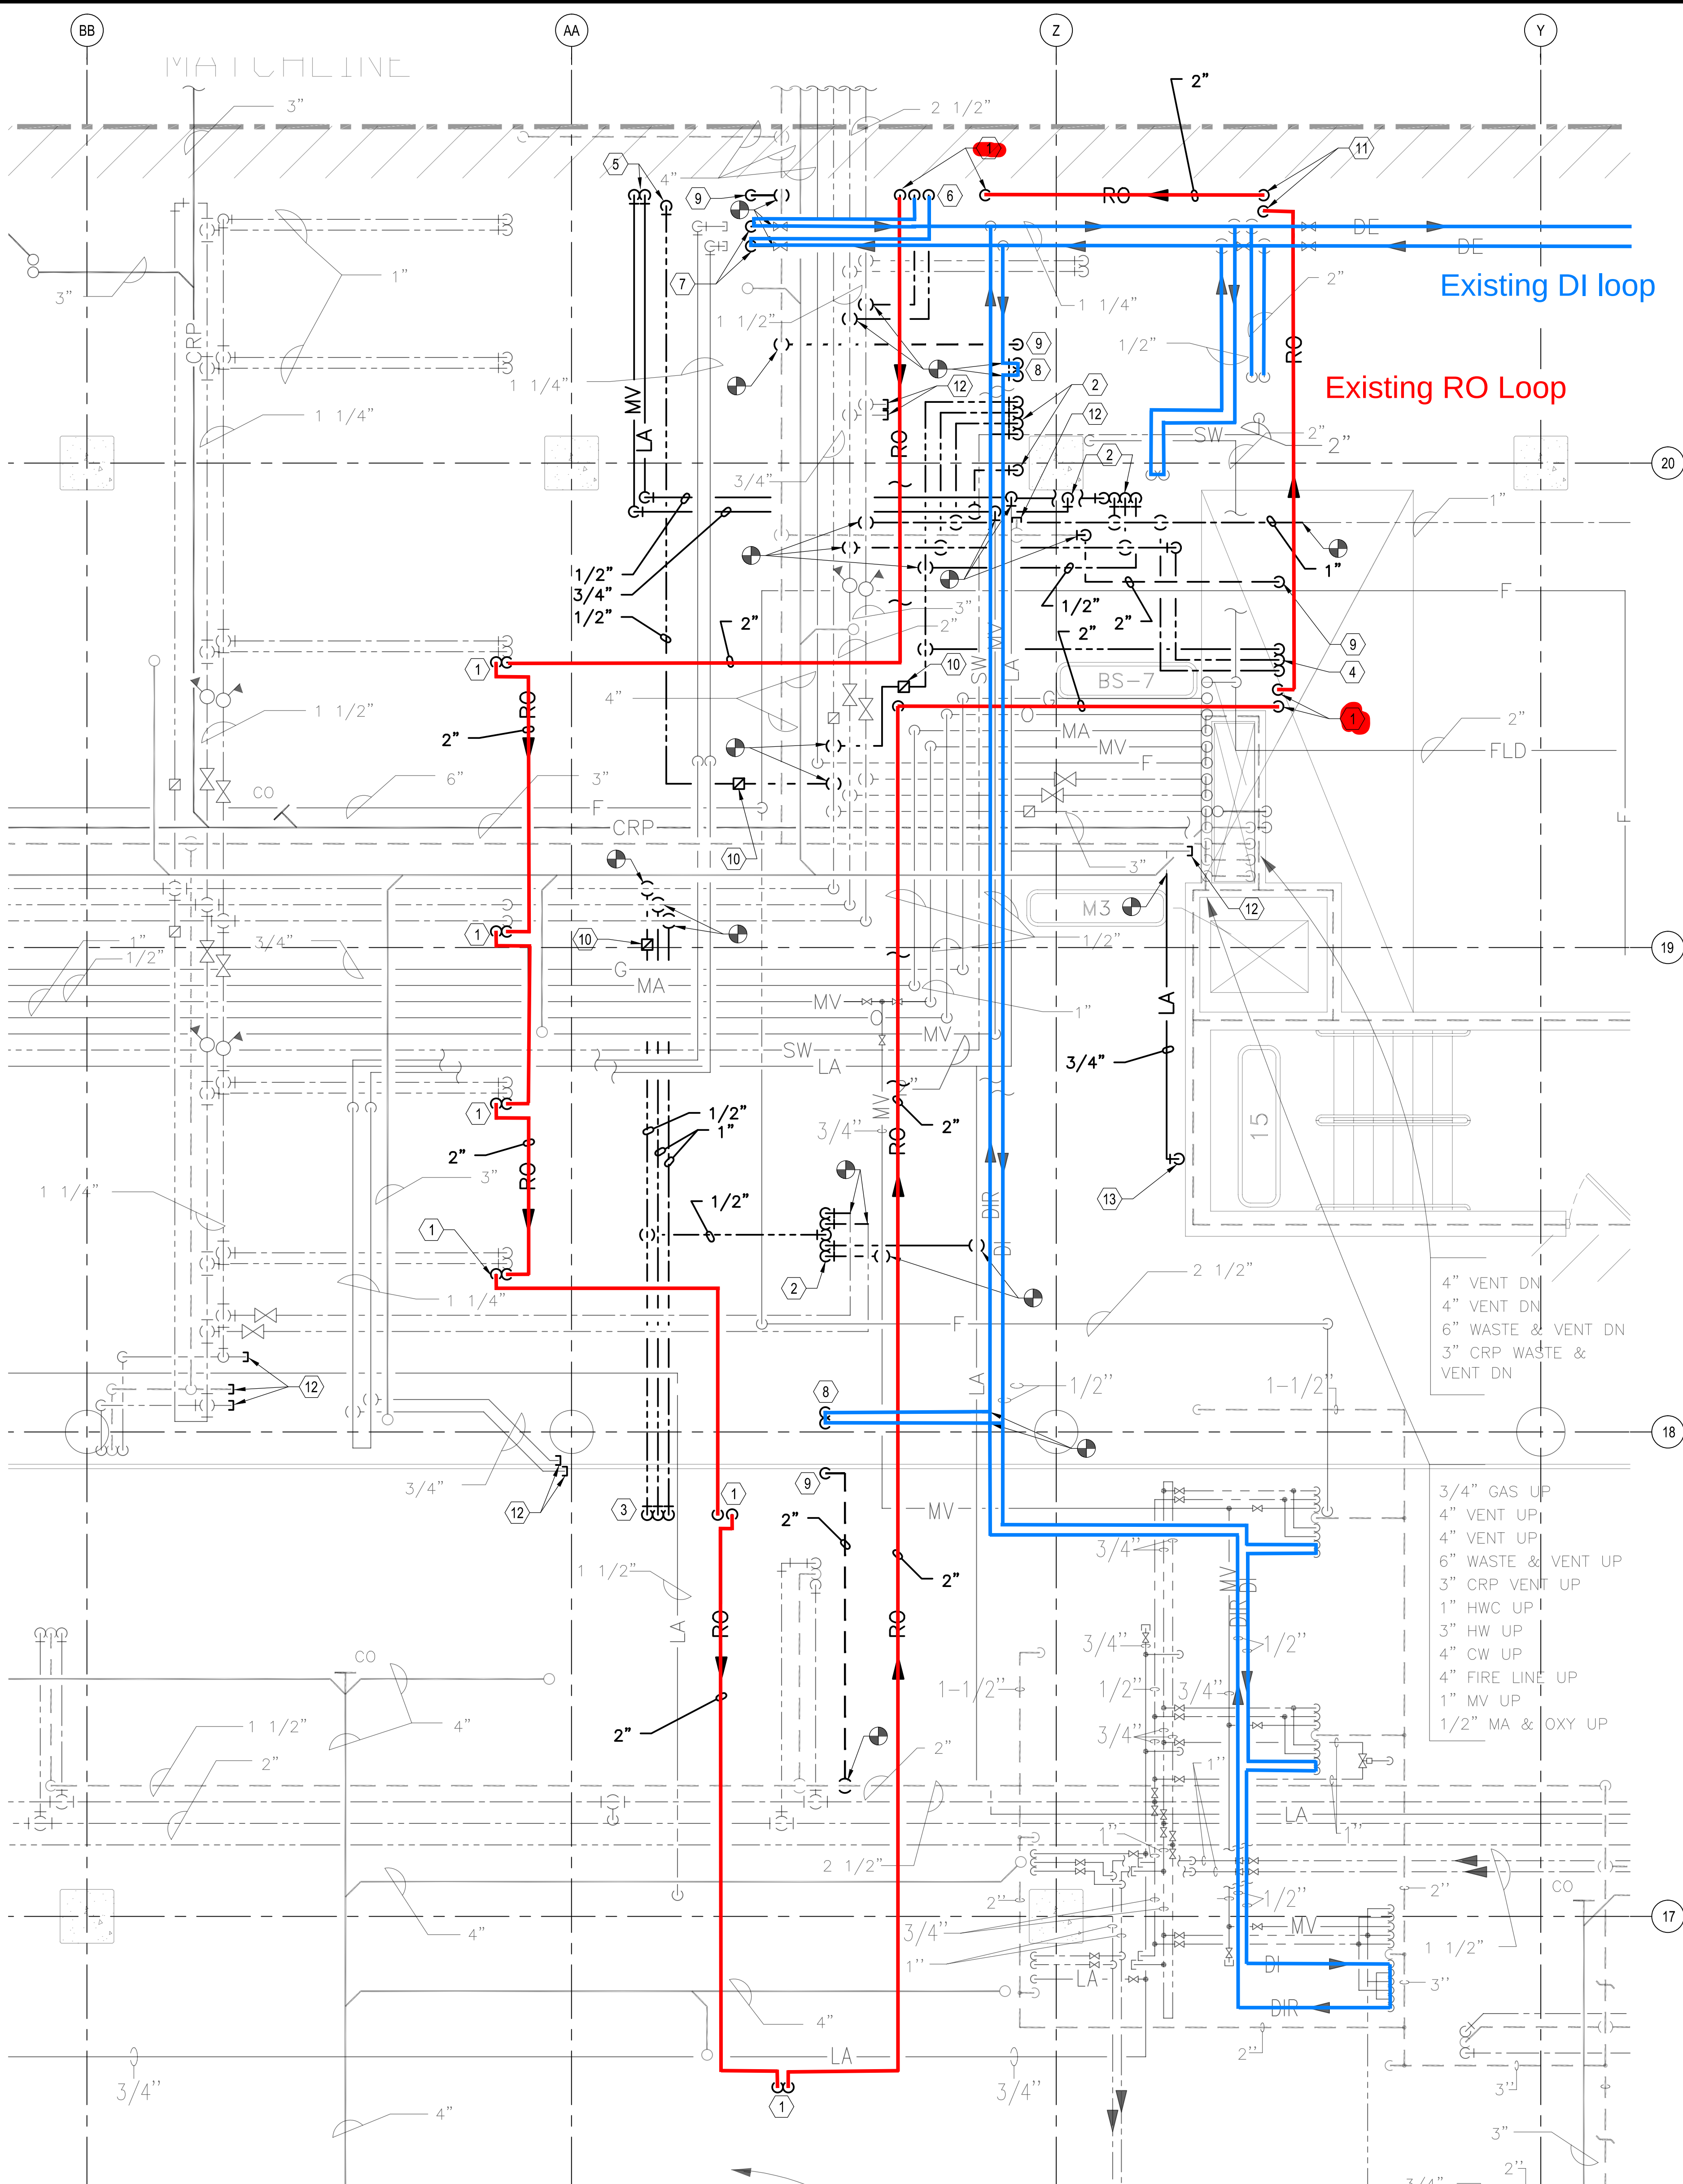


This page highlights the existing RO (Red) and DI (Blue) piping. No other information on this plan is relevant to this project.



Drawing-1 existing Di and RO pipes

1 BASEMENT INTERSTITIAL FLOOR PLAN - ABOVE GROUND PIPING

GENERAL NOTES: GENERAL CONTRACTOR AND/OR ALL SUBCONTRACTORS SHALL FIELD VERIFY ALL DIMENSIONS SHOWN ON THESE PLANS AND SHALL BE RESPONSIBLE FOR VARIATIONS BETWEEN PLAN DIMENSIONS AND ACTUAL FIELD DIMENSIONS. WHERE VARIATIONS ARE FOUND TO OCCUR, THE CONTRACTOR SHALL NOTIFY THE PROJECT ENGINEER IN WRITING PRIOR TO PROCEEDING WITH CONSTRUCTION; NO ADJUSTMENT TO THE WORK WILL BE MADE WITHOUT THE PRIOR APPROVAL OF THE PROJECT ENGINEER. GENERAL CONTRACTOR SHALL BE RESPONSIBLE FOR GENERAL DEMOLITION INCLUDING REMOVAL OF WALLS, PARTITIONS, DOORS & CEILING & FLOORS, ANY AND ALL CUTTING OF CONCRETE FLOORS, WALLS OR STRUCTURE SHALL BE THE GENERAL CONTRACTOR'S RESPONSIBILITY. CORE DRILLING THROUGH FLOORS, FLOORS OR STRUCTURE FOR PIPING OR CONDUIT SHALL BE THE RESPONSIBILITY OF THE SUBCONTRACTOR BY TRADE; FIRESTOPPING OF THESE OPENING SHALL BE DONE BY THE RESPECTIVE SUBCONTRACTOR. REMOVAL OF DEBRIS RESULTING FROM CUTTING AND/OR DRILLING IS THE RESPONSIBILITY OF THE GENERAL CONTRACTOR. PATCHING AND REPAIR OF CONCRETE WALLS, FLOOR, OR STRUCTURE SHALL BE THE RESPONSIBILITY OF THE GENERAL CONTRACTOR. THIS WILL BE ACCOMPLISHED UPON COMPLETION OF THE INSTALLATION OF ANY AND ALL UTILITIES INSTALLED BY THE VARIOUS SUBCONTRACTORS.	  TRUE NORTH  PLAN NORTH 	I HEREBY CERTIFY THAT THIS PLAN, SPECIFICATION OR REPORT WAS PREPARED BY ME OR UNDER MY DIRECT SUPERVISION AND THAT I AM A DULY LICENSED PROFESSIONAL ENGINEER UNDER THE LAWS OF THE STATE OF MINNESOTA. REGISTRATION NUMBER: 8264  GEORGE ROTHENBERGER 10/06/17	Drawing Title AG PIPING PLAN BASEMENT INTERSTITIAL Approved: Division Chief  Approved: Service Director 	Project Title RO SYSTEM EXPANSION Location V.A. MEDICAL CENTER 1615 CHAMBERS DRIVE MINNEAPOLIS, MN 55417	Project No. 618-17-105 Building Number 70 DRAWING NO. 1345-P210 Dwg. 16 of 28	Office of Facilities Management  Department of Veterans Affairs
		REVISIONS: _____ DATE _____		Date 10/06/17 Checked GER Drawn MJZ		