



US DEPARTMENT OF VETERANS AFFAIRS

VA ST. LOUIS HEALTH CARE SYSTEM

JOHN COCHRAN DIVISION

FCA Replace Select Hot Water Heating Systems, JC

VA PROJECT NUMBER: 657-27-107JC

DRAWING INDEX

GENERAL


01-GI-001

TITLE SHEET

MECHANICAL

01-ME-111

MECHANICAL FLOOR PLANS

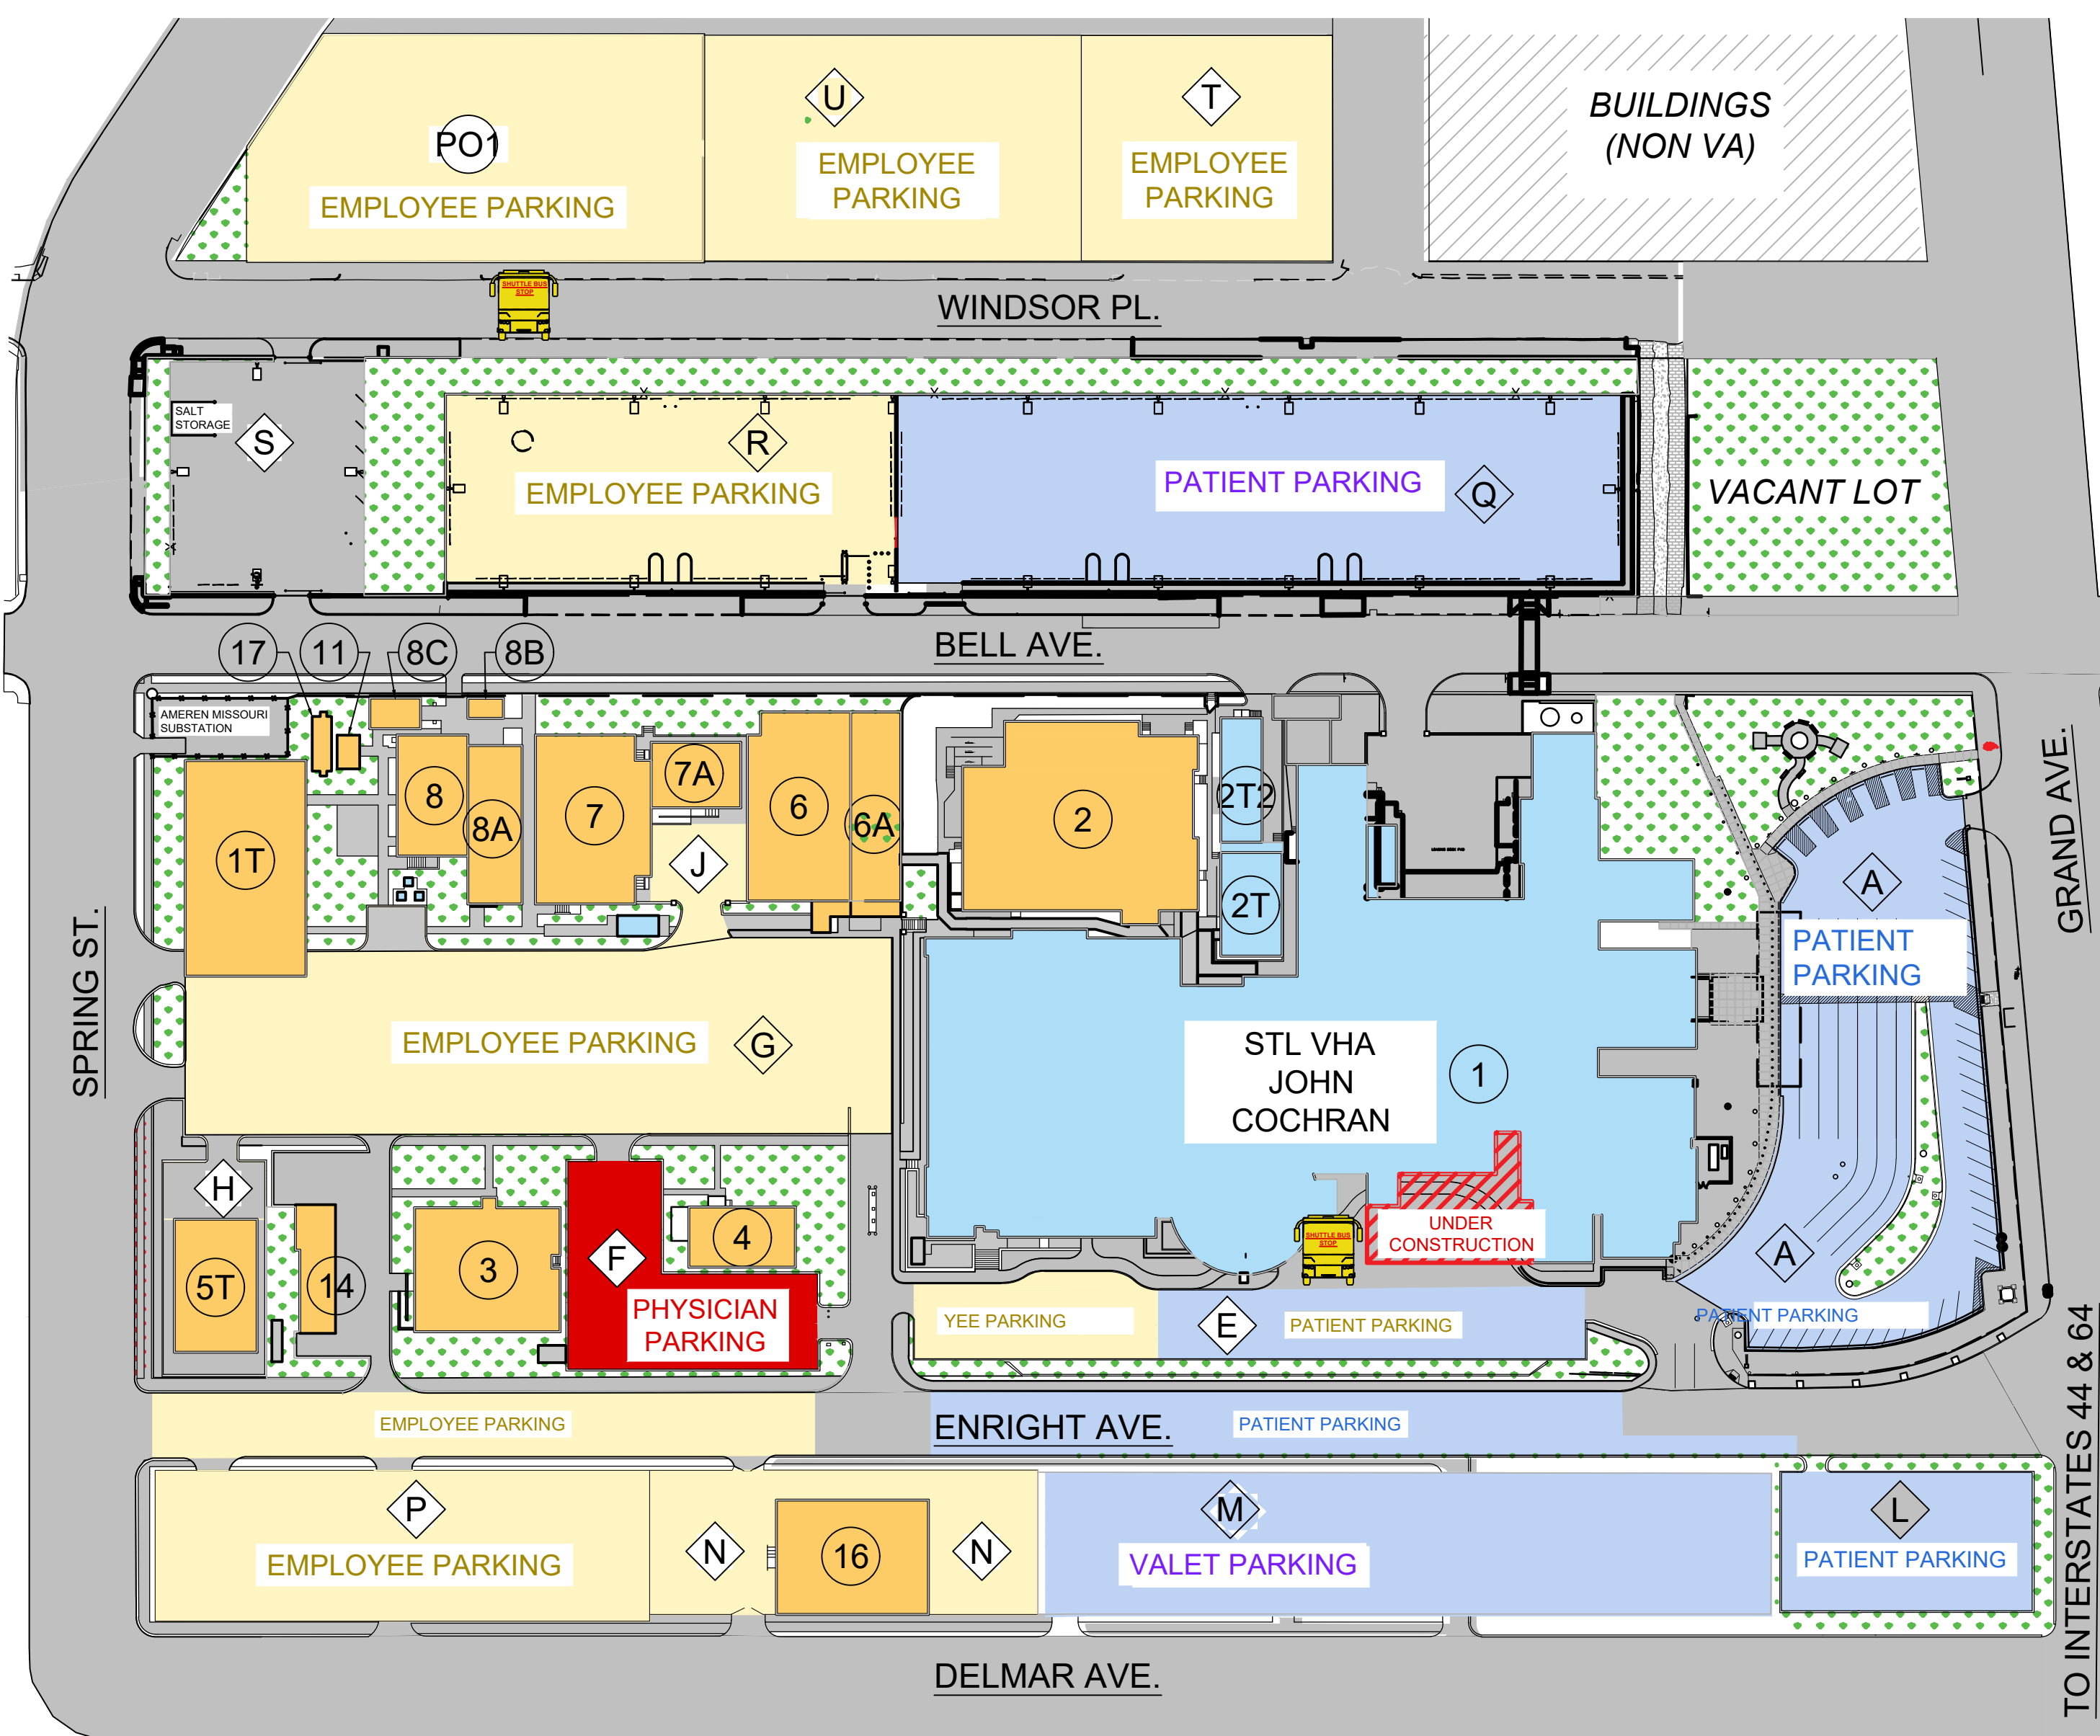

BUILDING SCHEDULE:

- 1 MAIN HOSPITAL
- 1T TENANTS
- 2 CONFERENCE, CHAPEL, LIBRARY
- 2T OATP CLINIC
- 2T2 OATP CLINIC
- 3 OIT, HTM
- 4 LOD
- 5T EMPLOYEE HEALTH
- 6 MAIL, TENANTS
- 6A IMPACT SPACE, WAREHOUSE
- 7 SAFETY
- 7A RESEARCH
- 14 GROUNDS MAINTENANCE
- 16 ENGINEERING / HBPC

BUILDING KEY:

- PATIENT BUILDING
- EMPLOYEE BUILDING
- NON-VA BUILDING




PARKING LOT SCHEDULE:

- LOT A PATIENT & VISITOR
- LOT E PATIENT & VISITOR & EMPLOYEE
- LOT F PHYSICIAN
- LOT G EMPLOYEE
- LOT H EMPLOYEE
- LOT J EMPLOYEE
- LOT K PATIENT & VISITOR
- LOT L PATIENT & VISITOR
- LOT M PATIENT/VALET
- LOT N EMPLOYEE
- LOT P EMPLOYEE
- LOT Q VALET
- LOT R EMPLOYEE
- LOT S MAINTENANCE & OPERATIONS
- LOT T EMPLOYEE
- P01 EMPLOYEE GARAGE
- ENRIGHT EAST PATIENT
- ENRIGHT WEST EMPLOYEE

PARKING KEY:

- PATIENT PARKING
- EMPLOYEE PARKING
- PAVED ROAD/SIDEWALKS


SHUTTLE BUS STOP

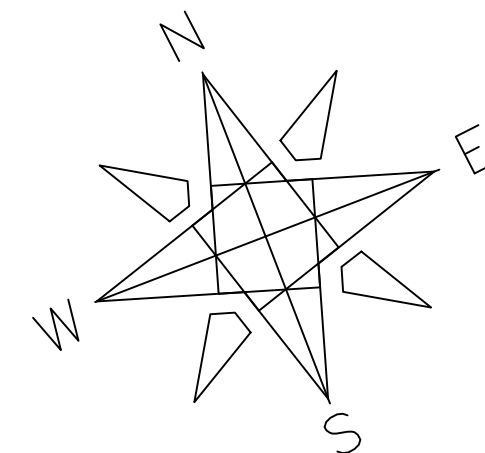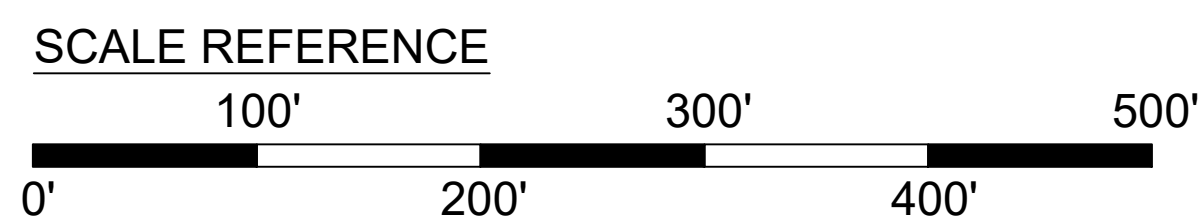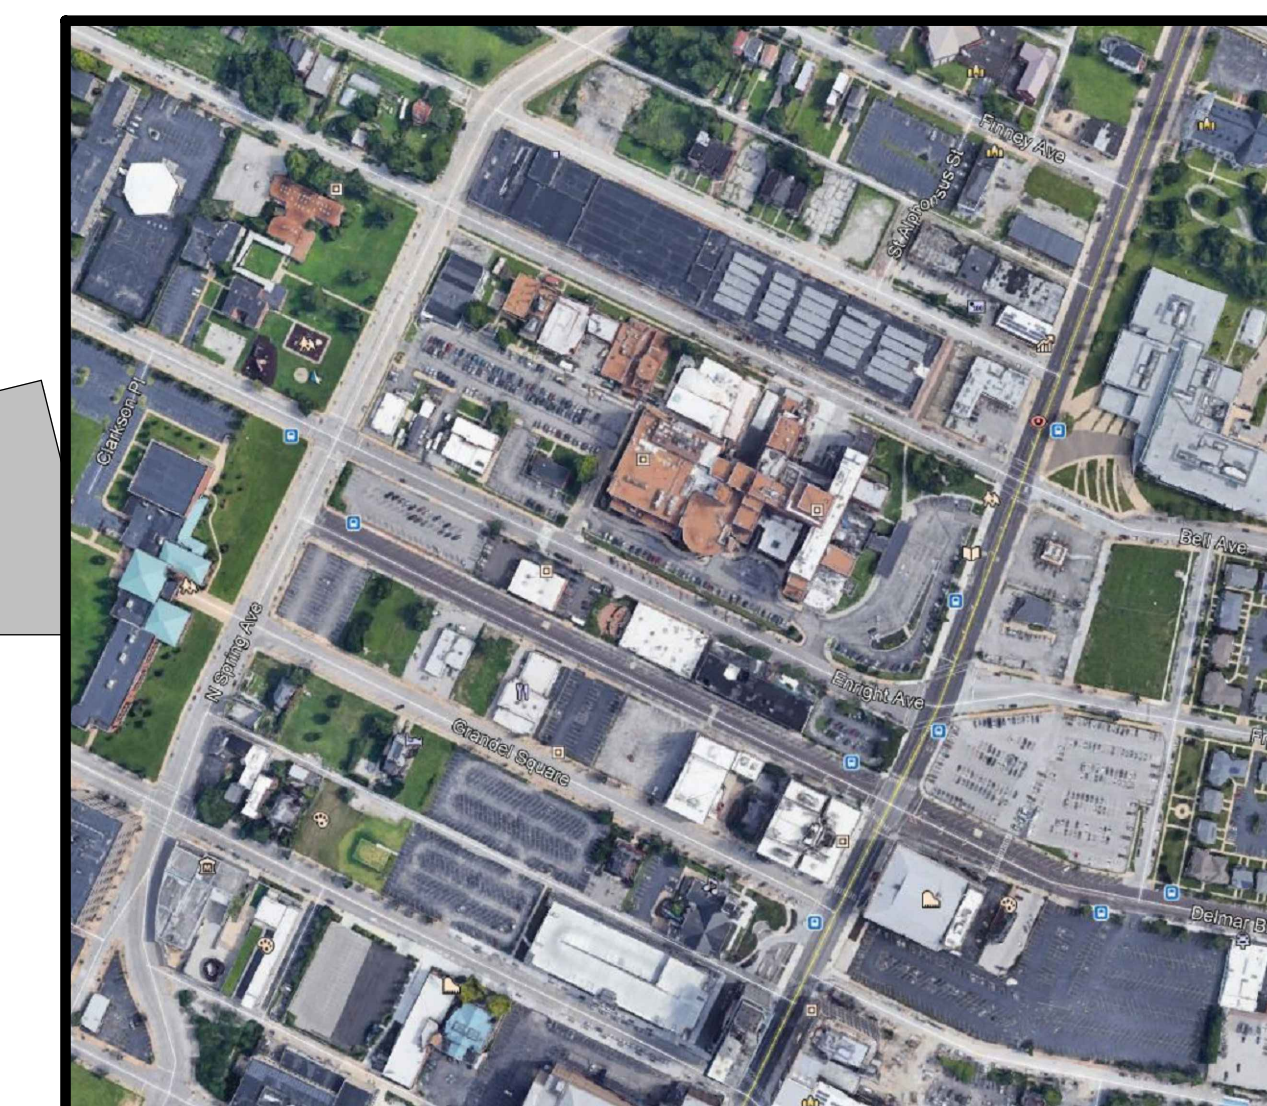

OVERALL CAMPUS SITE PLAN, BUILDING NUMBER, AND PROJECT LOCATOR

BIDDING DOCUMENTS

Revisions: <table><tr><td>1</td><td></td></tr><tr><td>2</td><td></td></tr><tr><td>3</td><td></td></tr><tr><td>4</td><td></td></tr><tr><td>5</td><td></td></tr><tr><td>6</td><td></td></tr><tr><td>7</td><td></td></tr><tr><td>8</td><td></td></tr><tr><td>9</td><td></td></tr><tr><td>10</td><td></td></tr><tr><td>11</td><td></td></tr><tr><td>12</td><td></td></tr><tr><td>13</td><td></td></tr><tr><td>14</td><td></td></tr><tr><td>15</td><td></td></tr><tr><td>16</td><td></td></tr></table>	1		2		3		4		5		6		7		8		9		10		11		12		13		14		15		16		CONSULTANTS: INTEGRATED PROJECT TEAM		ARCHITECT/ENGINEERS: VA ST. LOUIS HEALTHCARE SYSTEM	Drawing Title TITLE SHEE	Project Title Replace Select Hot Water Heating System	Project Number 657-27-107JC	Veterans Health Administration
	1																																						
	2																																						
	3																																						
4																																							
5																																							
6																																							
7																																							
8																																							
9																																							
10																																							
11																																							
12																																							
13																																							
14																																							
15																																							
16																																							
				VA Health Care System Approval:	Location JOHN COCHRAN DIVISION 915 NORTH GRAND BLVD - ST. LOUIS, MO 63106	Building Number 01																																	
					Date 07/24/2026	Drawing Number 01-GI-001																																	
					Checked B	Drawing # - of -	U.S. Department of Veterans Affairs																																

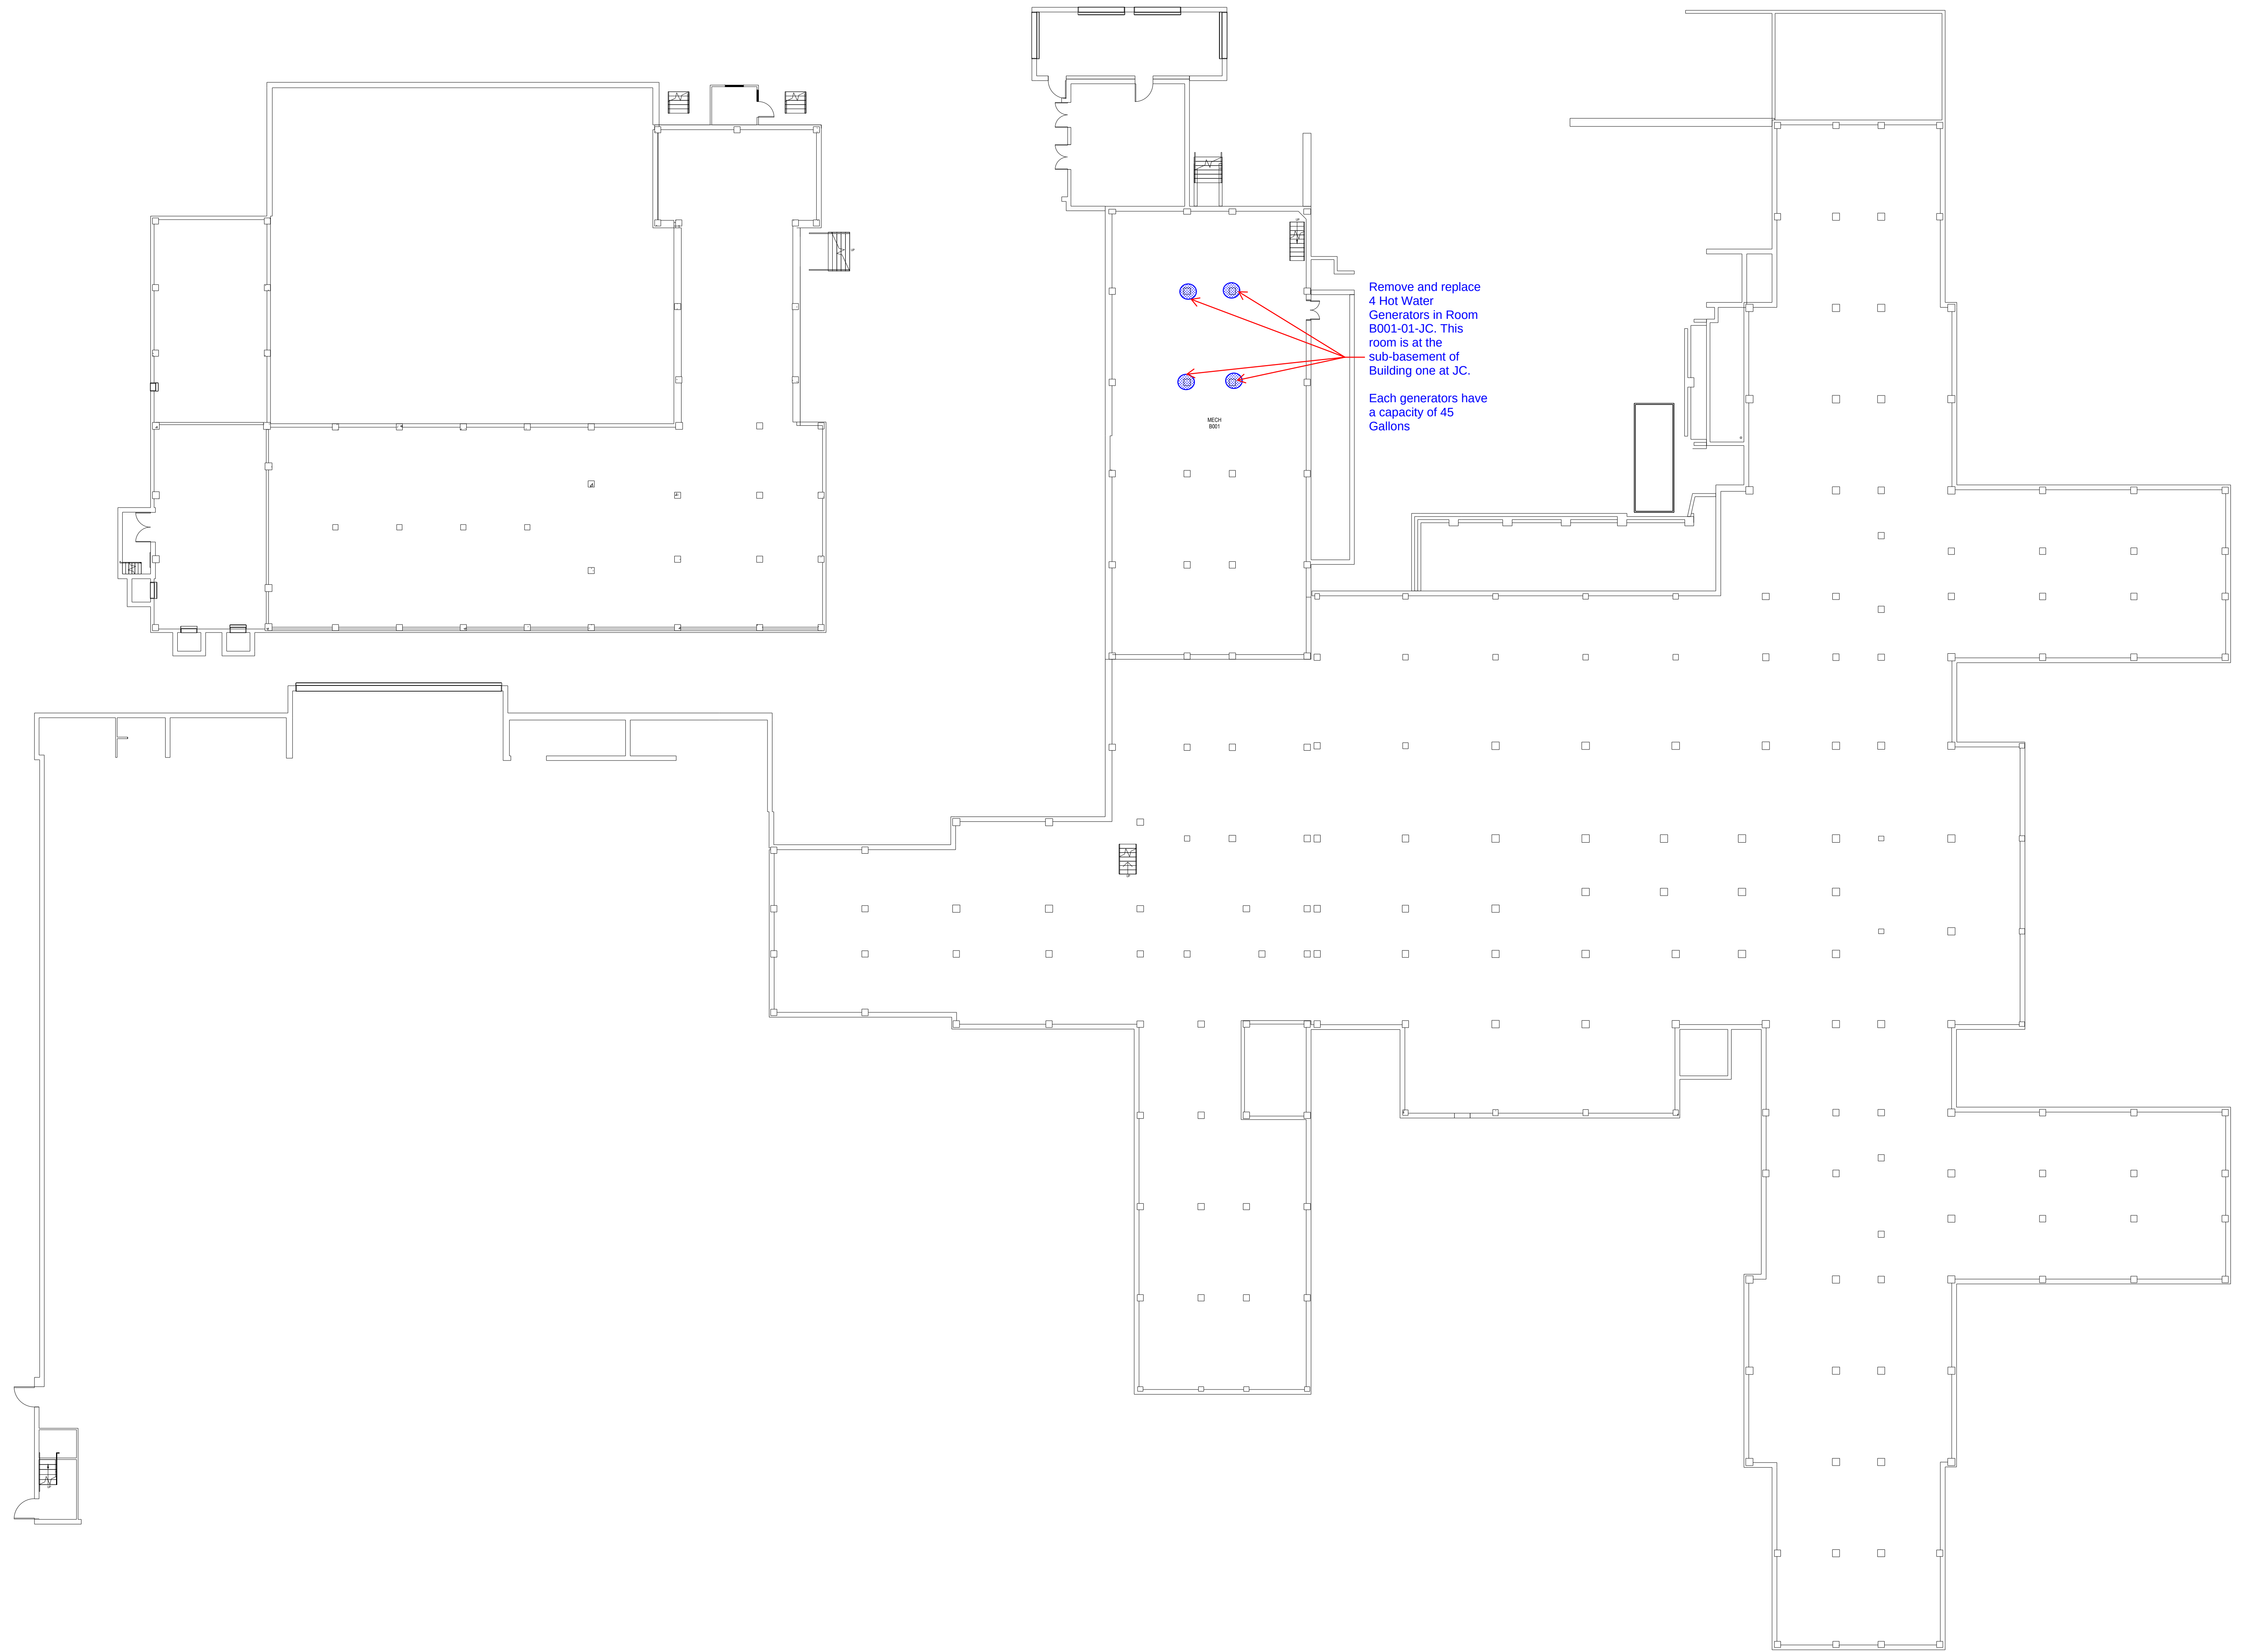

BIDDING DOCUMENTS

Revisions:	Date:	CONSULTANTS:		ARCHITECT/ENGINEERS:	Drawing Title	Project Title	Project Number	Veterans Health Administration		
		INTEGRATED PROJECT TEAM		VA ST. LOUIS HEALTHCARE SYSTEM	TITLE SHEE	Replace Select Hot Water Heating System	657-27-107JC			
								Building Number	Drawing Number	VA U.S. Department of Veterans Affairs
								01	01-ME-001	
				VA Health Care System Approval:	Location	Date		Checked	Drawn	
					JOHN COCHRAN DIVISION 915 NORTH GRAND BLVD - ST. LOUIS, MO 63106	07/24/202	B			



HOT WATER GENERATORS 1 & 2

Out of service currently



HOT WATER GENERATOR 3 & 4

In service now but very poor condition