



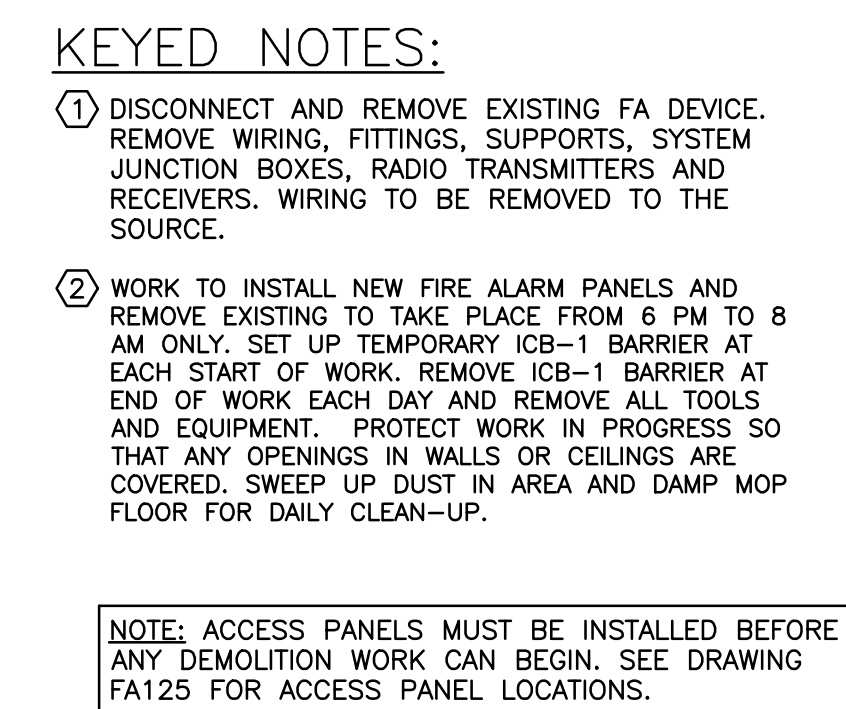

		 VETERANS AFFAIRS MEDICAL CENTER 500 E VETERANS ST TOMAH, WI 54660				CONSULTANTS: 		PROJECT LEADER:  PCG DESIGN / BUILD SERVICES 1021 N. Superior Ave. Unit 11 Tomah, Wisconsin 54660		Drawing Title FIRE ALARM B406 SECOND FLOOR PLAN - DEMOLITION Approved: Project Director		Project Title UPGRADE FIRE ALARM SYSTEM DESIGN		Project Number 676-22-110		Building Number B406		Office of Facilities Management			
Revisions:		Date								Location Tomah, Wisconsin		Date APRIL 21, 2026		Checked By: HFB		Drawn By: JMD		Drawing Number FD125		 Department of Veterans Affairs	

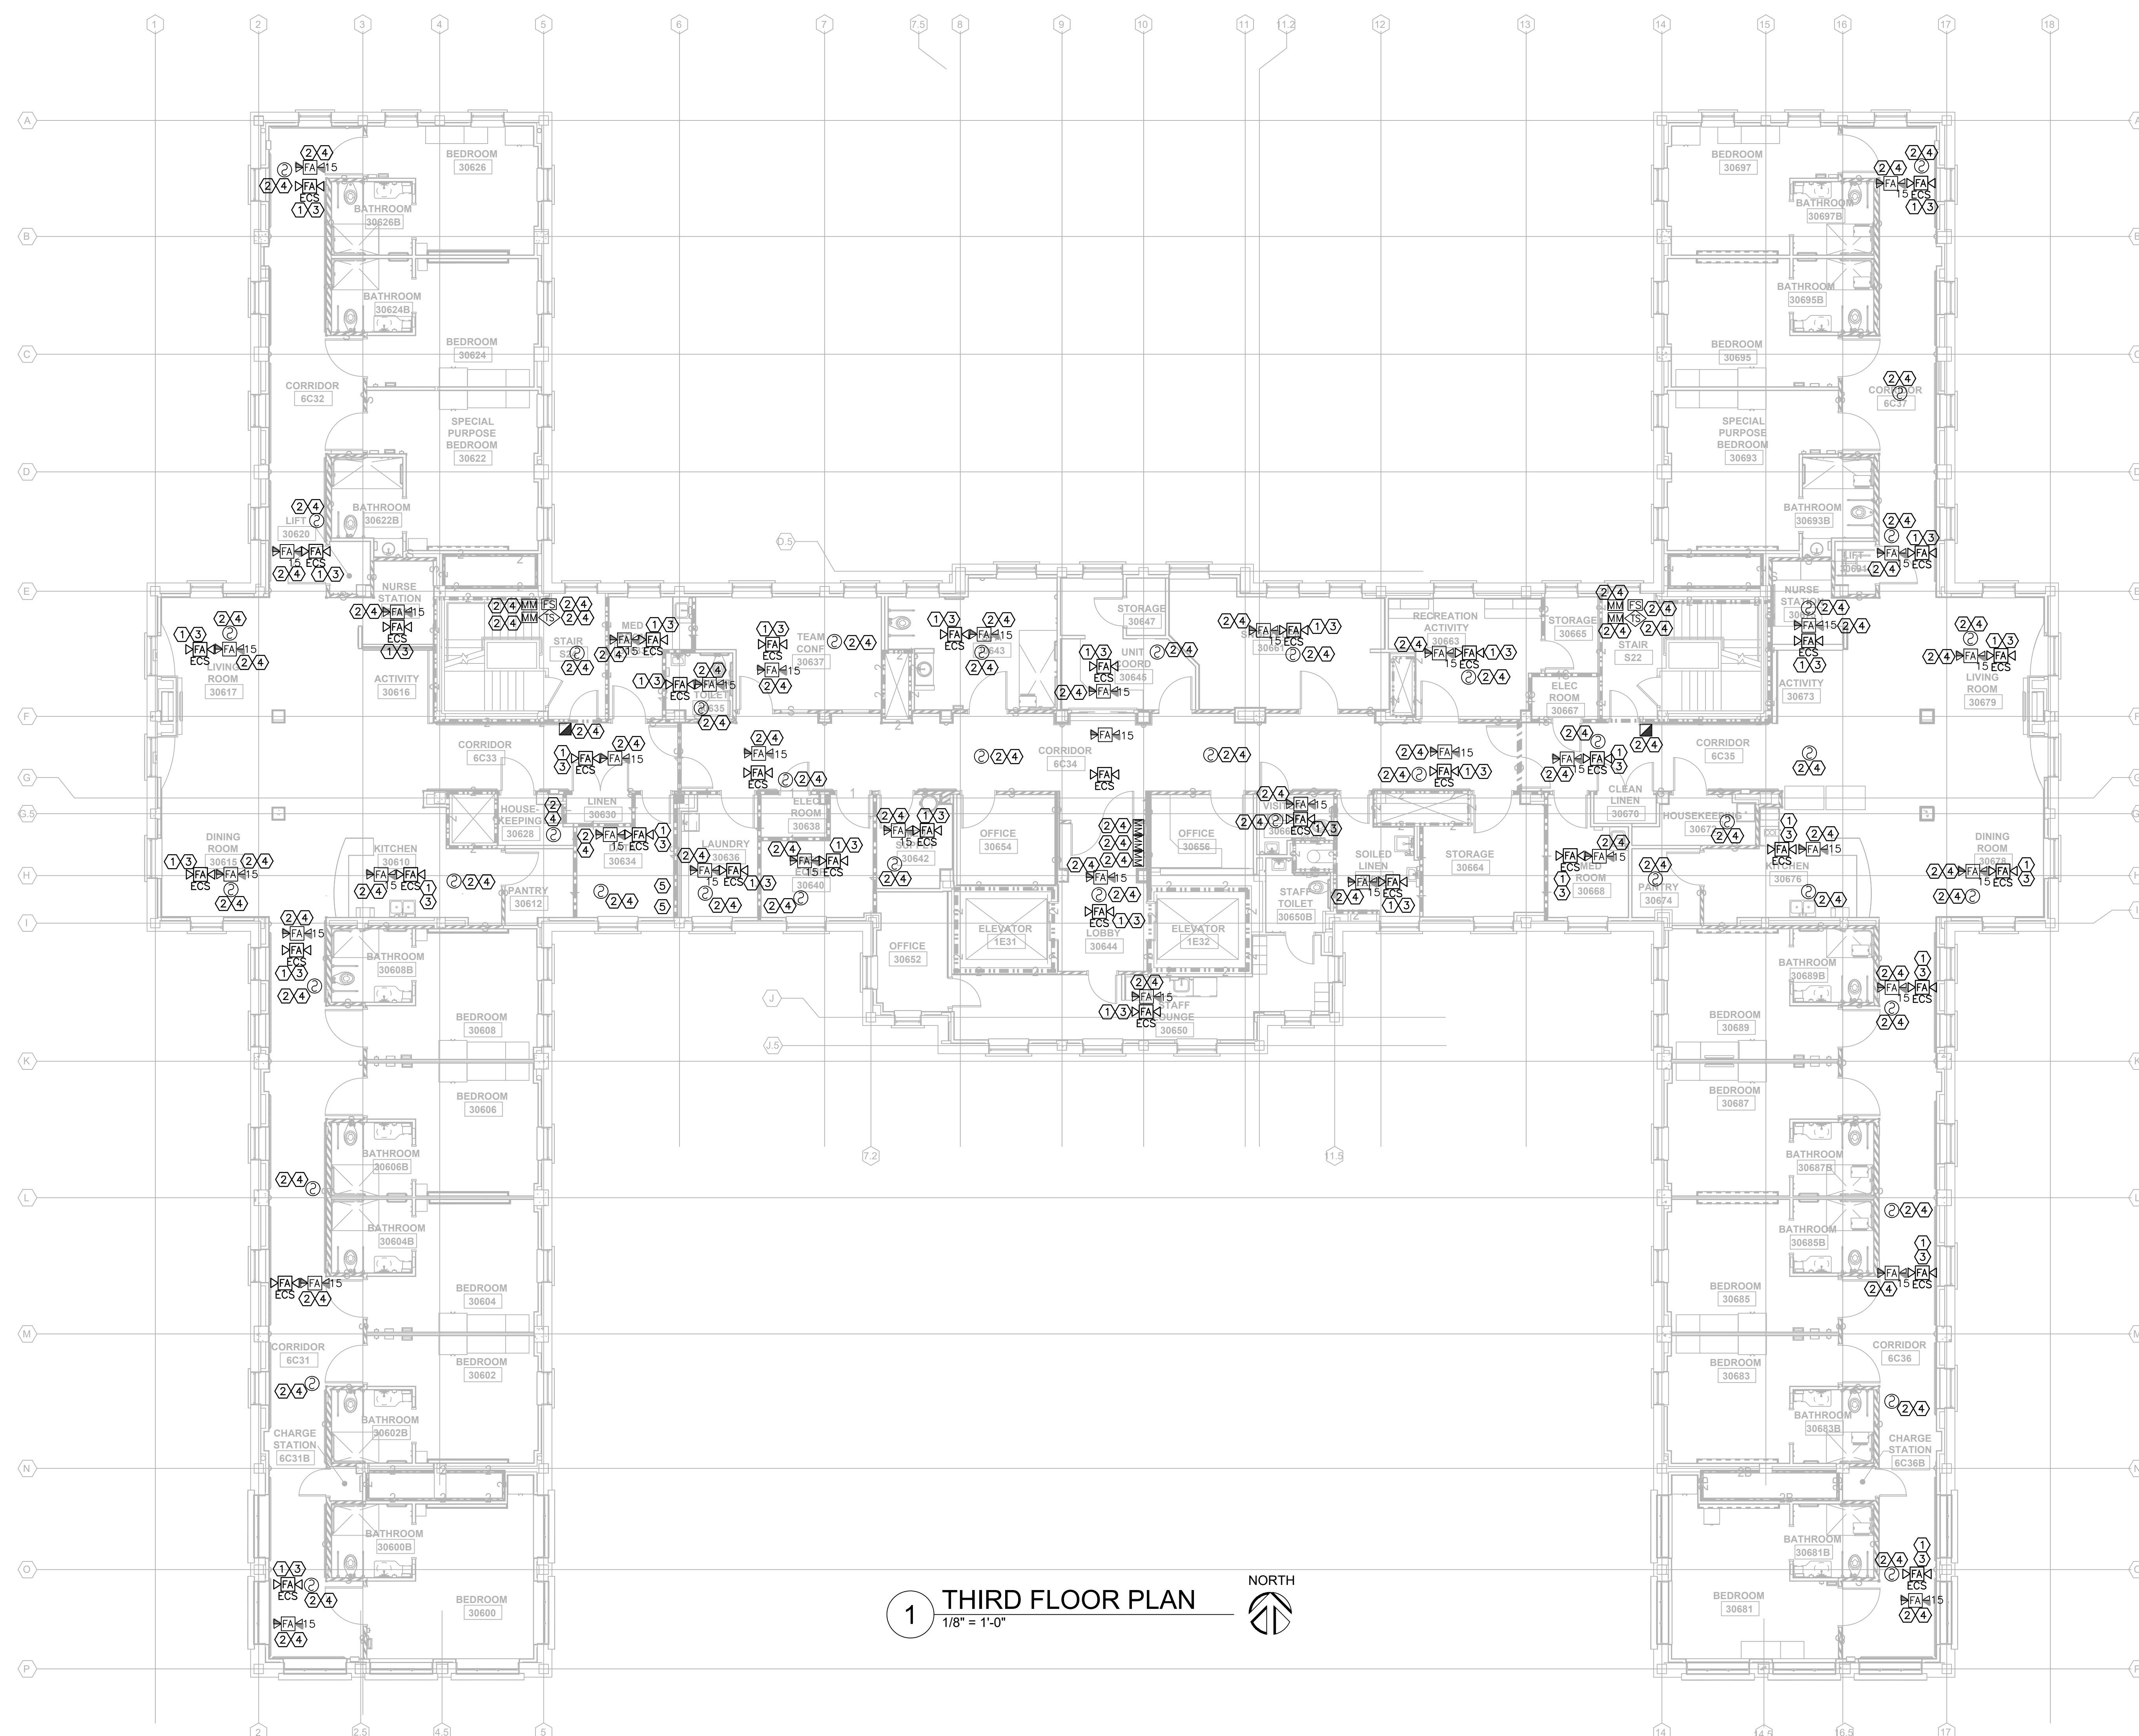

GENERAL NOTES:

1. SEE SHEET F001 FOR LEGENDS, NOTES AND ABBREVIATIONS.
2. PROTECT ALL DEVICES AND EQUIPMENT TO REMAIN DURING CONSTRUCTION.
3. FIRE PROTECTION CONTRACTOR TO REVIEW ARCHITECTURAL AND ELECTRICAL PLANS FOR ADDITIONAL INFORMATION AND REQUIRED WORK NECESSARY TO FACILITATE A COMPLETE SYSTEM AND IS PART OF FIRE PROTECTION CONTRACTOR'S SCOPE OF WORK.
4. MAINTAIN CONTINUOUS UTILITY SERVICE TO ALL SPACES IN THE BUILDING NOT AFFECTED BY THIS WORK. COORDINATE WITH VA COR. ANY DISRUPTION IN SERVICES REQUIRED TO PERFORM WORK.
5. PENETRATIONS THROUGH EXISTING WALLS AND FLOORS REQUIRE FIRE CAULKING BY THIS CONTRACTOR.
6. EXISTING SYSTEM LAYOUT IS BASED ON FIELD SURVEY. EXACT LOCATIONS AND ELEVATIONS MAY VARY.
7. REFER TO ALL OTHER PLANS, DIAGRAMS, DETAILS AND SPECIFICATIONS TO PROVIDE A FULLY FUNCTIONAL SYSTEM. PROVIDE OFFSETS NOT SHOWN ON DIAGRAMS TO AVOID OBSTRUCTIONS.
8. SUPPORT EQUIPMENT, PANELS, DEVICES, CABLES AND WIRING FROM STRUCTURE, WALLS AND FLOOR SO THAT ALL ITEMS ARE ACCESSIBLE FOR MAINTENANCE.
9. ALL BUILDINGS WILL BE CONTINUOUSLY OCCUPIED. ALL SYSTEMS MUST BE AVAILABLE BY 7:00 AM AFTER A NIGHT OR ANY SHUT-DOWN.
10. THIS CONTRACTOR IS RESPONSIBLE TO MOVE EXISTING FURNITURE OUT OF THE WAY OF THE REQUIRED WORK AND MOVE IT BACK AFTER THE WORK IS COMPLETED.
11. DEMOLITION AND REMOVAL OF EXISTING FIRE ALARM DEVICES, CONDUIT, AND ALL OTHER COMPONENTS OF EXISTING FIRE ALARM SYSTEM IS TAKE CARE OF BY THE CONTRACTOR. NEW FIRE ALARM SYSTEM IS COMPLETE. SEE DETAILS ON SHEET F501.

KEYED NOTES:

- ① DISCONNECT AND REMOVE EXISTING ECS DEVICE. REMOVE WIRING, FITTINGS, SUPPORTS, AND JUNCTION BOXES; BACK TO SOURCE SO THAT THE REMAINING EXISTING ECS SYSTEM IS ISOLATED FROM THE ECS SYSTEM.
- ② ISOLATE EXISTING FA SYSTEM FROM DEMOLISHED ECS SYSTEM INCLUDING WIRING, FITTINGS, AND JUNCTION BOXES TO REMAIN.
- ③ PROVIDE PLAIN PLASTIC JUNCTION BOX COVER FOR JUNCTION BOXES THAT MUST REMAIN IN PLACE WHERE ECS DEVICE WAS REMOVED. COVER EACH CEILING CELL WITH COLOR, REPAIR CEILING TILES BACKING SO NO BACKING IS EXPOSED TO VIEW. PROVIDE LAMINATE SIGN AT EACH LOCATION, RED BACKGROUND WITH WHITE LETTER, "EMPTY FIRE ALARM JUNCTION BOX BEHIND."
- ④ EXISTING RED FIRE ALARM CONDUIT AND JUNCTION BOXES MAY REMAIN.
- ⑤ EXISTING NAC PANELS TO REMAIN, REMOVE ALL WIRING TO AND FROM EVERY AND ALL NAC PANELS.

NOTE: ACCESS PANELS MUST BE INSTALLED BEFORE ANY DEMOLITION WORK CAN BEGIN. SEE DRAWING FA126 FOR ACCESS PANEL LOCATIONS.

[illegible]

CONSULTANTS:

PROJECT LEADER:



Drawing Title	FIRE ALARM B406 THIRD FLOOR PLAN - DEMOLITION
---------------	---

Approved: Project Director

Project Title	UPGRADE FIRE ALARM SYSTEM DESIGN
---------------	-------------------------------------

	Location Tomah, Wisconsin

Date
APRIL 21, 2026

Checked By:	HFB
-------------	-----

Drawn By:
JMD

FINAL BID DOCUMENTS

Project Number	676-22-110
Building Number	B406

Drawing Number	FD126
----------------	-------

Office of
Facilities
Management




GENERAL NOTES:

- SEE SHEET F001 FOR LEGENDS, NOTES AND ABBREVIATIONS.
- PROTECT ALL DEVICES AND EQUIPMENT TO REMAIN DURING CONSTRUCTION.
- FIRE PROTECTION CONTRACTOR TO REVIEW ARCHITECTURAL AND ELECTRICAL PLANS FOR ADDITIONAL INFORMATION AND REQUIRED WORK NECESSARY TO FACILITATE A COMPLETE SYSTEM AND IS PART OF FIRE PROTECTION CONTRACTOR'S SCOPE OF WORK.
- MAINTAIN CONTINUOUS UTILITY SERVICE TO ALL SPACES IN THE BUILDING NOT AFFECTED BY THIS WORK. COORDINATE WITH VA COR ANY DISRUPTION IN SERVICES REQUIRED TO PERFORM WORK.
- PENETRATIONS THROUGH EXISTING WALLS AND FLOORS REQUIRE FIRE CAULKING BY THIS CONTRACTOR.
- EXISTING SYSTEM LAYOUT IS BASED ON FIELD SURVEY. EXACT LOCATIONS AND ELEVATIONS MAY VARY.
- REFER TO ALL OTHER PLANS, DIAGRAMS, DETAILS AND SPECIFICATIONS TO PROVIDE A FULLY FUNCTIONAL SYSTEM. PROVIDE OFFSETS NOT SHOWN ON DIAGRAMS TO AVOID OBSTRUCTIONS.
- SUPPORT EQUIPMENT, PANELS, DEVICES, CABLES AND WIRING FROM STRUCTURE, WALLS AND FLOOR SO THAT ALL ITEMS ARE ACCESSIBLE FOR MAINTENANCE.
- ALL BUILDINGS WILL BE CONTINUOUSLY OCCUPIED. ALL SYSTEMS MUST BE AVAILABLE BY 7:00 AM AFTER A NIGHT OR ANY SHUT-DOWN.
- THIS CONTRACTOR IS RESPONSIBLE TO MOVE EXISTING FURNITURE OUT OF THE WAY OF THE REQUIRED WORK AND MOVE IT BACK AFTER THE WORK IS COMPLETED.
- DEMOLITION AND REMOVAL OF EXISTING FIRE ALARM DEVICES, CONDUIT, AND ALL OTHER COMPONENTS OF EXISTING FIRE ALARM SYSTEM TO TAKE PLACE AFTER INSTALLATION OF NEW FIRE ALARM SYSTEM IS COMPLETE. SEE DETAILS ON SHEET F501.


KEYED NOTES:

- DISCONNECT AND REMOVE EXISTING FA DEVICE. REMOVE WIRING, FITTINGS, SUPPORTS, SYSTEM JUNCTION BOXES, RADIO TRANSMITTERS AND RECEIVERS. WIRING TO BE REMOVED TO THE SOURCE.
- WORK TO INSTALL NEW FIRE ALARM PANELS AND REMOVE EXISTING TO TAKE PLACE FROM 6 PM TO 8 AM ONLY. SET UP TEMPORARY ICB-1 BARRIER AT EACH START OF WORK. REMOVE ICB-1 BARRIER AT END OF WORK EACH DAY AND REMOVE ALL TOOLS AND EQUIPMENT. PROTECT WORK IN PROGRESS SO THAT ANY OPENINGS IN WALLS OR CEILINGS ARE COVERED. SWEEP UP DUST IN AREA AND DAMP MOP FLOOR FOR DAILY CLEAN-UP.
- REMOVE EXISTING ELECTRICAL/FIRE ALARM CABINET. REMOVE ALL WIRING AND CABLES AND LOCATE WITHIN CONDUITS, WALLS, AND CEILINGS. PATCH WALL AND PAINT TO MATCH EXISTING.
- EXISTING CAMPUS FIRE ALARM CONTROL SERVER/PANEL AND EMERGENCY COMMUNICATIONS LOCATED HERE. DEDICATION FOR TOMAH VA POLICE DEPARTMENT. THE EXISTING FIRE ALARM MUST REMAIN ACTIVE WHILE ANY REMOTE BUILDING'S FACP AND FIRE ALARM SYSTEM IS OPERATIONAL. ONLY WHEN EVERY NEW BUILDING SYSTEMS ARE FULLY OPERATIONAL, COMMISSIONED, AND ACCEPTED BY THE TOMAH VA FIRE DEPARTMENT FOR THE ENTIRE CAMPUS MAY THE EXISTING FIRE ALARM MAIN CONTROL SERVER/PANEL BE DE-COMMISSIONED. DO NOT DISTURB OR ALTER THE EMERGENCY COMMUNICATIONS SYSTEM FUNCTIONALITY.
- EXISTING TOMAH CAMPUS FIRE ALARM RADIO COMMUNICATIONS SYSTEM DUPLICATE IS IN THIS TOMAH VA POLICE STATION. THE EXISTING RADIO SYSTEM MUST REMAIN ACTIVE WHILE ANY REMOTE BUILDING'S FACP AND FIRE ALARM SYSTEM IS OPERATIONAL. ONLY WHEN EVERY NEW BUILDING SYSTEMS ARE FULLY OPERATIONAL, COMMISSIONED, AND ACCEPTED BY THE TOMAH VA FIRE DEPARTMENT FOR THE ENTIRE CAMPUS MAY THE EXISTING FIRE ALARM RADIO SYSTEM BE DE-COMMISSIONED.
- PROVIDE ICB, SEE DETAIL 1 ON DRAWING GC101 FOR REQUIREMENTS. COORDINATE LOCATION AND DURATION WITH TOMAH VA POLICE DEPARTMENT PERSONNEL. THE POLICE DEPARTMENT PERSONNEL MUST BE ABLE TO FREELY ACCESS THE EXISTING CAMPUS DISPATCH AND CONTROL DESK. EMERGENCY COMMUNICATIONS SYSTEM, POLICE COMMUNICATIONS SYSTEM, AND FIRE ALARM RADIO SYSTEM. 24 HOURS PER DAY, 7 DAYS PER WEEK, NO EXCEPTIONS.
- PROVIDE ICB, SEE DETAIL 2 ON DRAWING GC101 FOR REQUIREMENTS.
- THE NEW FIRE ALARM DETECTION AND ALARM SYSTEM SHALL UTILIZE RADIO FREQUENCY (RF) TO COMMUNICATION WITH THE FIRE COMMAND CENTER, LOCATED IN BUILDING 36, AND POLICE STATION, LOCATED IN BUILDING 407. THE NEW FIRE ALARM DETECTION AND ALARM SYSTEM SHALL HAVE A RF ANTENNA INTERNAL TO THE UNIT. THE NEW FIRE ALARM DETECTION AND ALARM SYSTEM SHALL HAVE A COMMAND CENTER CONSOLE AND DISPLAYS LOCATED IN BUILDINGS 36 AND 407. THE FIRE ALARM DETECTION AND ALARM SYSTEM SOFTWARE SHALL BE INSTALLED ON A MAIN SERVER IN BUILDING 32 IN THE COMPUTER ROOM DESIGNATED BY THE IT OPERATIONS AT THE TOMAH VA MEDICAL CENTER.
- THE CONTRACTOR SHALL CONDUCT ACCEPTANCE TESTING FOR EVERY FACP AND BUILDING THAT BECOMES ACTIVE WITHIN THE NEW FIRE ALARM DETECTION AND ALARM SYSTEM PROGRAMMING, AND ACCORDING TO A SCHEDULE COORDINATED WITH COR AND CCR. EITHER OR BOTH MAY ELECT TO BE IN ATTENDANCE TO WITNESS THE TEST PROCEDURES. NOTIFY THE FIRE DEPARTMENT AND POLICE DEPARTMENT IN ADVANCE, 10 WORKING DAYS OF THE PROPOSED SCHEDULED DATE. THE CONTRACTOR SHALL PROVIDE A COMPETENT PERSON AT EACH LOCATION (B36 AND B407) AND AT LEAST ONE TECHNICIAN FROM THE NEW FIRE ALARM DETECTION AND ALARM SYSTEM'S COMPANY AT EACH LOCATION (B36 AND B407) TO LEAD THE PROCESS FOR EACH NEW FACP INTO THE OVERALL SYSTEM. THE NOTIFICATION SHALL INCLUDE A WRITTEN DESCRIPTION OF THE PROPOSED CONDUCT OF THE TESTS INCLUDING COPIES OF BLANK TEST RESULT SHEETS TO BE USED.
- DEMOLISH SAME DEVICES IN CRAWL SPACE, NOTE: THESE DEVICES ARE NOT SHOWN ON THE DEMOLITION OR NEW WORK ONE LINE DIAGRAMS.

NOTE: ACCESS PANELS MUST BE INSTALLED BEFORE ANY DEMOLITION WORK CAN BEGIN. SEE DRAWING FA128 FOR ACCESS PANEL LOCATIONS.

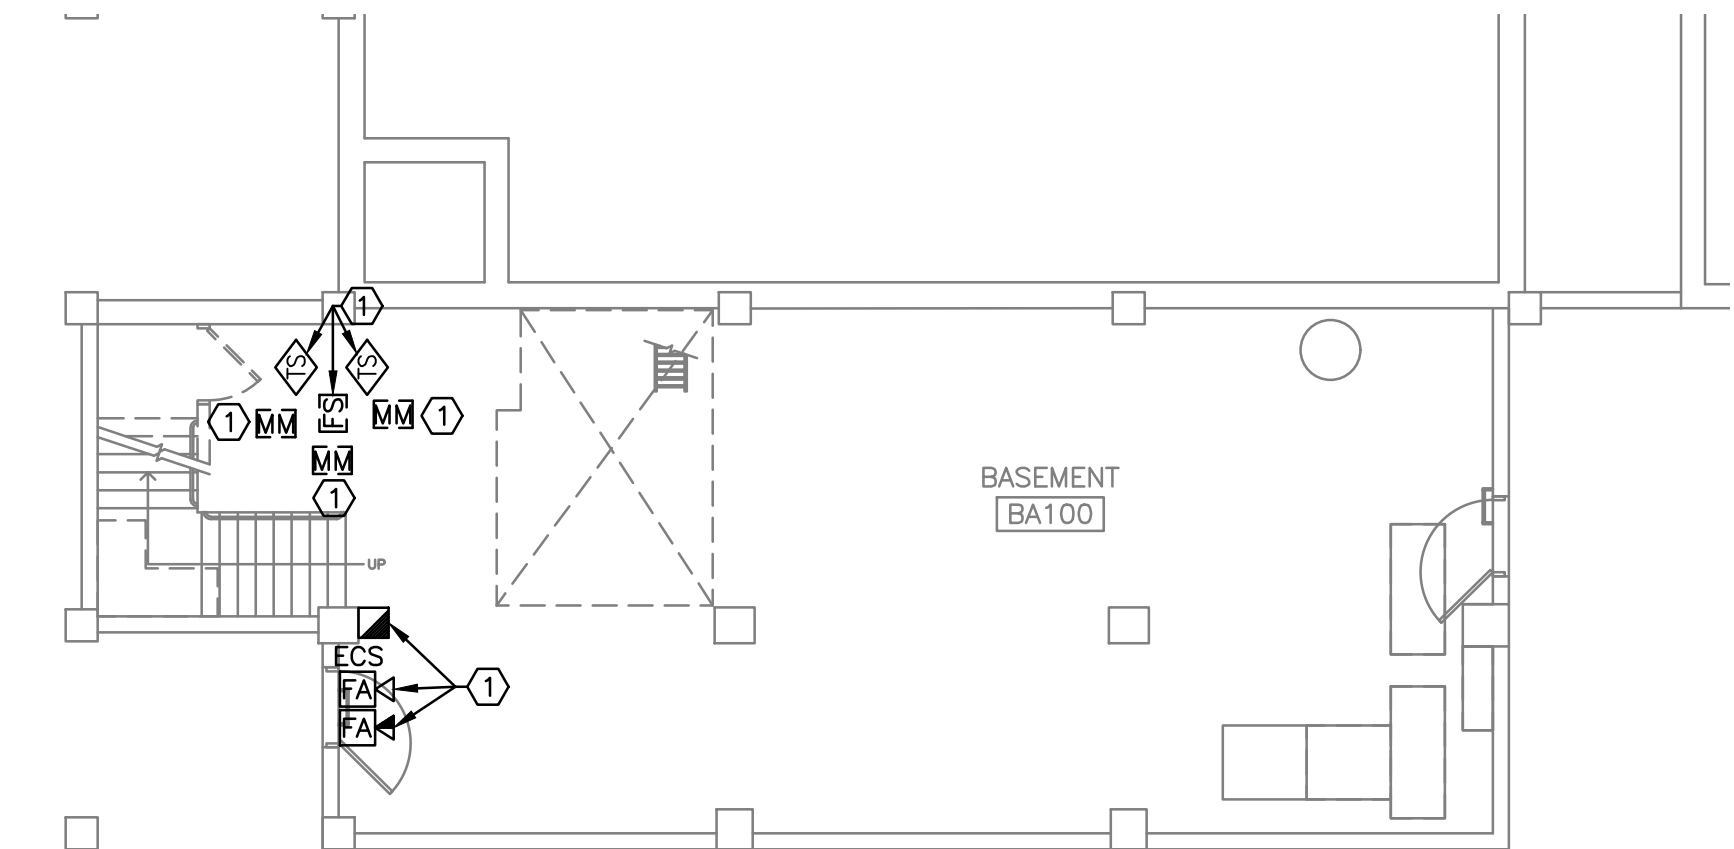

three inches = one foot
one and one half inches = one foot
one inch = one foot
three quarters inch = one foot
one half inch = one foot
three eighths inch = one foot
one quarter inch = one foot
one eighth inch = one foot

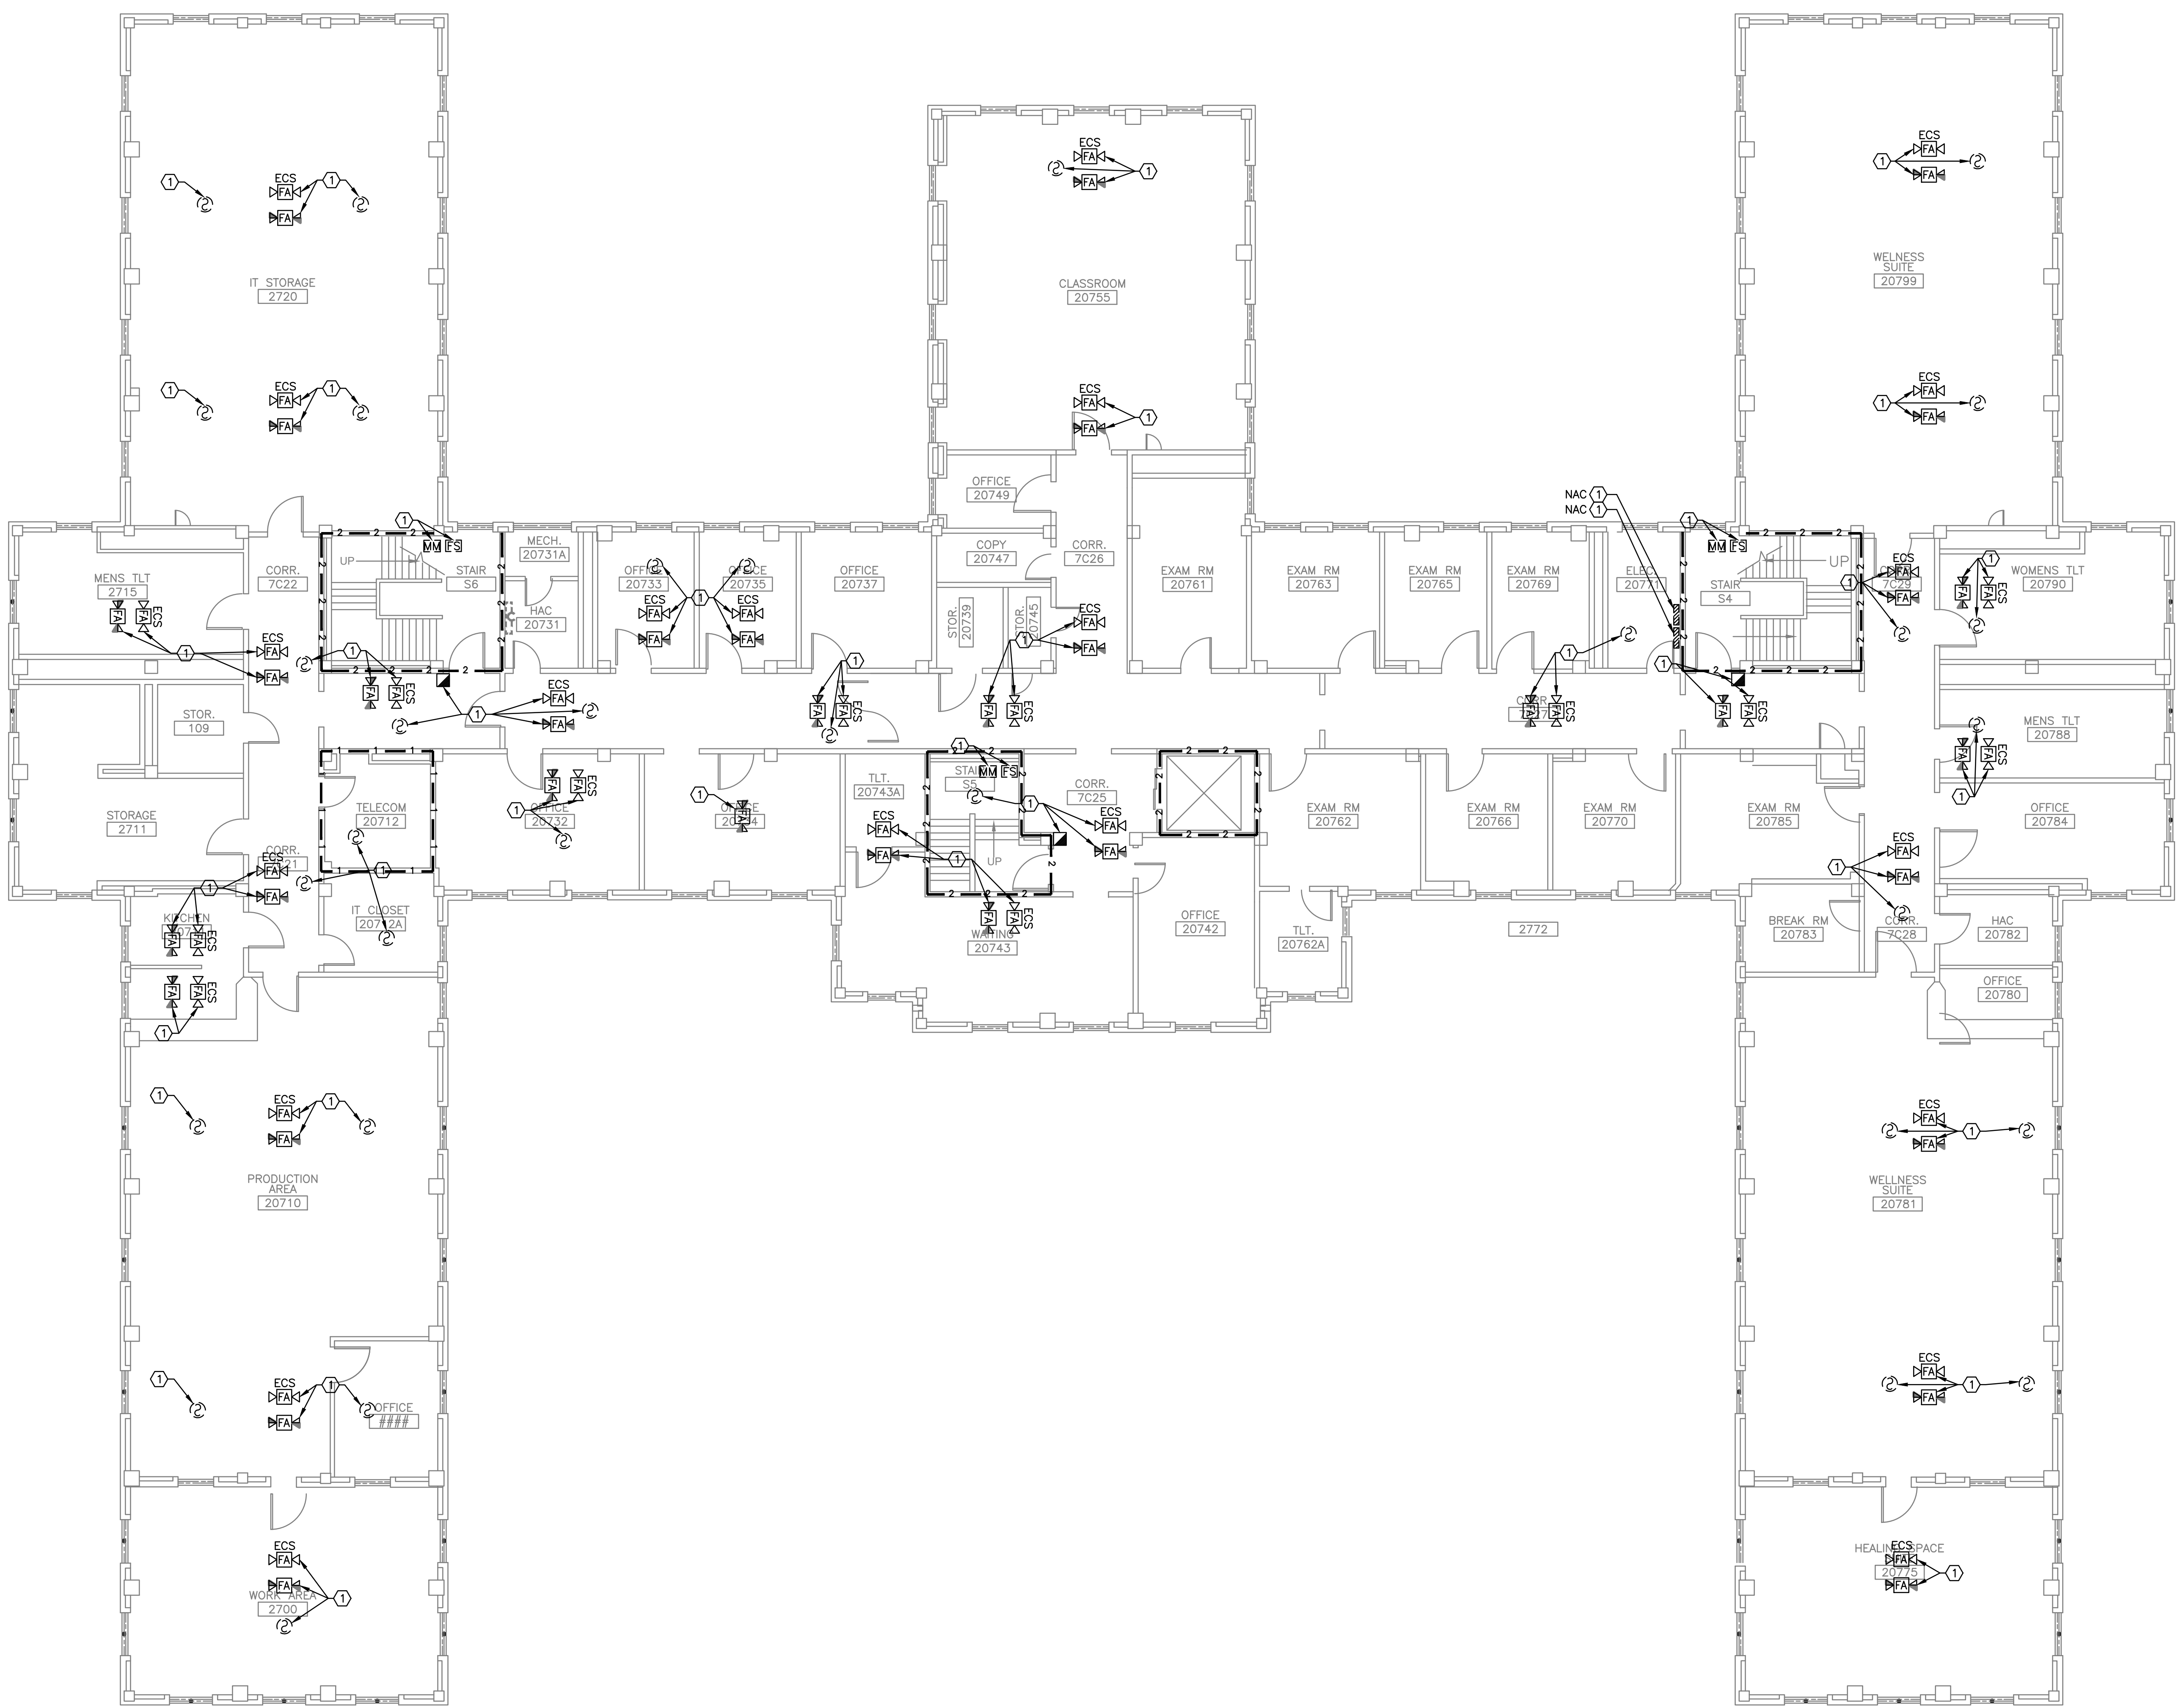


- GENERAL NOTES:**
- SEE SHEET F001 FOR LEGENDS, NOTES AND ABBREVIATIONS.
 - PROTECT ALL DEVICES AND EQUIPMENT TO REMAIN DURING CONSTRUCTION.
 - FIRE PROTECTION CONTRACTOR TO REVIEW ARCHITECTURAL AND ELECTRICAL PLANS FOR ADDITIONAL INFORMATION AND REQUIRED WORK NECESSARY TO FACILITATE A COMPLETE SYSTEM AND IS PART OF FIRE PROTECTION CONTRACTOR'S SCOPE OF WORK.
 - MAINTAIN CONTINUOUS UTILITY SERVICE TO ALL SPACES IN THE BUILDING NOT AFFECTED BY THIS WORK. COORDINATE WITH VA COR ANY DISRUPTION IN SERVICES REQUIRED TO PERFORM WORK.
 - PENETRATIONS THROUGH EXISTING WALLS AND FLOORS REQUIRE FIRE CAULKING BY THIS CONTRACTOR.
 - EXISTING SYSTEM LAYOUT IS BASED ON FIELD SURVEY. EXACT LOCATIONS AND ELEVATIONS MAY VARY.
 - REFER TO ALL OTHER PLANS, DIAGRAMS, DETAILS AND SPECIFICATIONS TO PROVIDE A FULLY FUNCTIONAL SYSTEM. PROVIDE OFFSETS NOT SHOWN ON DIAGRAMS TO AVOID OBSTRUCTIONS.
 - SUPPORT EQUIPMENT, PANELS, DEVICES, CABLES AND WIRING FROM STRUCTURE, WALLS AND FLOOR SO THAT ALL ITEMS ARE ACCESSIBLE FOR MAINTENANCE.
 - ALL BUILDINGS WILL BE CONTINUOUSLY OCCUPIED. ALL SYSTEMS MUST BE AVAILABLE BY 7:00 AM AFTER A NIGHT OR ANY SHUT-DOWN.
 - THIS CONTRACTOR IS RESPONSIBLE TO MOVE EXISTING FURNITURE OUT OF THE WAY OF THE REQUIRED WORK AND MOVE IT BACK AFTER THE WORK IS COMPLETED.
 - DEMOLITION AND REMOVAL OF EXISTING FIRE ALARM DEVICES, CONDUIT, AND ALL OTHER COMPONENTS OF EXISTING FIRE ALARM SYSTEM TO TAKE PLACE AFTER INSTALLATION OF NEW FIRE ALARM SYSTEM IS COMPLETE. SEE DETAILS ON SHEET F501.
- KEYED NOTES:**
- ① DISCONNECT AND REMOVE EXISTING FA DEVICE. REMOVE WIRING, FITTINGS, SUPPORTS, SYSTEM JUNCTION BOXES, RADIO TRANSMITTERS AND RECEIVERS. WIRING TO BE REMOVED TO THE SOURCE.
- NOTE:** ACCESS PANELS MUST BE INSTALLED BEFORE ANY DEMOLITION WORK CAN BEGIN. SEE DRAWING FA129 FOR ACCESS PANEL LOCATIONS.

1 SECOND FLOOR PLAN
1/8" = 1'-0"
NORTH

 VETERANS AFFAIRS MEDICAL CENTER 500 E VETERANS ST TOMAH, WI 54660		CONSULTANTS:	PROJECT LEADER: DESIGN / BUILD SERVICES 1021 N. Superior Ave, Unit 11 Tomah, Wisconsin 54660	Drawing Title FIRE ALARM B407 SECOND FLOOR PLAN - DEMOLITION	Project Title UPGRADE FIRE ALARM SYSTEM DESIGN	FINAL BID DOCUMENTS	
				Approved: Project Director	Location Tomah, Wisconsin Date APRIL 21, 2026 Checked By: HFB Drawn By: JMD	Project Number 676-22-110 Building Number B407 Drawing Number FD129 Office of Facilities Management 	

three inches = one foot
one and one half inches = one foot
one inch = one foot
three quarters inch = one foot
one half inch = one foot
three eighths inch = one foot
one quarter inch = one foot
one eighth inch = one foot

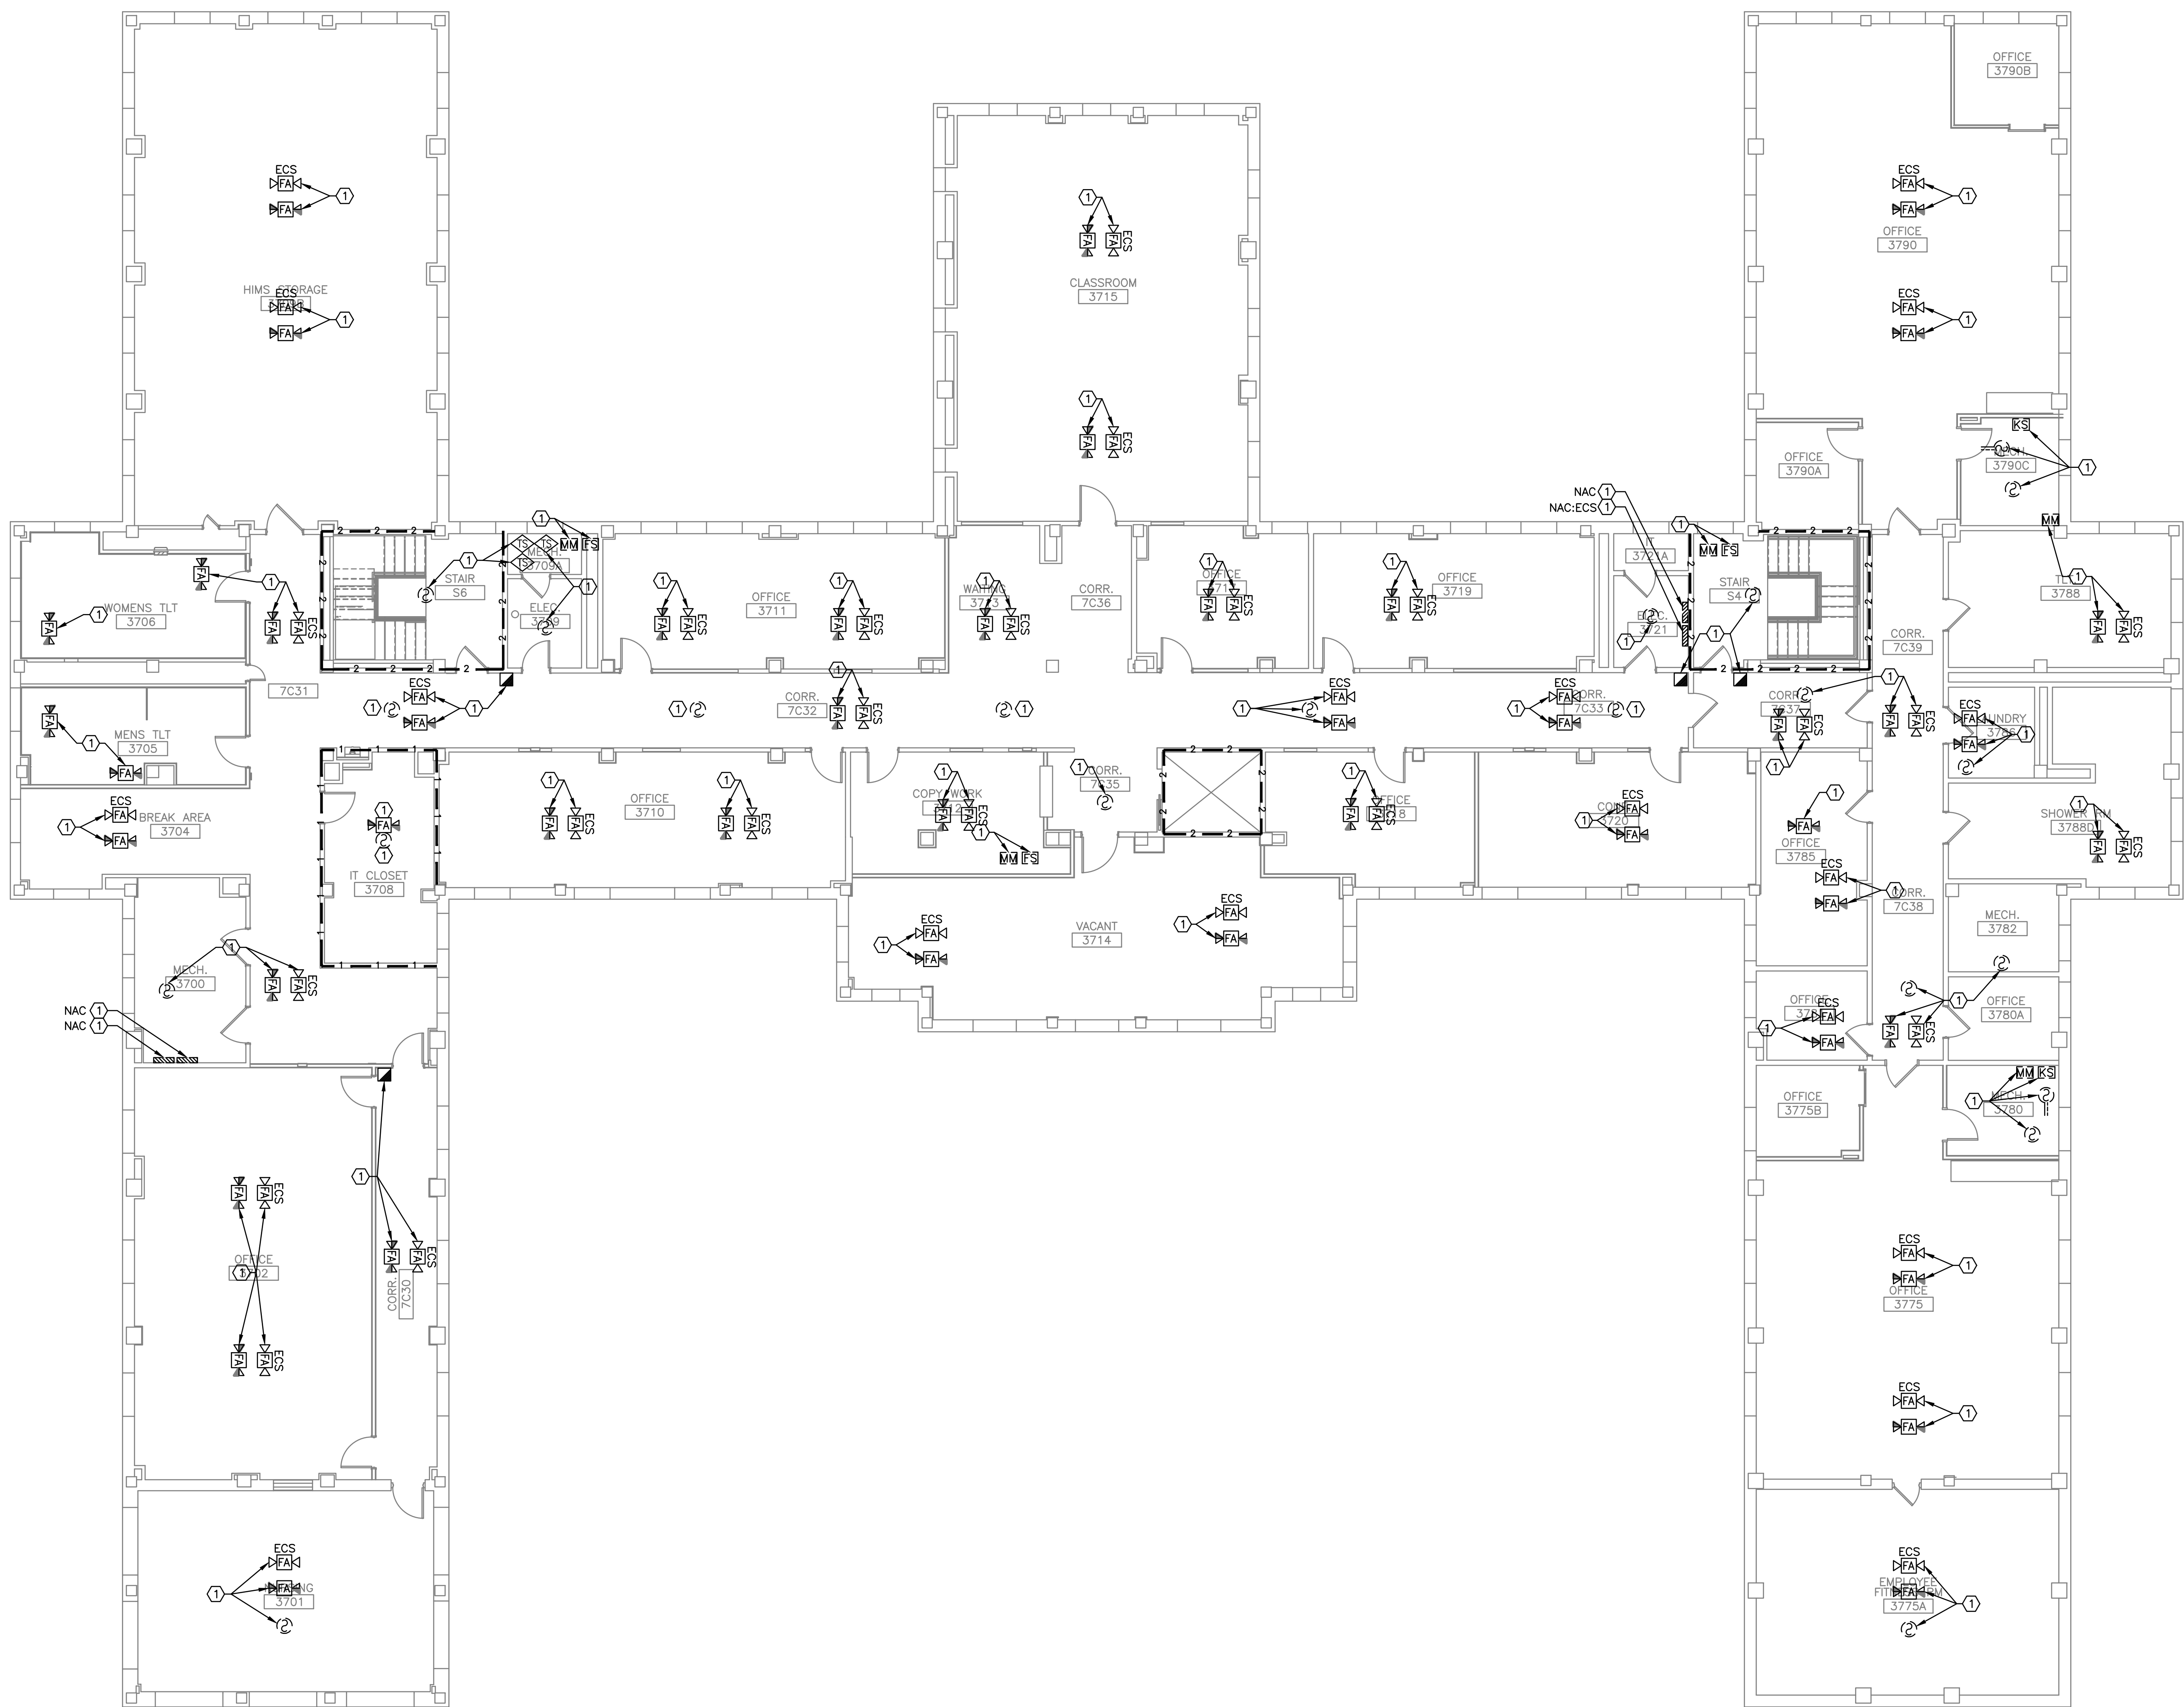

- GENERAL NOTES:**
- SEE SHEET F001 FOR LEGENDS, NOTES AND ABBREVIATIONS.
 - PROTECT ALL DEVICES AND EQUIPMENT TO REMAIN DURING CONSTRUCTION.
 - FIRE PROTECTION CONTRACTOR TO REVIEW ARCHITECTURAL AND ELECTRICAL PLANS FOR ADDITIONAL INFORMATION AND REQUIRED WORK NECESSARY TO FACILITATE A COMPLETE SYSTEM AND IS PART OF FIRE PROTECTION CONTRACTOR'S SCOPE OF WORK.
 - MAINTAIN CONTINUOUS UTILITY SERVICE TO ALL SPACES IN THE BUILDING NOT AFFECTED BY THIS WORK. COORDINATE WITH VA COR ANY DISRUPTION IN SERVICES REQUIRED TO PERFORM WORK.
 - PENETRATIONS THROUGH EXISTING WALLS AND FLOORS REQUIRE FIRE CAULKING BY THIS CONTRACTOR.
 - EXISTING SYSTEM LAYOUT IS BASED ON FIELD SURVEY. EXACT LOCATIONS AND ELEVATIONS MAY VARY.
 - REFER TO ALL OTHER PLANS, DIAGRAMS, DETAILS AND SPECIFICATIONS TO PROVIDE A FULLY FUNCTIONAL SYSTEM. PROVIDE OFFSETS NOT SHOWN ON DIAGRAMS TO AVOID OBSTRUCTIONS.
 - SUPPORT EQUIPMENT, PANELS, DEVICES, CABLES AND WIRING FROM STRUCTURE, WALLS AND FLOOR SO THAT ALL ITEMS ARE ACCESSIBLE FOR MAINTENANCE.
 - ALL BUILDINGS WILL BE CONTINUOUSLY OCCUPIED. ALL SYSTEMS MUST BE AVAILABLE BY 7:00 AM AFTER A NIGHT OR ANY SHUT-DOWN.
 - THIS CONTRACTOR IS RESPONSIBLE TO MOVE EXISTING FURNITURE OUT OF THE WAY OF THE REQUIRED WORK AND MOVE IT BACK AFTER THE WORK IS COMPLETED.
 - DEMOLITION AND REMOVAL OF EXISTING FIRE ALARM DEVICES, CONDUIT, AND ALL OTHER COMPONENTS OF EXISTING FIRE ALARM SYSTEM TO TAKE PLACE AFTER INSTALLATION OF NEW FIRE ALARM SYSTEM IS COMPLETE. SEE DETAILS ON SHEET F501.


- KEYED NOTES:**
- ① DISCONNECT AND REMOVE EXISTING FA DEVICE. REMOVE WIRING, FITTINGS, SUPPORTS, SYSTEM JUNCTION BOXES, RADIO TRANSMITTERS AND RECEIVERS. WIRING TO BE REMOVED TO THE SOURCE.
- NOTE: ACCESS PANELS MUST BE INSTALLED BEFORE ANY DEMOLITION WORK CAN BEGIN. SEE DRAWING FA130 FOR ACCESS PANEL LOCATIONS.

1 THIRD FLOOR PLAN
1/8" = 1'-0"




 VETERANS AFFAIRS MEDICAL CENTER 500 E VETERANS ST TOMAH, WI 54660		CONSULTANTS:	PROJECT LEADER: DESIGN / BUILD SERVICES 1021 N. Superior Ave., Unit 11 Tomah, Wisconsin 54660	Drawing Title FIRE ALARM B407 THIRD FLOOR PLAN - DEMOLITION	Project Title UPGRADE FIRE ALARM SYSTEM DESIGN	FINAL BID DOCUMENTS	
				Approved: Project Director	Location Tomah, Wisconsin	Project Number 676-22-110	Office of Facilities Management
				Date APRIL 21, 2026	Checked By: HFB	Building Number B407	
				Revisions:	Date		

three inches = one foot
one and one half inches = one foot
one inch = one foot
three quarters inch = one foot
one half inch = one foot
three eighths inch = one foot
one quarter inch = one foot
one eighth inch = one foot

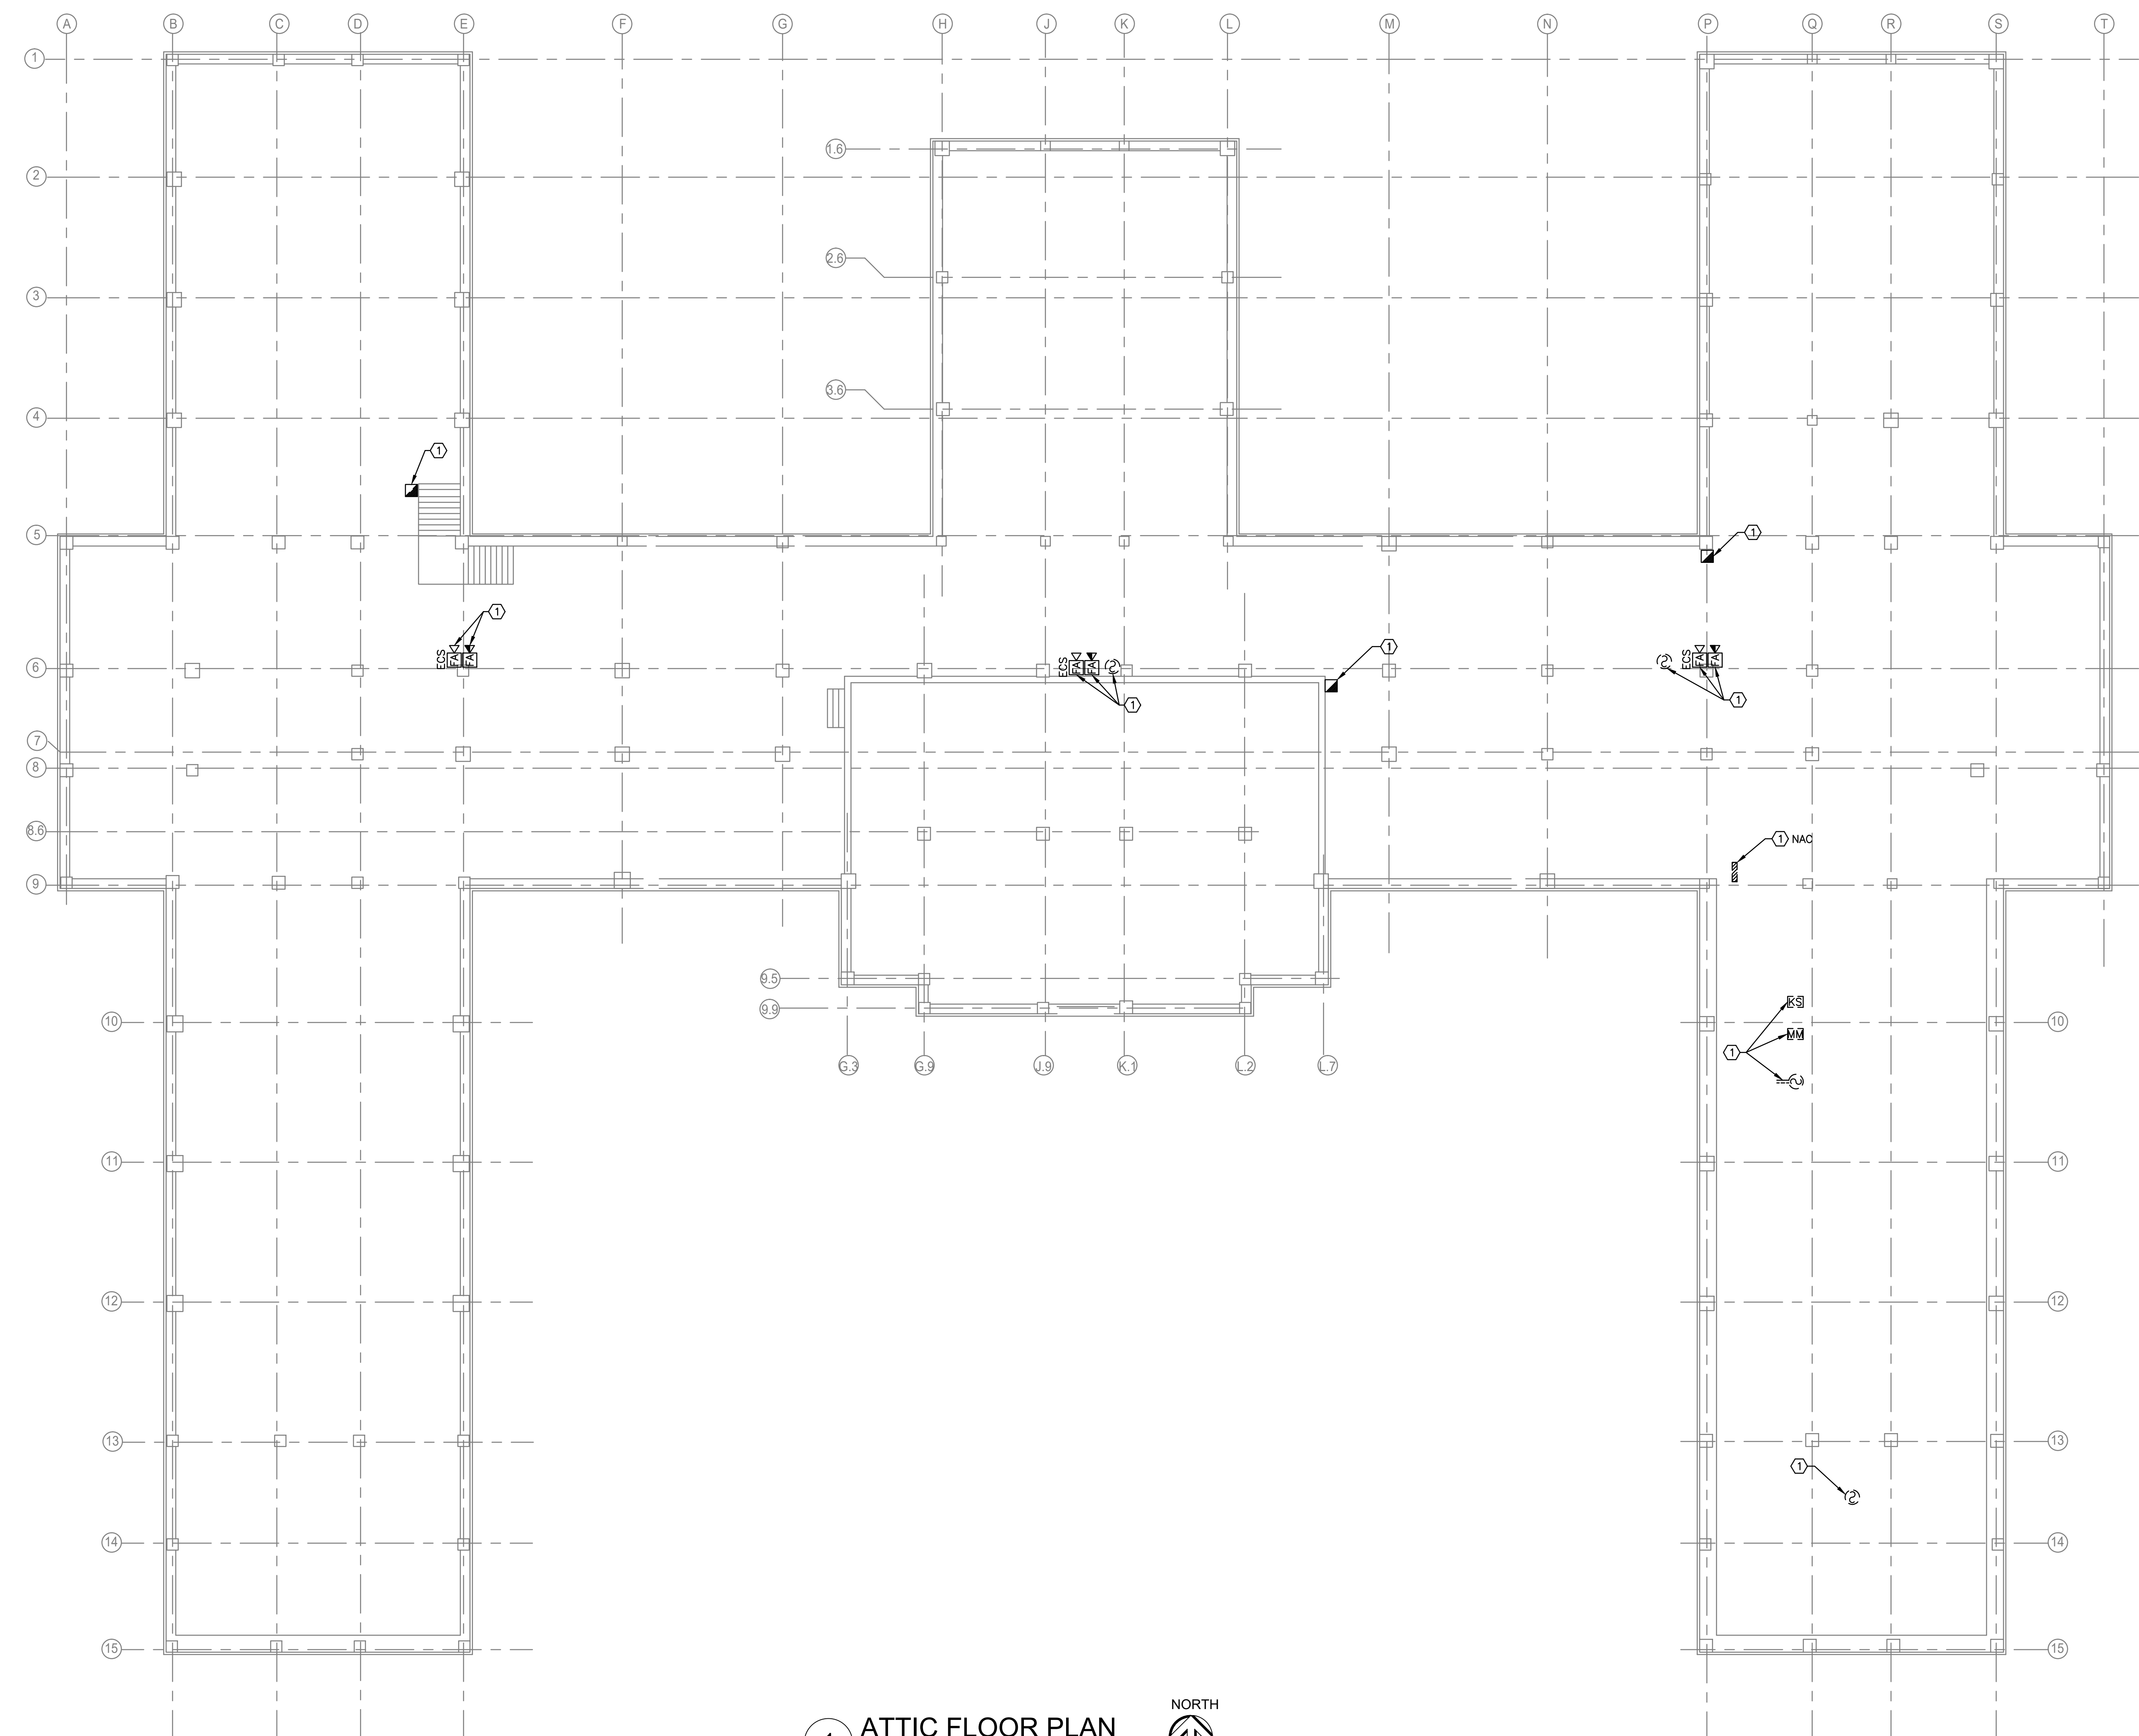


- GENERAL NOTES:**
- SEE SHEET F001 FOR LEGENDS, NOTES AND ABBREVIATIONS.
 - PROTECT ALL DEVICES AND EQUIPMENT TO REMAIN DURING CONSTRUCTION.
 - FIRE PROTECTION CONTRACTOR TO REVIEW ARCHITECTURAL AND ELECTRICAL PLANS FOR ADDITIONAL INFORMATION AND REQUIRED WORK NECESSARY TO FACILITATE A COMPLETE SYSTEM AND IS PART OF FIRE PROTECTION CONTRACTOR'S SCOPE OF WORK.
 - MAINTAIN CONTINUOUS UTILITY SERVICE TO ALL SPACES IN THE BUILDING NOT AFFECTED BY THIS WORK. COORDINATE WITH VA COR ANY DISRUPTION IN SERVICES REQUIRED TO PERFORM WORK.
 - PENETRATIONS THROUGH EXISTING WALLS AND FLOORS REQUIRE FIRE CAULKING BY THIS CONTRACTOR.
 - EXISTING SYSTEM LAYOUT IS BASED ON FIELD SURVEY. EXACT LOCATIONS AND ELEVATIONS MAY VARY.
 - REFER TO ALL OTHER PLANS, DIAGRAMS, DETAILS AND SPECIFICATIONS TO PROVIDE A FULLY FUNCTIONAL SYSTEM. PROVIDE OFFSETS NOT SHOWN ON DIAGRAMS TO AVOID OBSTRUCTIONS.
 - SUPPORT EQUIPMENT, PANELS, DEVICES, CABLES AND WIRING FROM STRUCTURE, WALLS AND FLOOR SO THAT ALL ITEMS ARE ACCESSIBLE FOR MAINTENANCE.
 - ALL BUILDINGS WILL BE CONTINUOUSLY OCCUPIED. ALL SYSTEMS MUST BE AVAILABLE BY 7:00 AM AFTER A NIGHT OR ANY SHUT-DOWN.
 - THIS CONTRACTOR IS RESPONSIBLE TO MOVE EXISTING FURNITURE OUT OF THE WAY OF THE REQUIRED WORK AND MOVE IT BACK AFTER THE WORK IS COMPLETED.
 - DEMOLITION AND REMOVAL OF EXISTING FIRE ALARM DEVICES, CONDUIT, AND ALL OTHER COMPONENTS OF EXISTING FIRE ALARM SYSTEM TO TAKE PLACE AFTER INSTALLATION OF NEW FIRE ALARM SYSTEM IS COMPLETE. SEE DETAILS ON SHEET F501.
- KEYED NOTES:**
- ① DISCONNECT AND REMOVE EXISTING FA DEVICE. REMOVE WIRING, FITTINGS, SUPPORTS, AND SYSTEM JUNCTION BOXES. WIRING TO BE REMOVED TO THE SOURCE.

1 ATTIC FLOOR PLAN
1/8" = 1'-0"

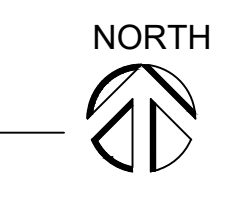

VETERANS AFFAIRS MEDICAL CENTER 500 E VETERANS ST TOMAH, WI 54660			CONSULTANTS:		PROJECT LEADER: PCG DESIGN / BUILD SERVICES 1021 N. Superior Ave., Unit 11 Tomah, Wisconsin 54660		Drawing Title FIRE ALARM B407 ATTIC PLAN - DEMOLITION Approved: Project Director		Project Title UPGRADE FIRE ALARM SYSTEM DESIGN Location Tomah, Wisconsin Date APRIL 21, 2026 Checked By: HFB Drawn By: JMD		FINAL BID DOCUMENTS Project Number 676-22-110 Building Number B407 Drawing Number FD131		Office of Facilities Management 		
Revisions:		Date													

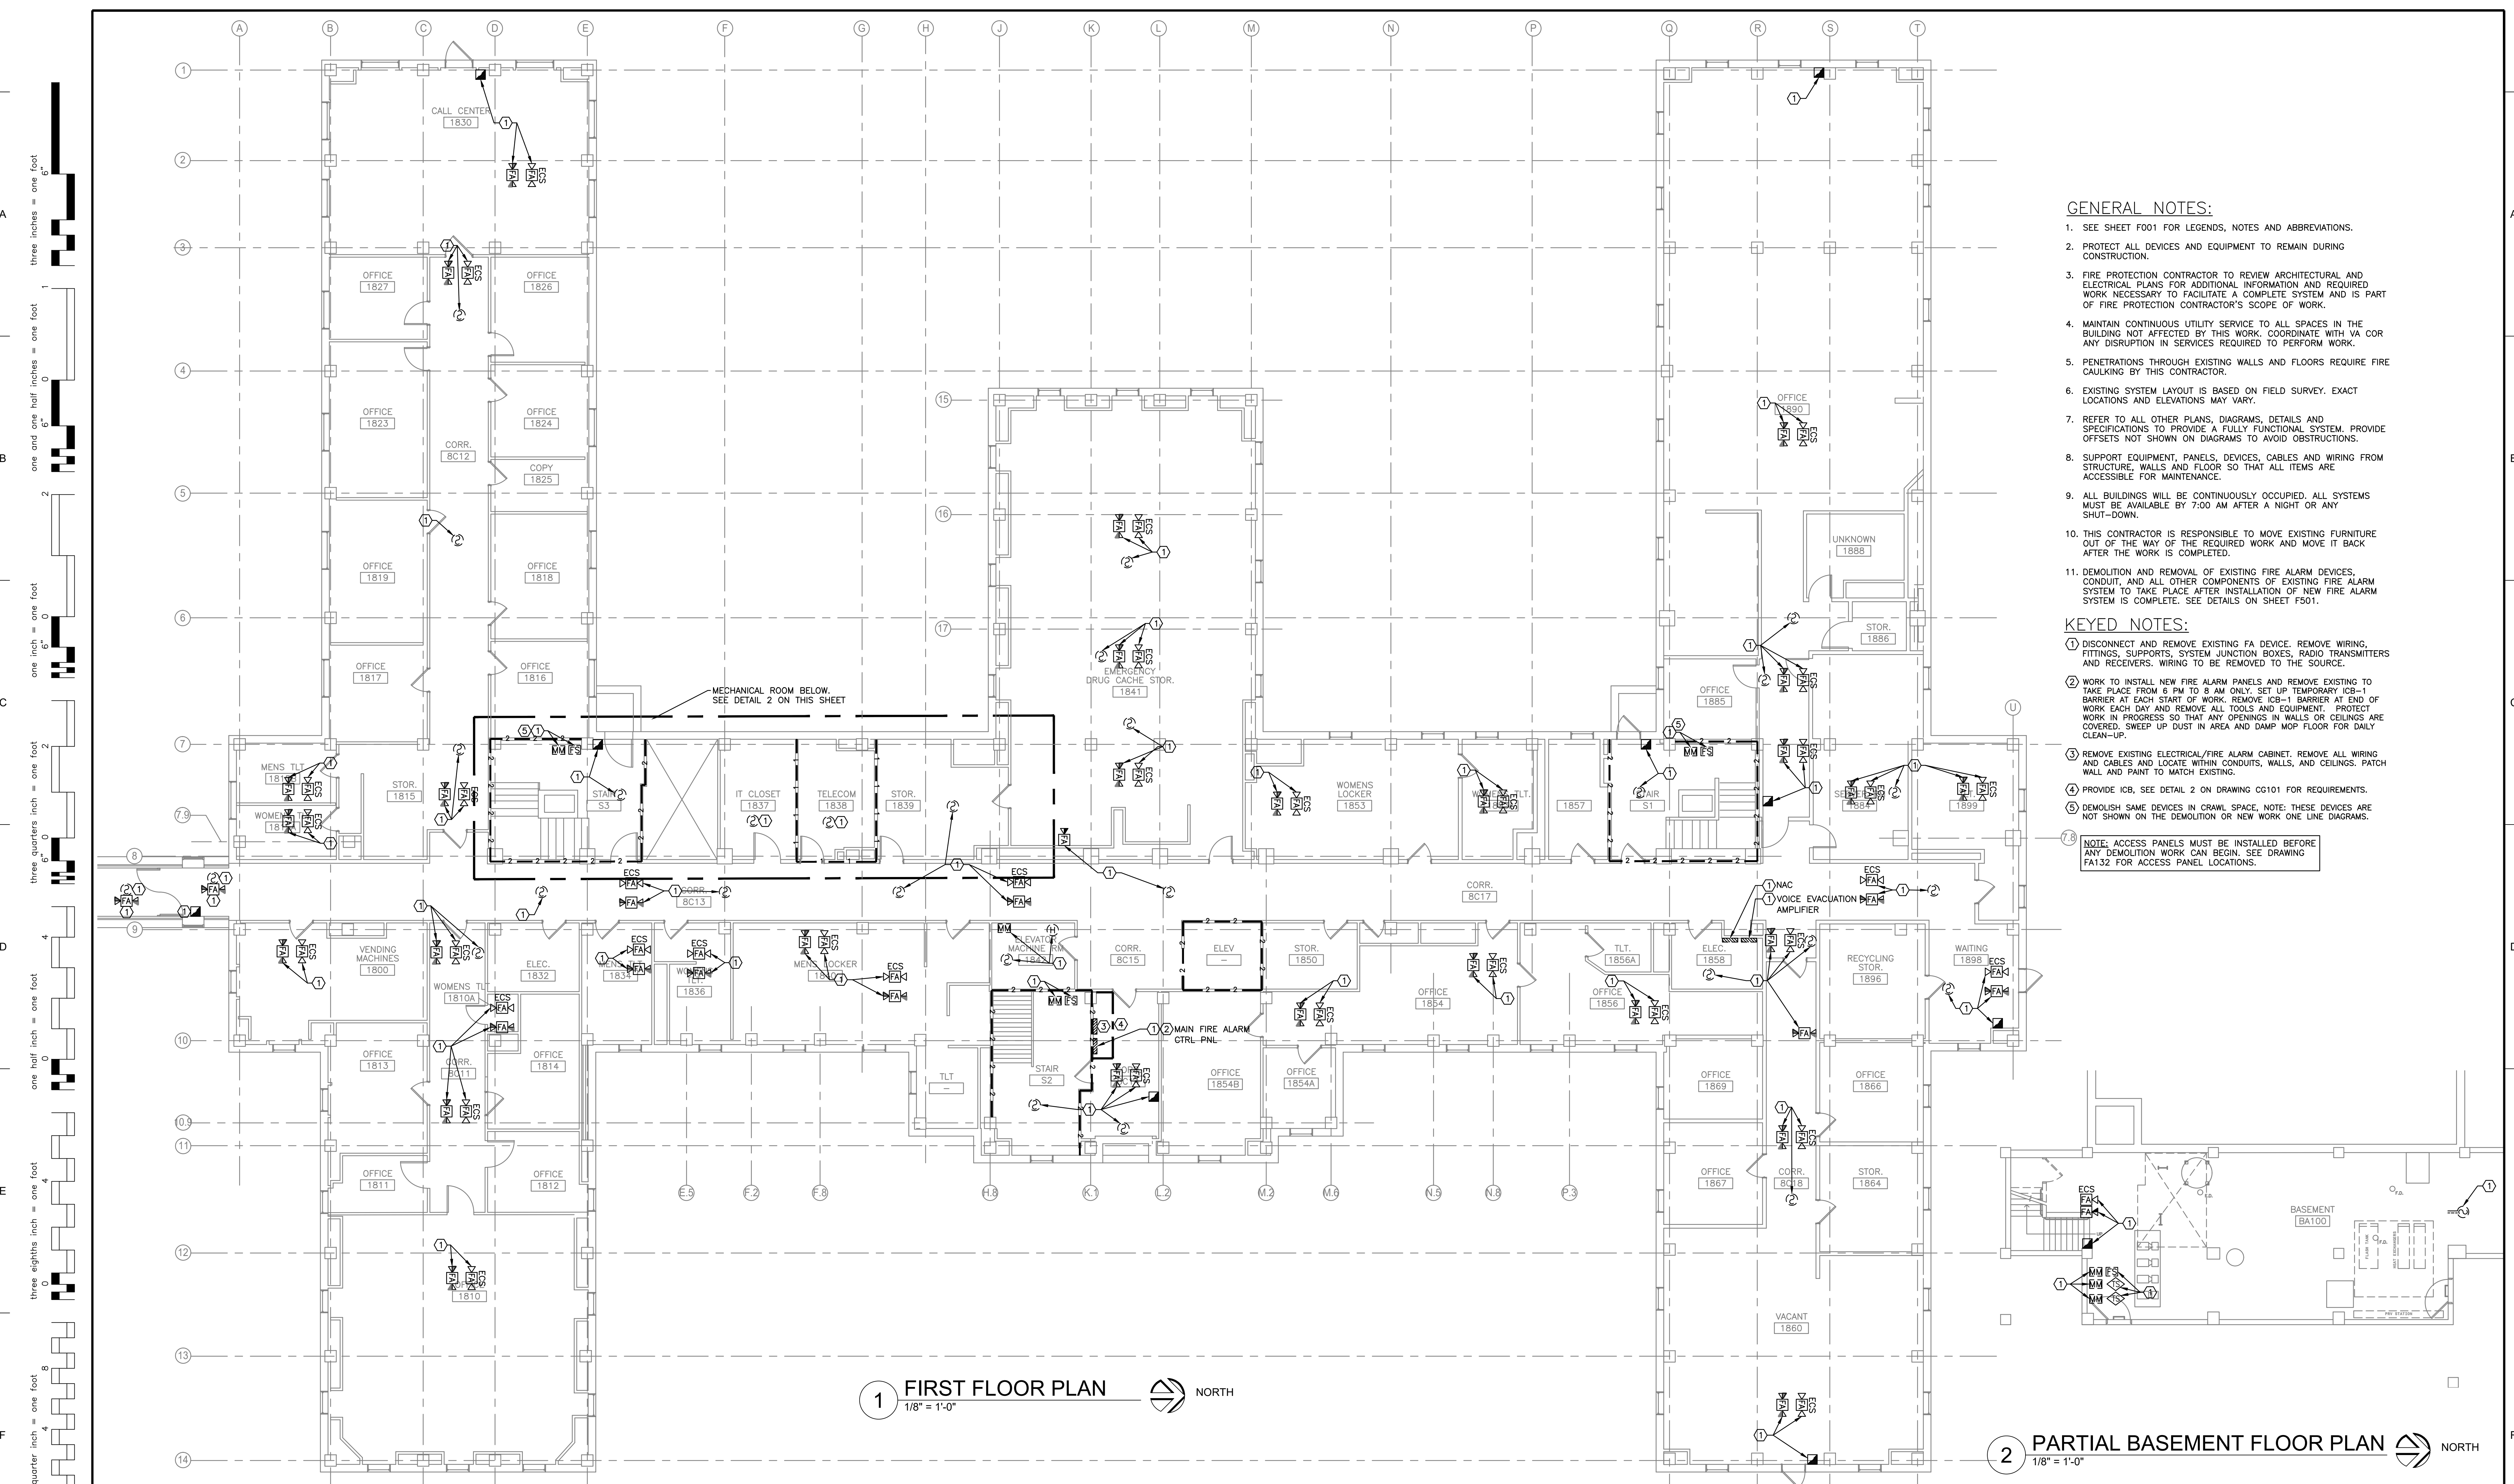

- GENERAL NOTES:**
- SEE SHEET F001 FOR LEGENDS, NOTES AND ABBREVIATIONS.
 - PROTECT ALL DEVICES AND EQUIPMENT TO REMAIN DURING CONSTRUCTION.
 - FIRE PROTECTION CONTRACTOR TO REVIEW ARCHITECTURAL AND ELECTRICAL PLANS FOR ADDITIONAL INFORMATION AND REQUIRED WORK NECESSARY TO FACILITATE A COMPLETE SYSTEM AND IS PART OF FIRE PROTECTION CONTRACTOR'S SCOPE OF WORK.
 - MAINTAIN CONTINUOUS UTILITY SERVICE TO ALL SPACES IN THE BUILDING NOT AFFECTED BY THIS WORK. COORDINATE WITH VA COR ANY DISRUPTION IN SERVICES REQUIRED TO PERFORM WORK.
 - PENETRATIONS THROUGH EXISTING WALLS AND FLOORS REQUIRE FIRE CAULKING BY THIS CONTRACTOR.
 - EXISTING SYSTEM LAYOUT IS BASED ON FIELD SURVEY. EXACT LOCATIONS AND ELEVATIONS MAY VARY.
 - REFER TO ALL OTHER PLANS, DIAGRAMS, DETAILS AND SPECIFICATIONS TO PROVIDE A FULLY FUNCTIONAL SYSTEM. PROVIDE OFFSETS NOT SHOWN ON DIAGRAMS TO AVOID OBSTRUCTIONS.
 - SUPPORT EQUIPMENT, PANELS, DEVICES, CABLES AND WIRING FROM STRUCTURE, WALLS AND FLOOR SO THAT ALL ITEMS ARE ACCESSIBLE FOR MAINTENANCE.
 - ALL BUILDINGS WILL BE CONTINUOUSLY OCCUPIED. ALL SYSTEMS MUST BE AVAILABLE BY 7:00 AM AFTER A NIGHT OR ANY SHUT-DOWN.
 - THIS CONTRACTOR IS RESPONSIBLE TO MOVE EXISTING FURNITURE OUT OF THE WAY OF THE REQUIRED WORK AND MOVE IT BACK AFTER THE WORK IS COMPLETED.
 - DEMOLITION AND REMOVAL OF EXISTING FIRE ALARM DEVICES, CONDUIT, AND ALL OTHER COMPONENTS OF EXISTING FIRE ALARM SYSTEM TO TAKE PLACE AFTER INSTALLATION OF NEW FIRE ALARM SYSTEM IS COMPLETE. SEE DETAILS ON SHEET F501.
- KEYED NOTES:**
- DISCONNECT AND REMOVE EXISTING FA DEVICE. REMOVE WIRING, FITTINGS, SUPPORTS, SYSTEM JUNCTION BOXES, RADIO TRANSMITTERS AND RECEIVERS. WIRING TO BE REMOVED TO THE SOURCE.
 - WORK TO INSTALL NEW FIRE ALARM PANELS AND REMOVE EXISTING TO TAKE PLACE FROM 6 PM TO 8 AM ONLY. SET UP TEMPORARY ICB-1 BARRIER AT EACH START OF WORK. REMOVE ICB-1 BARRIER AT END OF WORK EACH DAY AND REMOVE ALL TOOLS AND EQUIPMENT. PROTECT WORK IN PROGRESS SO THAT ANY OPENINGS IN WALLS OR CEILINGS ARE COVERED. SWEEP UP DUST IN AREA AND DAM MOP FLOOR FOR DAILY CLEAN-UP.
 - REMOVE EXISTING ELECTRICAL/FIRE ALARM CABINET. REMOVE ALL WIRING AND CABLES AND LOCATE WITHIN CONDUITS, WALLS, AND CEILINGS. PATCH WALL AND PAINT TO MATCH EXISTING.
 - PROVIDE ICB, SEE DETAIL 2 ON DRAWING G0101 FOR REQUIREMENTS.
 - DEMOLISH SAME DEVICES IN CRAWL SPACE. NOTE: THESE DEVICES ARE NOT SHOWN ON THE DEMOLITION OR NEW WORK ONE LINE DIAGRAMS.
- NOTE: ACCESS PANELS MUST BE INSTALLED BEFORE ANY DEMOLITION WORK CAN BEGIN. SEE DRAWING FA132 FOR ACCESS PANEL LOCATIONS.

1 FIRST FLOOR PLAN
1/8" = 1'-0"

2 PARTIAL BASEMENT FLOOR PLAN
1/8" = 1'-0"


 VETERANS AFFAIRS MEDICAL CENTER 500 E VETERANS ST TOMAH, WI 54660		CONSULTANTS:		PROJECT LEADER:		Drawing Title FIRE ALARM B408 FIRST FLOOR AND PARTIAL BASEMENT PLANS - DEMOLITION		Project Title UPGRADE FIRE ALARM SYSTEM DESIGN		FINAL BID DOCUMENTS		
				 DESIGN / BUILD SERVICES 1021 N. Superior Ave, Unit 11 Tomah, Wisconsin 54660		Approved: Project Director		Location Tomah, Wisconsin		Project Number 676-22-110		Office of Facilities Management
								Date APRIL 21, 2026		Building Number B408		
								Checked By: HFB		Drawing Number FD132		
Revisions:		Date										

three inches = one foot
one and one half inches = one foot
one inch = one foot
three quarters inch = one foot
one half inch = one foot
three eighths inch = one foot
one quarter inch = one foot
one eighth inch = one foot

A
B
C
D
E
F

A
three inches = one foot
1
one and one half inches = one foot
2
one inch = one foot
3
three quarters inch = one foot
4
one half inch = one foot
5
three eighths inch = one foot
6
one quarter inch = one foot
7
one eighth inch = one foot

A
B
C
D
E
F

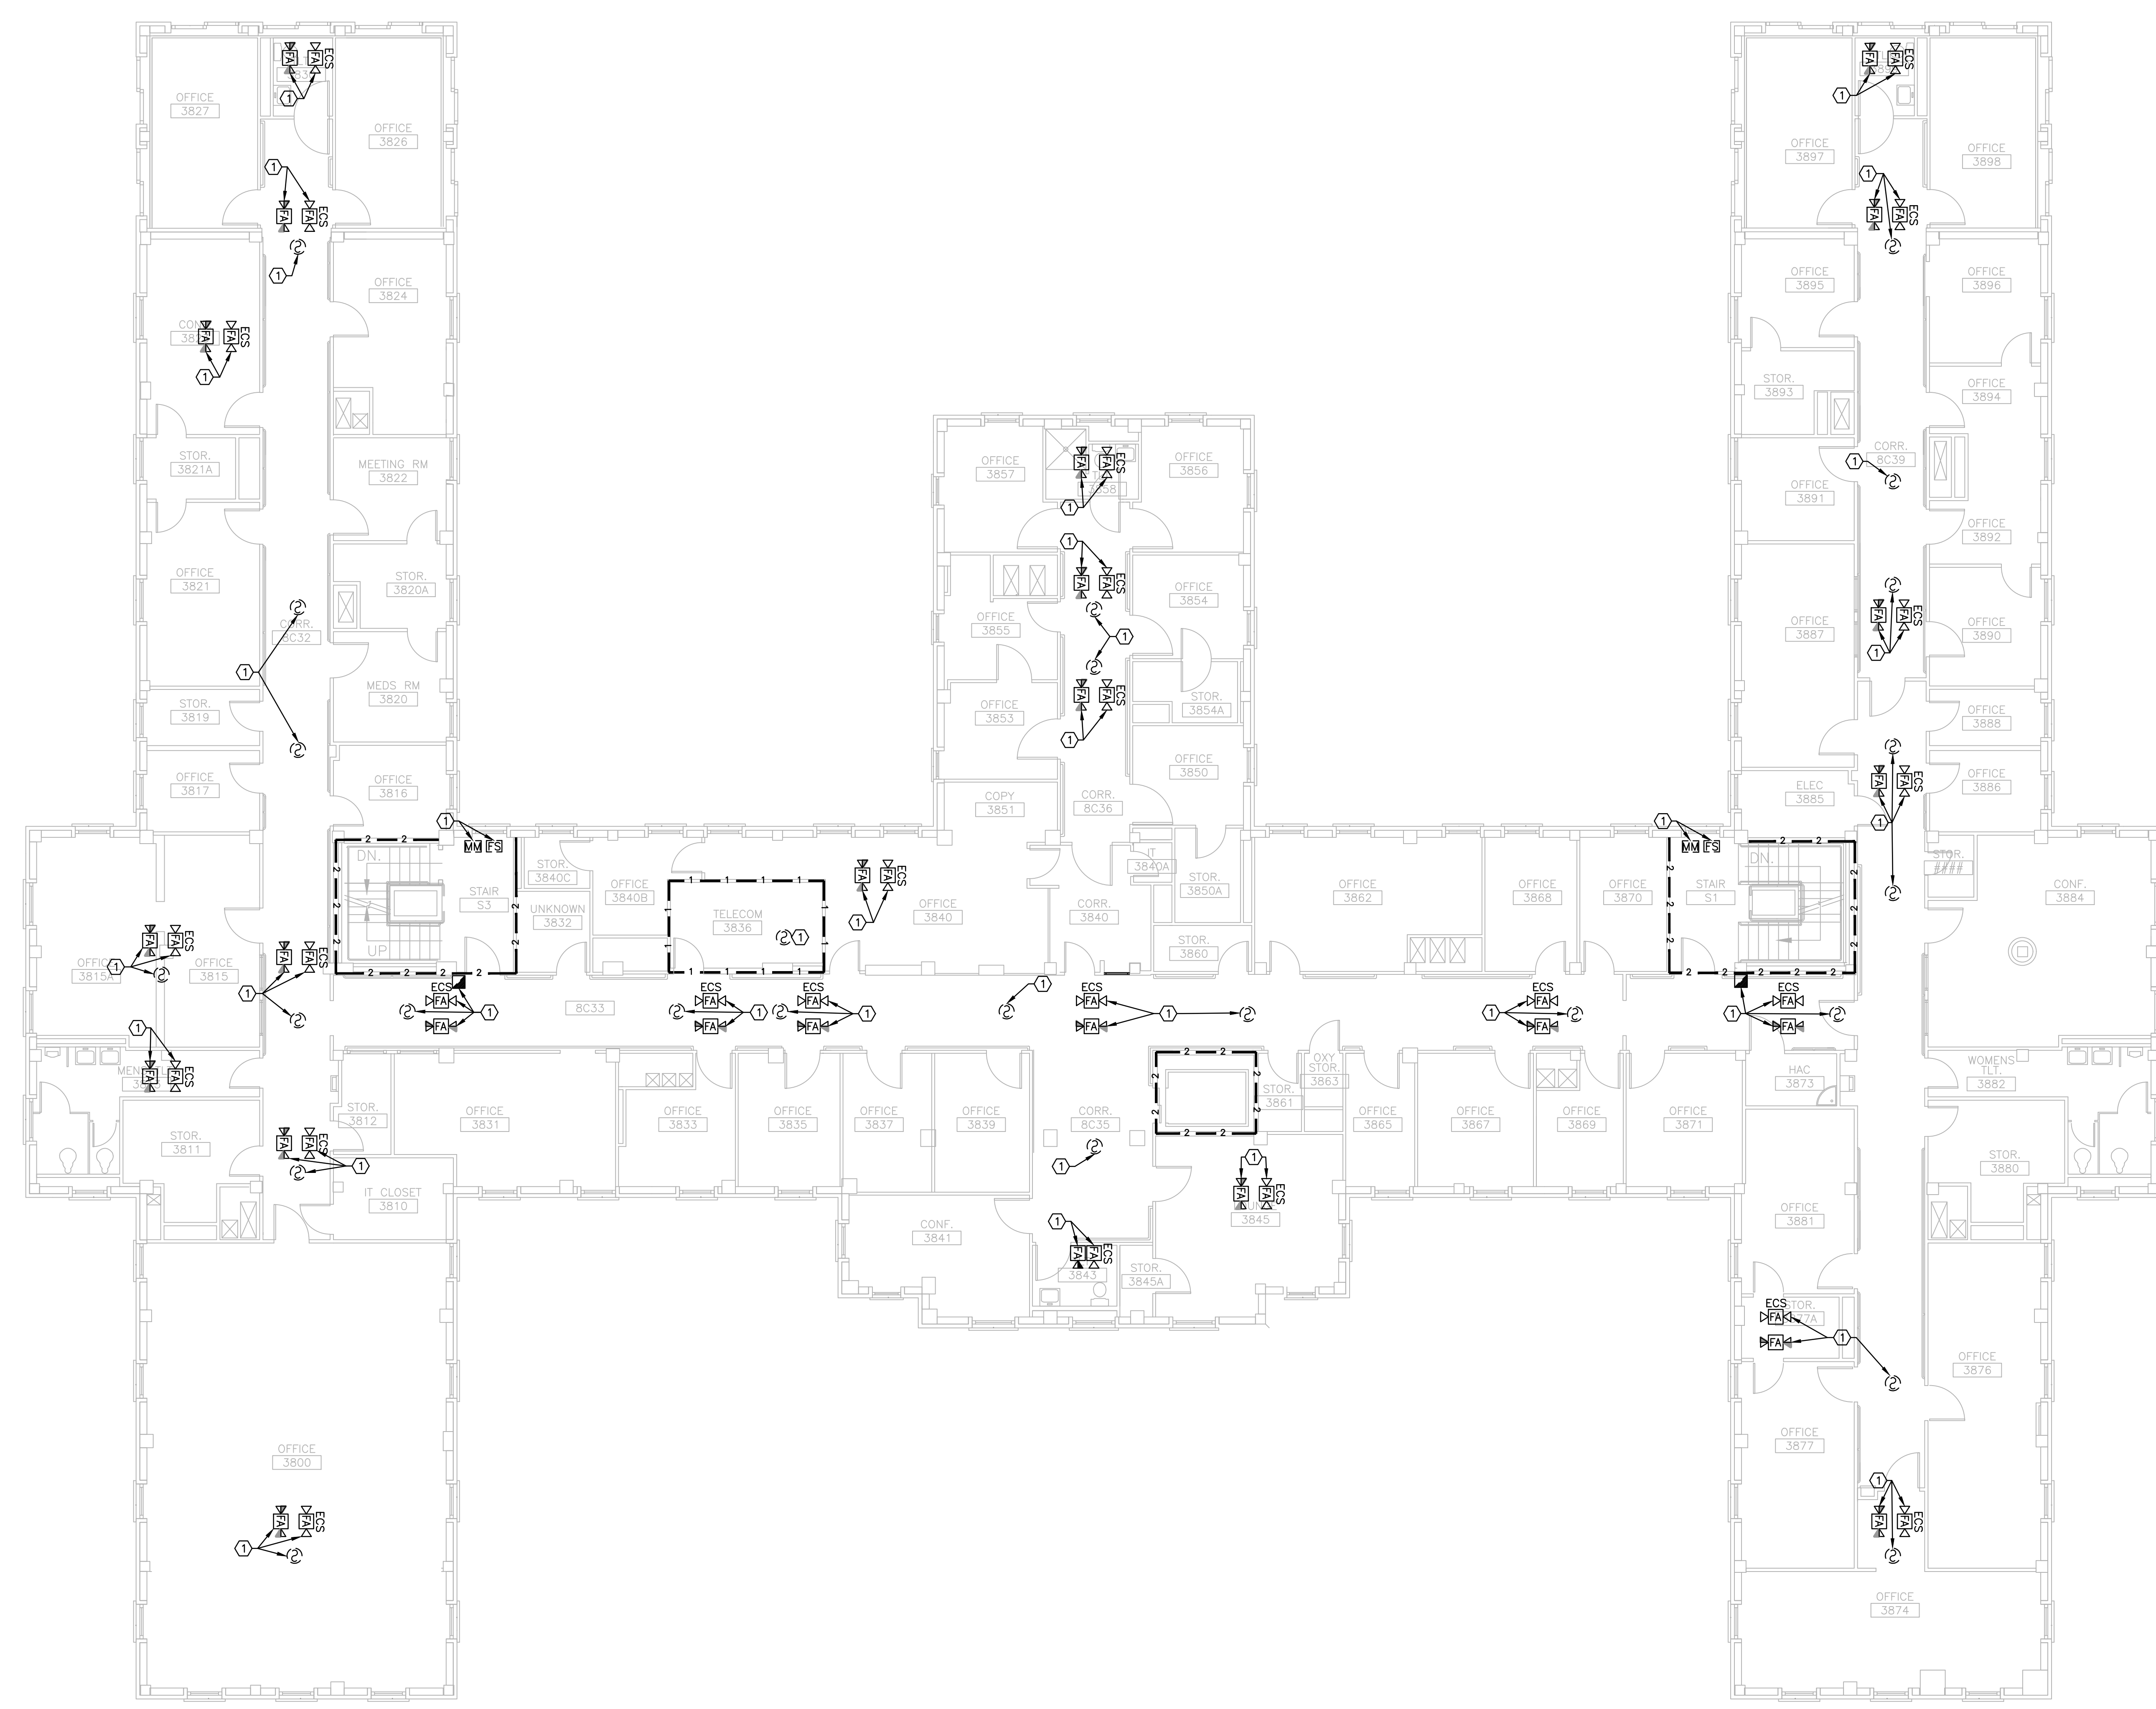

- GENERAL NOTES:**
1. SEE SHEET F001 FOR LEGENDS, NOTES AND ABBREVIATIONS.
 2. PROTECT ALL DEVICES AND EQUIPMENT TO REMAIN DURING CONSTRUCTION.
 3. FIRE PROTECTION CONTRACTOR TO REVIEW ARCHITECTURAL AND ELECTRICAL PLANS FOR ADDITIONAL INFORMATION AND REQUIRED WORK NECESSARY TO FACILITATE A COMPLETE SYSTEM AND IS PART OF FIRE PROTECTION CONTRACTOR'S SCOPE OF WORK.
 4. MAINTAIN CONTINUOUS UTILITY SERVICE TO ALL SPACES IN THE BUILDING NOT AFFECTED BY THIS WORK. COORDINATE WITH VA COR ANY DISRUPTION IN SERVICES REQUIRED TO PERFORM WORK.
 5. PENETRATIONS THROUGH EXISTING WALLS AND FLOORS REQUIRE FIRE CAULKING BY THIS CONTRACTOR.
 6. EXISTING SYSTEM LAYOUT IS BASED ON FIELD SURVEY. EXACT LOCATIONS AND ELEVATIONS MAY VARY.
 7. REFER TO ALL OTHER PLANS, DIAGRAMS, DETAILS AND SPECIFICATIONS TO PROVIDE A FULLY FUNCTIONAL SYSTEM. PROVIDE OFFSETS NOT SHOWN ON DIAGRAMS TO AVOID OBSTRUCTIONS.
 8. SUPPORT EQUIPMENT, PANELS, DEVICES, CABLES AND WIRING FROM STRUCTURE, WALLS AND FLOOR SO THAT ALL ITEMS ARE ACCESSIBLE FOR MAINTENANCE.
 9. ALL BUILDINGS WILL BE CONTINUOUSLY OCCUPIED. ALL SYSTEMS MUST BE AVAILABLE BY 7:00 AM AFTER A NIGHT OR ANY SHUT-DOWN.
 10. THIS CONTRACTOR IS RESPONSIBLE TO MOVE EXISTING FURNITURE OUT OF THE WAY OF THE REQUIRED WORK AND MOVE IT BACK AFTER THE WORK IS COMPLETED.
 11. DEMOLITION AND REMOVAL OF EXISTING FIRE ALARM DEVICES, CONDUIT, AND ALL OTHER COMPONENTS OF EXISTING FIRE ALARM SYSTEM TO TAKE PLACE AFTER INSTALLATION OF NEW FIRE ALARM SYSTEM IS COMPLETE. SEE DETAILS ON SHEET F501.

- KEYED NOTES:**
- ① DISCONNECT AND REMOVE EXISTING FA DEVICE. REMOVE WIRING, FITTINGS, SUPPORTS, SYSTEM JUNCTION BOXES, RADIO TRANSMITTERS AND RECEIVERS. WIRING TO BE REMOVED TO THE SOURCE.

NOTE: ACCESS PANELS MUST BE INSTALLED BEFORE ANY DEMOLITION WORK CAN BEGIN. SEE DRAWING FA134 FOR ACCESS PANEL LOCATIONS.

1 **THIRD FLOOR PLAN**
1/8" = 1'-0" NORTH

 VETERANS AFFAIRS MEDICAL CENTER 500 E VETERANS ST TOMAH, WI 54660			CONSULTANTS:	PROJECT LEADER:  PCG DESIGN / BUILD SERVICES 1021 N. Superior Ave., Unit 11 Tomah, Wisconsin 54660	Drawing Title FIRE ALARM B408 THIRD FLOOR PLAN - DEMOLITION Approved: Project Director	Project Title UPGRADE FIRE ALARM SYSTEM DESIGN Location Tomah, Wisconsin Date APRIL 21, 2026 Checked By: HFB Drawn By: JMD	FINAL BID DOCUMENTS Project Number 676-22-110 Building Number B408 Drawing Number FD134 Office of Facilities Management 		
Revisions:		Date							

three inches = one foot

one and one half inches = one foot

one inch = one foot


three quarters inch = one foot

one half inch = one foot

three eighths inch = one foot

one quarter inch = one foot

one eighth inch = one foot

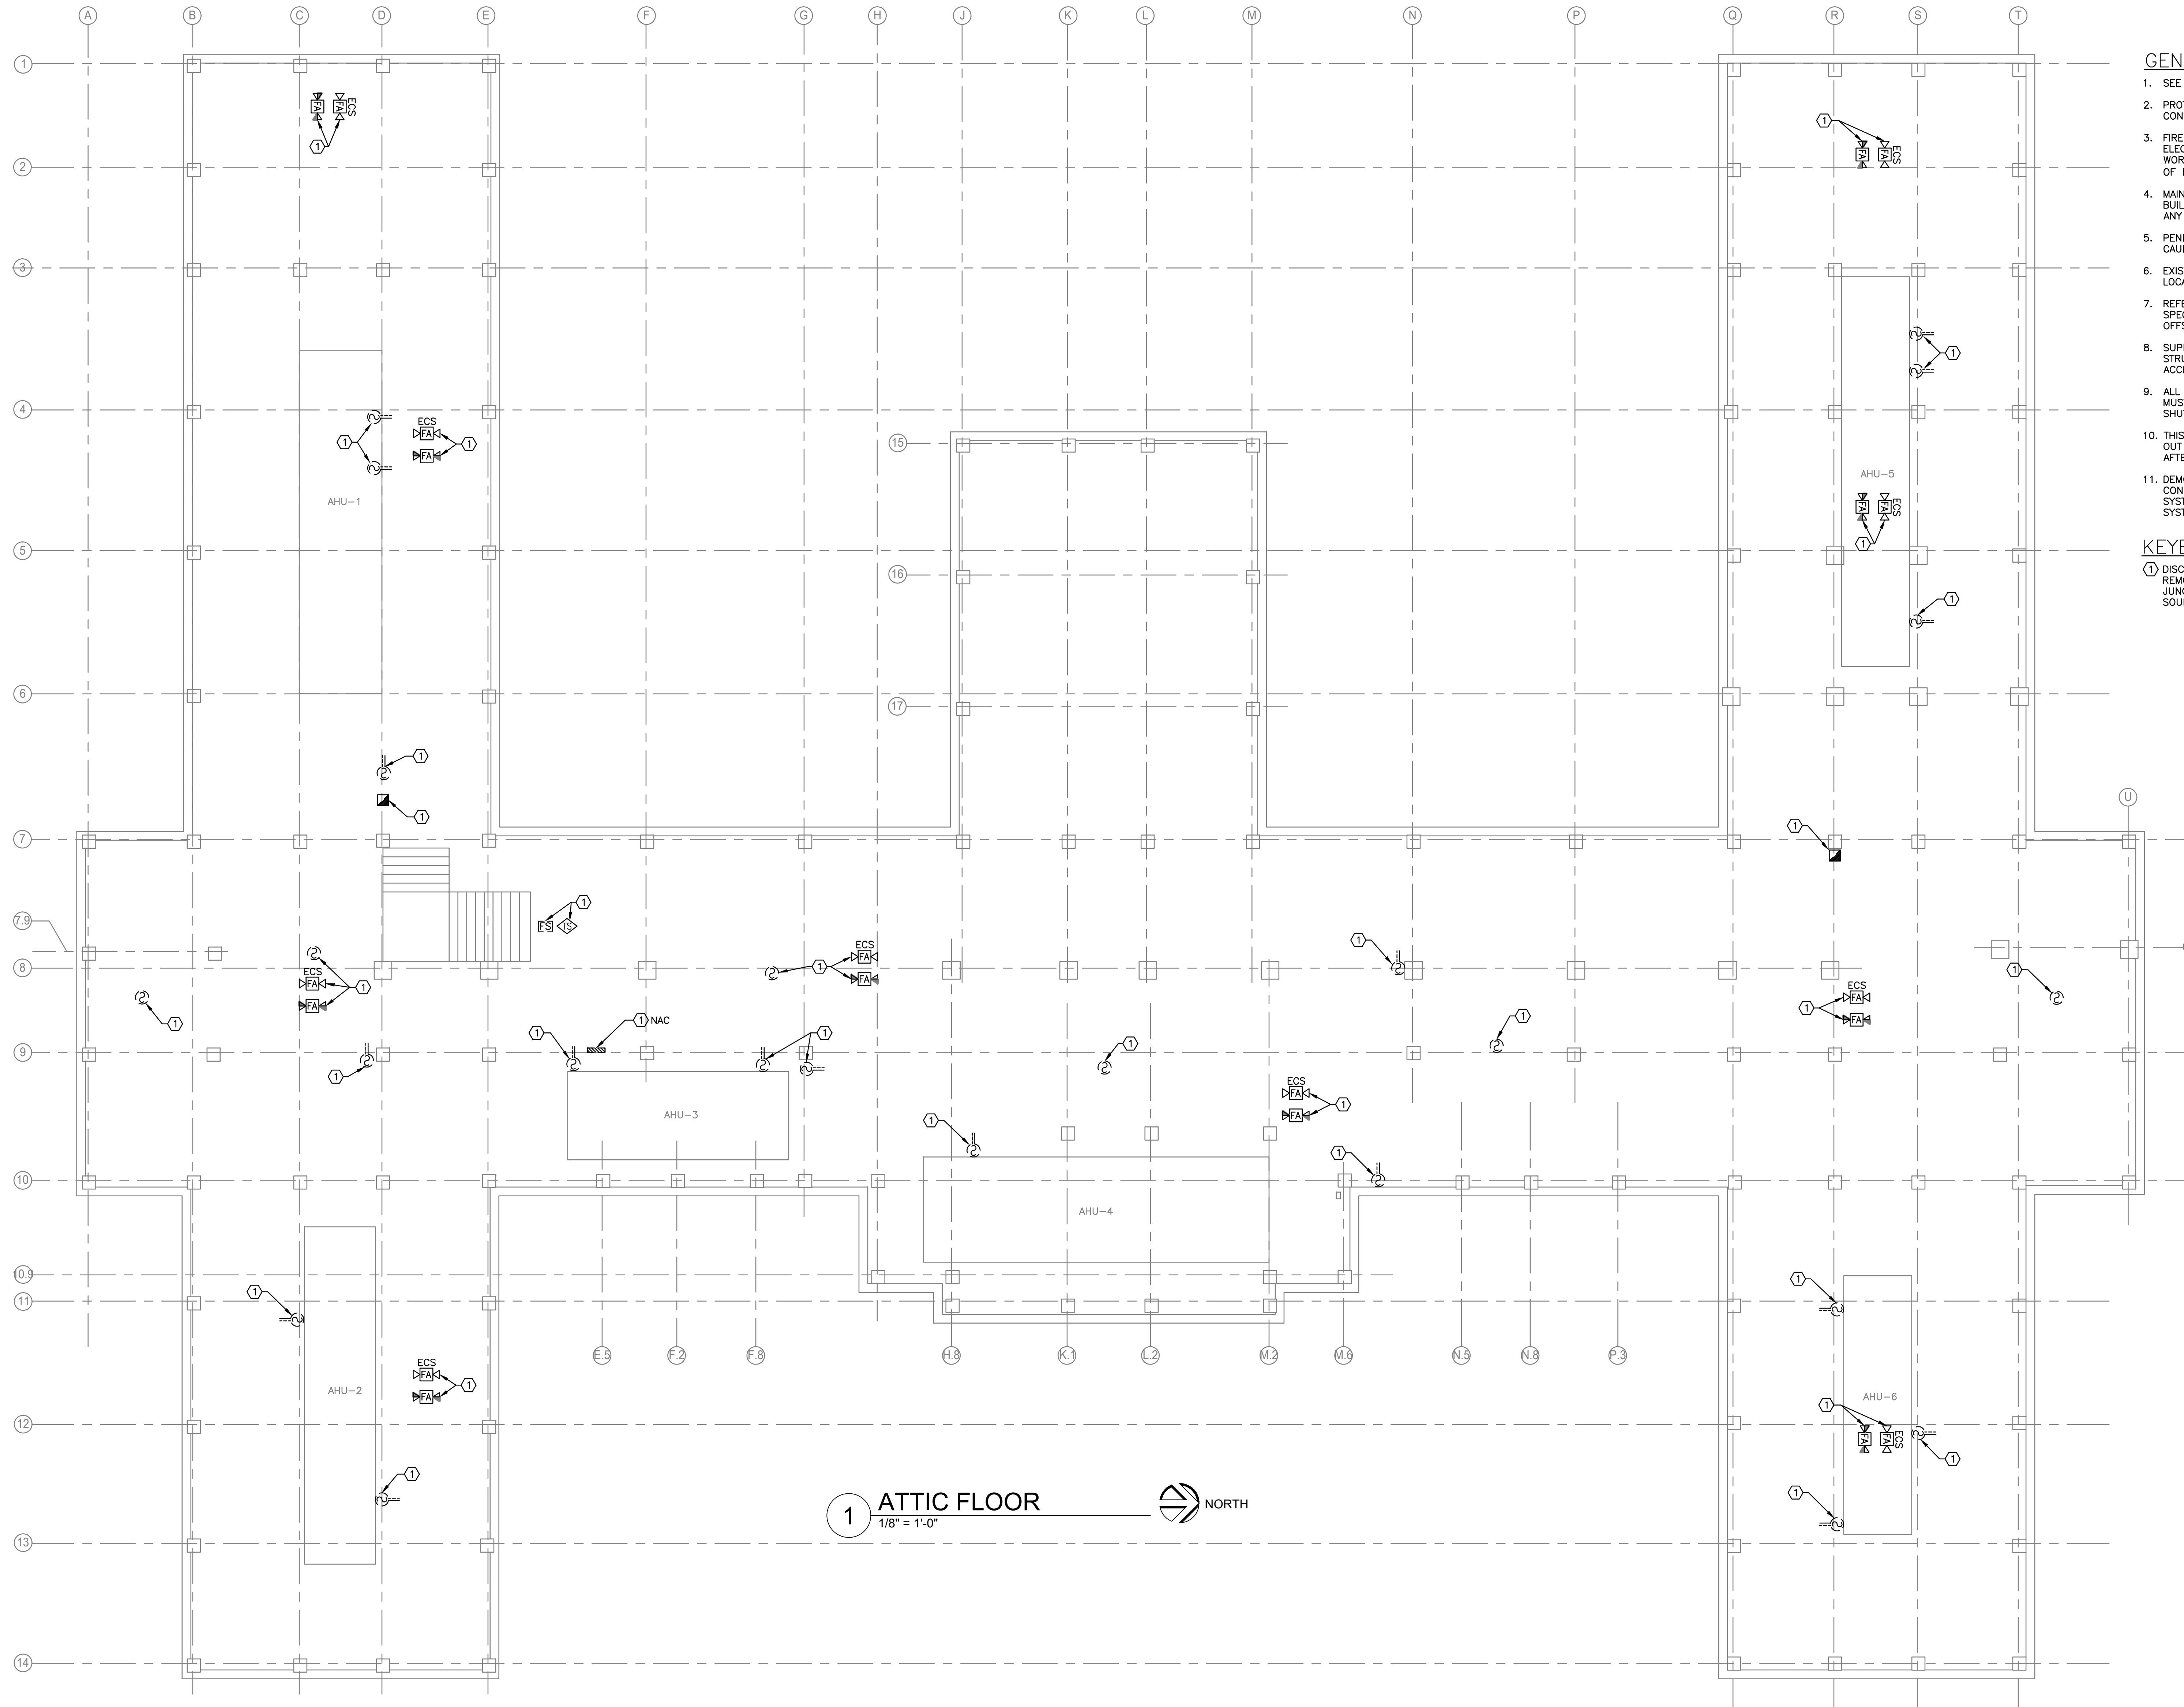

- GENERAL NOTES:**
- SEE SHEET F001 FOR LEGENDS, NOTES AND ABBREVIATIONS.
 - PROTECT ALL DEVICES AND EQUIPMENT TO REMAIN DURING CONSTRUCTION.
 - FIRE PROTECTION CONTRACTOR TO REVIEW ARCHITECTURAL AND ELECTRICAL PLANS FOR ADDITIONAL INFORMATION AND REQUIRED WORK NECESSARY TO FACILITATE A COMPLETE SYSTEM AND IS PART OF FIRE PROTECTION CONTRACTOR'S SCOPE OF WORK.
 - MAINTAIN CONTINUOUS UTILITY SERVICE TO ALL SPACES IN THE BUILDING NOT AFFECTED BY THIS WORK. COORDINATE WITH VA COR ANY DISRUPTION IN SERVICES REQUIRED TO PERFORM WORK.
 - PENETRATIONS THROUGH EXISTING WALLS AND FLOORS REQUIRE FIRE CAULKING BY THIS CONTRACTOR.
 - EXISTING SYSTEM LAYOUT IS BASED ON FIELD SURVEY. EXACT LOCATIONS AND ELEVATIONS MAY VARY.
 - REFER TO ALL OTHER PLANS, DIAGRAMS, DETAILS AND SPECIFICATIONS TO PROVIDE A FULLY FUNCTIONAL SYSTEM. PROVIDE OFFSETS NOT SHOWN ON DIAGRAMS TO AVOID OBSTRUCTIONS.
 - SUPPORT EQUIPMENT, PANELS, DEVICES, CABLES AND WIRING FROM STRUCTURE, WALLS AND FLOOR SO THAT ALL ITEMS ARE ACCESSIBLE FOR MAINTENANCE.
 - ALL BUILDINGS WILL BE CONTINUOUSLY OCCUPIED. ALL SYSTEMS MUST BE AVAILABLE BY 7:00 AM AFTER A NIGHT OR ANY SHUT-DOWN.
 - THIS CONTRACTOR IS RESPONSIBLE TO MOVE EXISTING FURNITURE OUT OF THE WAY OF THE REQUIRED WORK AND MOVE IT BACK AFTER THE WORK IS COMPLETED.
 - DEMOLITION AND REMOVAL OF EXISTING FIRE ALARM DEVICES, CONDUIT, AND ALL OTHER COMPONENTS OF EXISTING FIRE ALARM SYSTEM TO TAKE PLACE AFTER INSTALLATION OF NEW FIRE ALARM SYSTEM IS COMPLETE. SEE DETAILS ON SHEET F501.
- KEYED NOTES:**
- ① DISCONNECT AND REMOVE EXISTING FA DEVICE. REMOVE WIRING, FITTINGS, SUPPORTS, AND SYSTEM JUNCTION BOXES. WIRING TO BE REMOVED TO THE SOURCE.

Revisions:

Date:

VETERANS AFFAIRS
MEDICAL CENTER
500 E VETERANS ST
TOMAH, WI 54660

CONSULTANTS:

PROJECT LEADER:

DESIGN / BUILD SERVICES
1021 N. Superior Ave, Unit 11
Tomah, Wisconsin 54660

Drawing Title

FIRE ALARM
B408 ATTIC PLAN -
DEMOLITION

Approved: Project Director

Project Title

UPGRADE FIRE ALARM
SYSTEM DESIGN

Location
Tomah, Wisconsin

Date
APRIL 21, 2026

Checked By:
HFB

Drawn By:
JMD

FINAL BID DOCUMENTS

Project Number
676-22-110

Building Number
B408

Drawing Number
FD135

Office of
Facilities
Management

Department of
Veterans Affairs

three inches = one foot

one and one half inches = one foot

one inch = one foot


three quarters inch = one foot

one half inch = one foot

three eighths inch = one foot

one quarter inch = one foot

one eighth inch = one foot

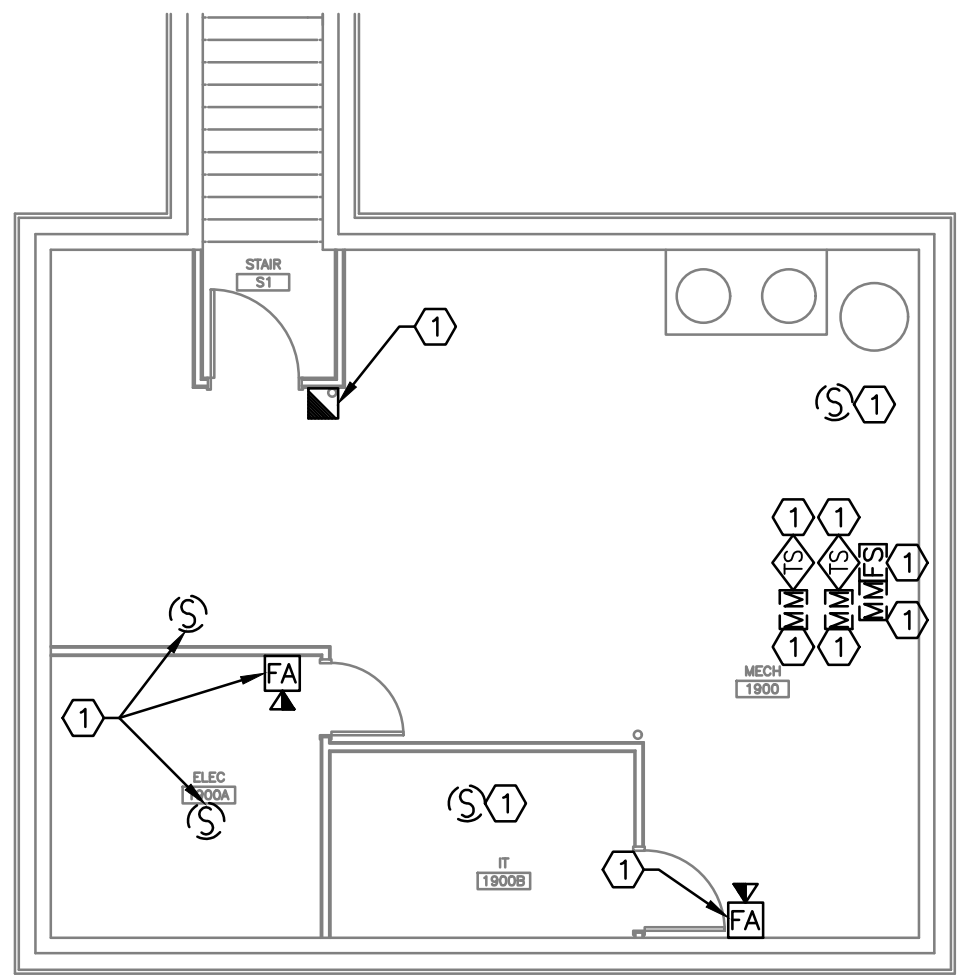


2

BASEMENT FLOOR PLAN

1/8" = 1'-0"

NORTH

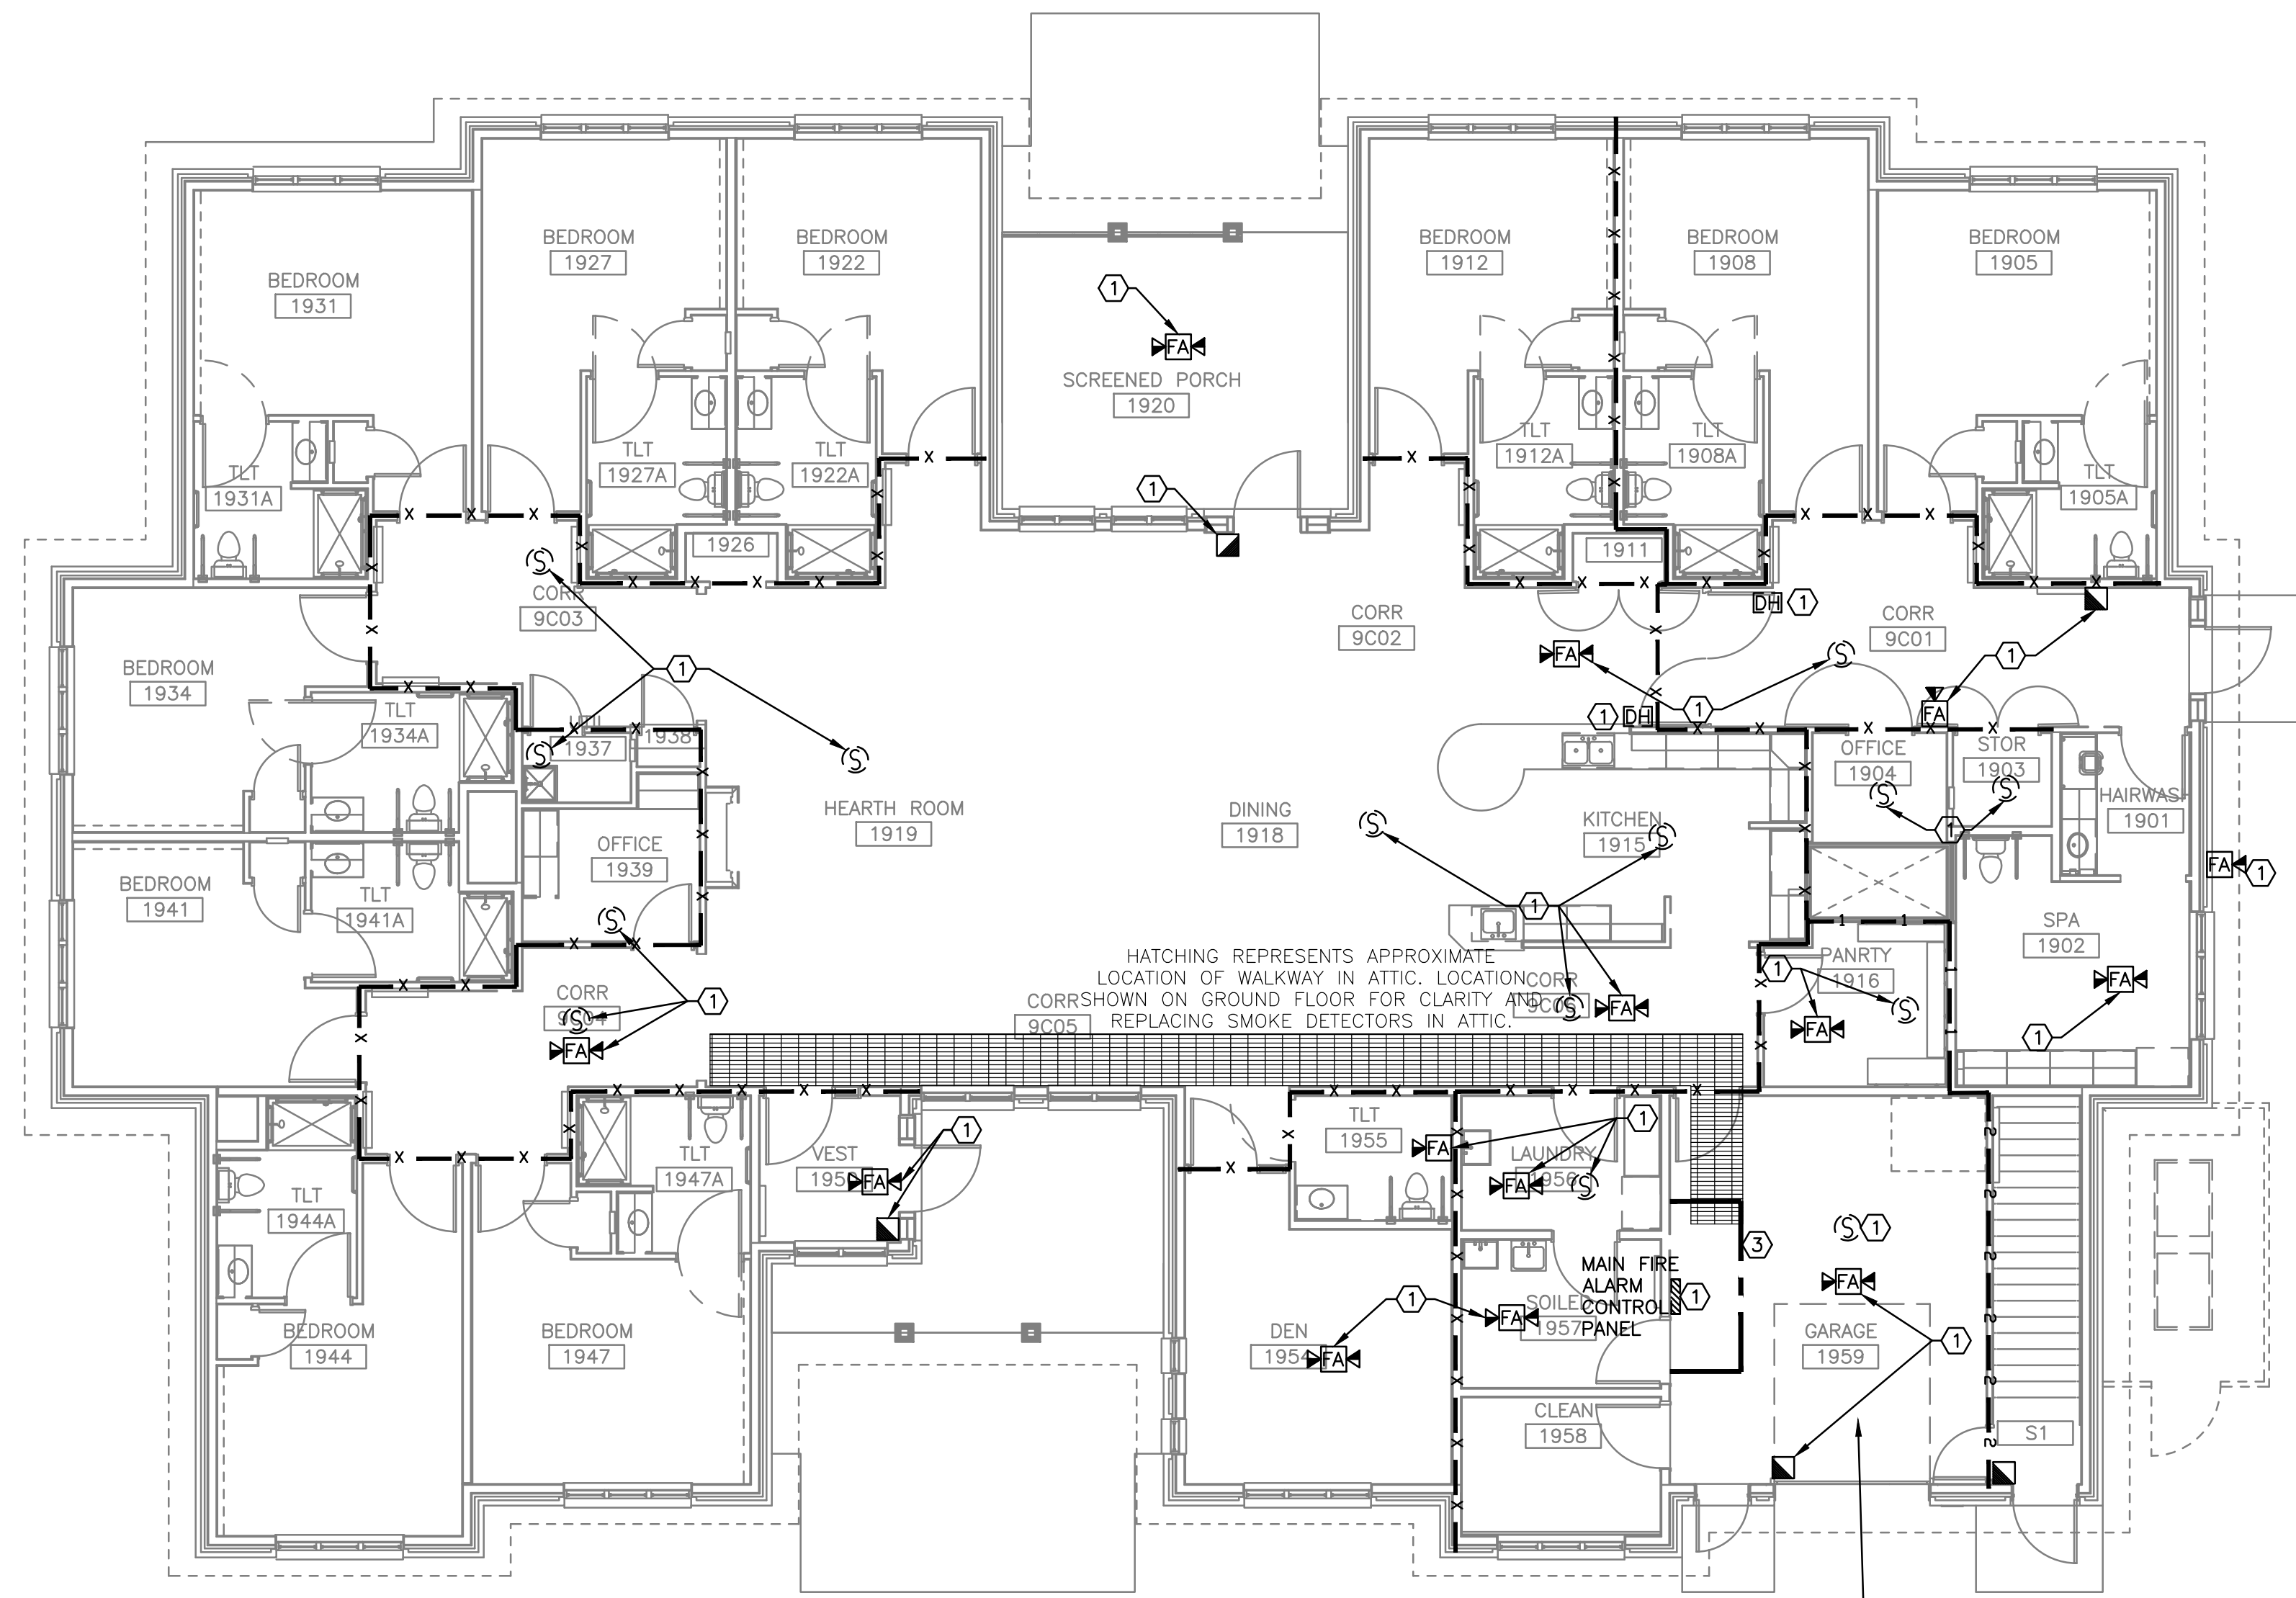

1

FIRST FLOOR PLAN


1/8" = 1'-0"

NORTH


- GENERAL NOTES:**
- SEE SHEET F001 FOR LEGENDS, NOTES AND ABBREVIATIONS.
 - PROTECT ALL DEVICES AND EQUIPMENT TO REMAIN DURING CONSTRUCTION.
 - FIRE PROTECTION CONTRACTOR TO REVIEW ARCHITECTURAL AND ELECTRICAL PLANS FOR ADDITIONAL INFORMATION AND REQUIRED WORK NECESSARY TO FACILITATE A COMPLETE SYSTEM AND IS PART OF FIRE PROTECTION CONTRACTOR'S SCOPE OF WORK.
 - MAINTAIN CONTINUOUS UTILITY SERVICE TO ALL SPACES IN THE BUILDING NOT AFFECTED BY THIS WORK. COORDINATE WITH VA COR ANY DISRUPTION IN SERVICES REQUIRED TO PERFORM WORK.
 - PENETRATIONS THROUGH EXISTING WALLS AND FLOORS REQUIRE FIRE CAULKING BY THIS CONTRACTOR.
 - EXISTING SYSTEM LAYOUT IS BASED ON FIELD SURVEY. EXACT LOCATIONS AND ELEVATIONS MAY VARY.
 - REFER TO ALL OTHER PLANS, DIAGRAMS, DETAILS AND SPECIFICATIONS TO PROVIDE A FULLY FUNCTIONAL SYSTEM. PROVIDE OFFSETS NOT SHOWN ON DIAGRAMS TO AVOID OBSTRUCTIONS.
 - SUPPORT EQUIPMENT, PANELS, DEVICES, CABLES AND WIRING FROM STRUCTURE, WALLS AND FLOOR SO THAT ALL ITEMS ARE ACCESSIBLE FOR MAINTENANCE.
 - ALL BUILDINGS WILL BE CONTINUOUSLY OCCUPIED. ALL SYSTEMS MUST BE AVAILABLE BY 7:00 AM AFTER A NIGHT OR ANY SHUT-DOWN.
 - THIS CONTRACTOR IS RESPONSIBLE TO MOVE EXISTING FURNITURE OUT OF THE WAY OF THE REQUIRED WORK AND MOVE IT BACK AFTER THE WORK IS COMPLETED.
 - DEMOLITION AND REMOVAL OF EXISTING FIRE ALARM DEVICES, CONDUIT, AND ALL OTHER COMPONENTS OF EXISTING FIRE ALARM SYSTEM TO TAKE PLACE AFTER INSTALLATION OF NEW FIRE ALARM SYSTEM IS COMPLETE. SEE DETAILS ON SHEET F501.
- KEYED NOTES:**
- DISCONNECT AND REMOVE EXISTING FA DEVICE. REMOVE WIRING, FITTINGS, SUPPORTS, SYSTEM JUNCTION BOXES, RADIO TRANSMITTERS AND RECEIVERS. WIRING TO BE REMOVED TO THE SOURCE.
 - WORK TO INSTALL NEW FIRE ALARM PANELS AND REMOVE EXISTING TO TAKE PLACE DURING NORMAL WORK HOURS. SET UP TEMPORARY ICB-1 BARRIER. REMOVE ICB-1 BARRIER AT END OF THE WORK. REMOVE ALL TOOLS AND EQUIPMENT DAILY. PROTECT WORK IN PROGRESS SO THAT ANY OPENINGS IN WALLS OR CEILINGS ARE COVERED. SWEEP UP DUST IN AREA AND DAMP MOP FLOOR FOR DAILY CLEAN-UP.
 - PROVIDE ICB, SEE DETAIL 2 ON DRAWING GC101 FOR REQUIREMENTS.
- NOTE: ACCESS PANELS MUST BE INSTALLED BEFORE ANY DEMOLITION WORK CAN BEGIN. SEE DRAWING FA136 FOR ACCESS PANEL LOCATIONS.

		 VETERANS AFFAIRS MEDICAL CENTER 500 E VETERANS ST TOMAH, WI 54660		CONSULTANTS:		PROJECT LEADER:		Drawing Title FIRE ALARM B409 FIRST FLOOR AND BASEMENT PLANS - DEMOLITION		Project Title UPGRADE FIRE ALARM SYSTEM DESIGN		Project Number 676-22-110		Office of Facilities Management		 Department of Veterans Affairs	
						 PCG DESIGN / BUILD SERVICES 1021 N. Superior Ave, Unit 11 Tomah, Wisconsin 54660		Approved: Project Director		Location Tomah, Wisconsin		Drawing Number FD136					
										Date APRIL 21, 2026		Checked By: HFB		Drawn By: JMD			
Revisions:				Date													

three inches = one foot
one and one half inches = one foot
one inch = one foot
three quarters inch = one foot
one half inch = one foot
three eighths inch = one foot
one quarter inch = one foot
one eighth inch = one foot

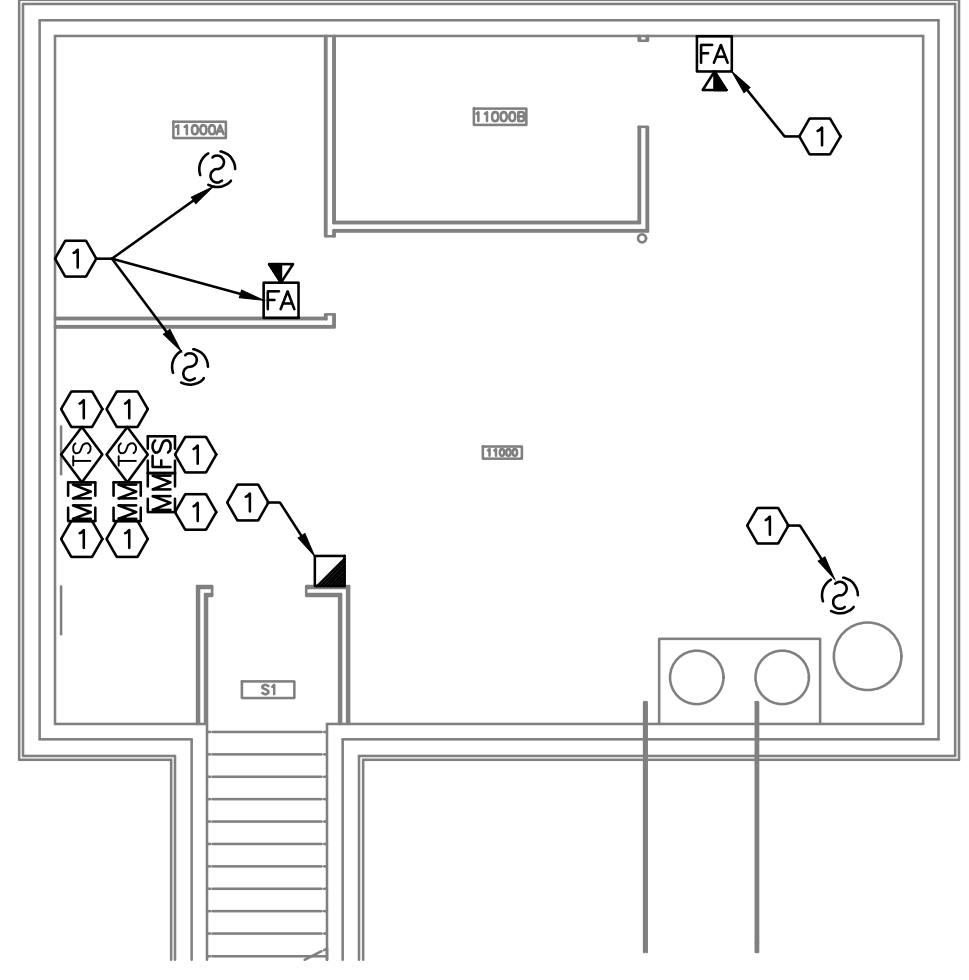

2 BASEMENT FLOOR PLAN
1/8" = 1'-0"

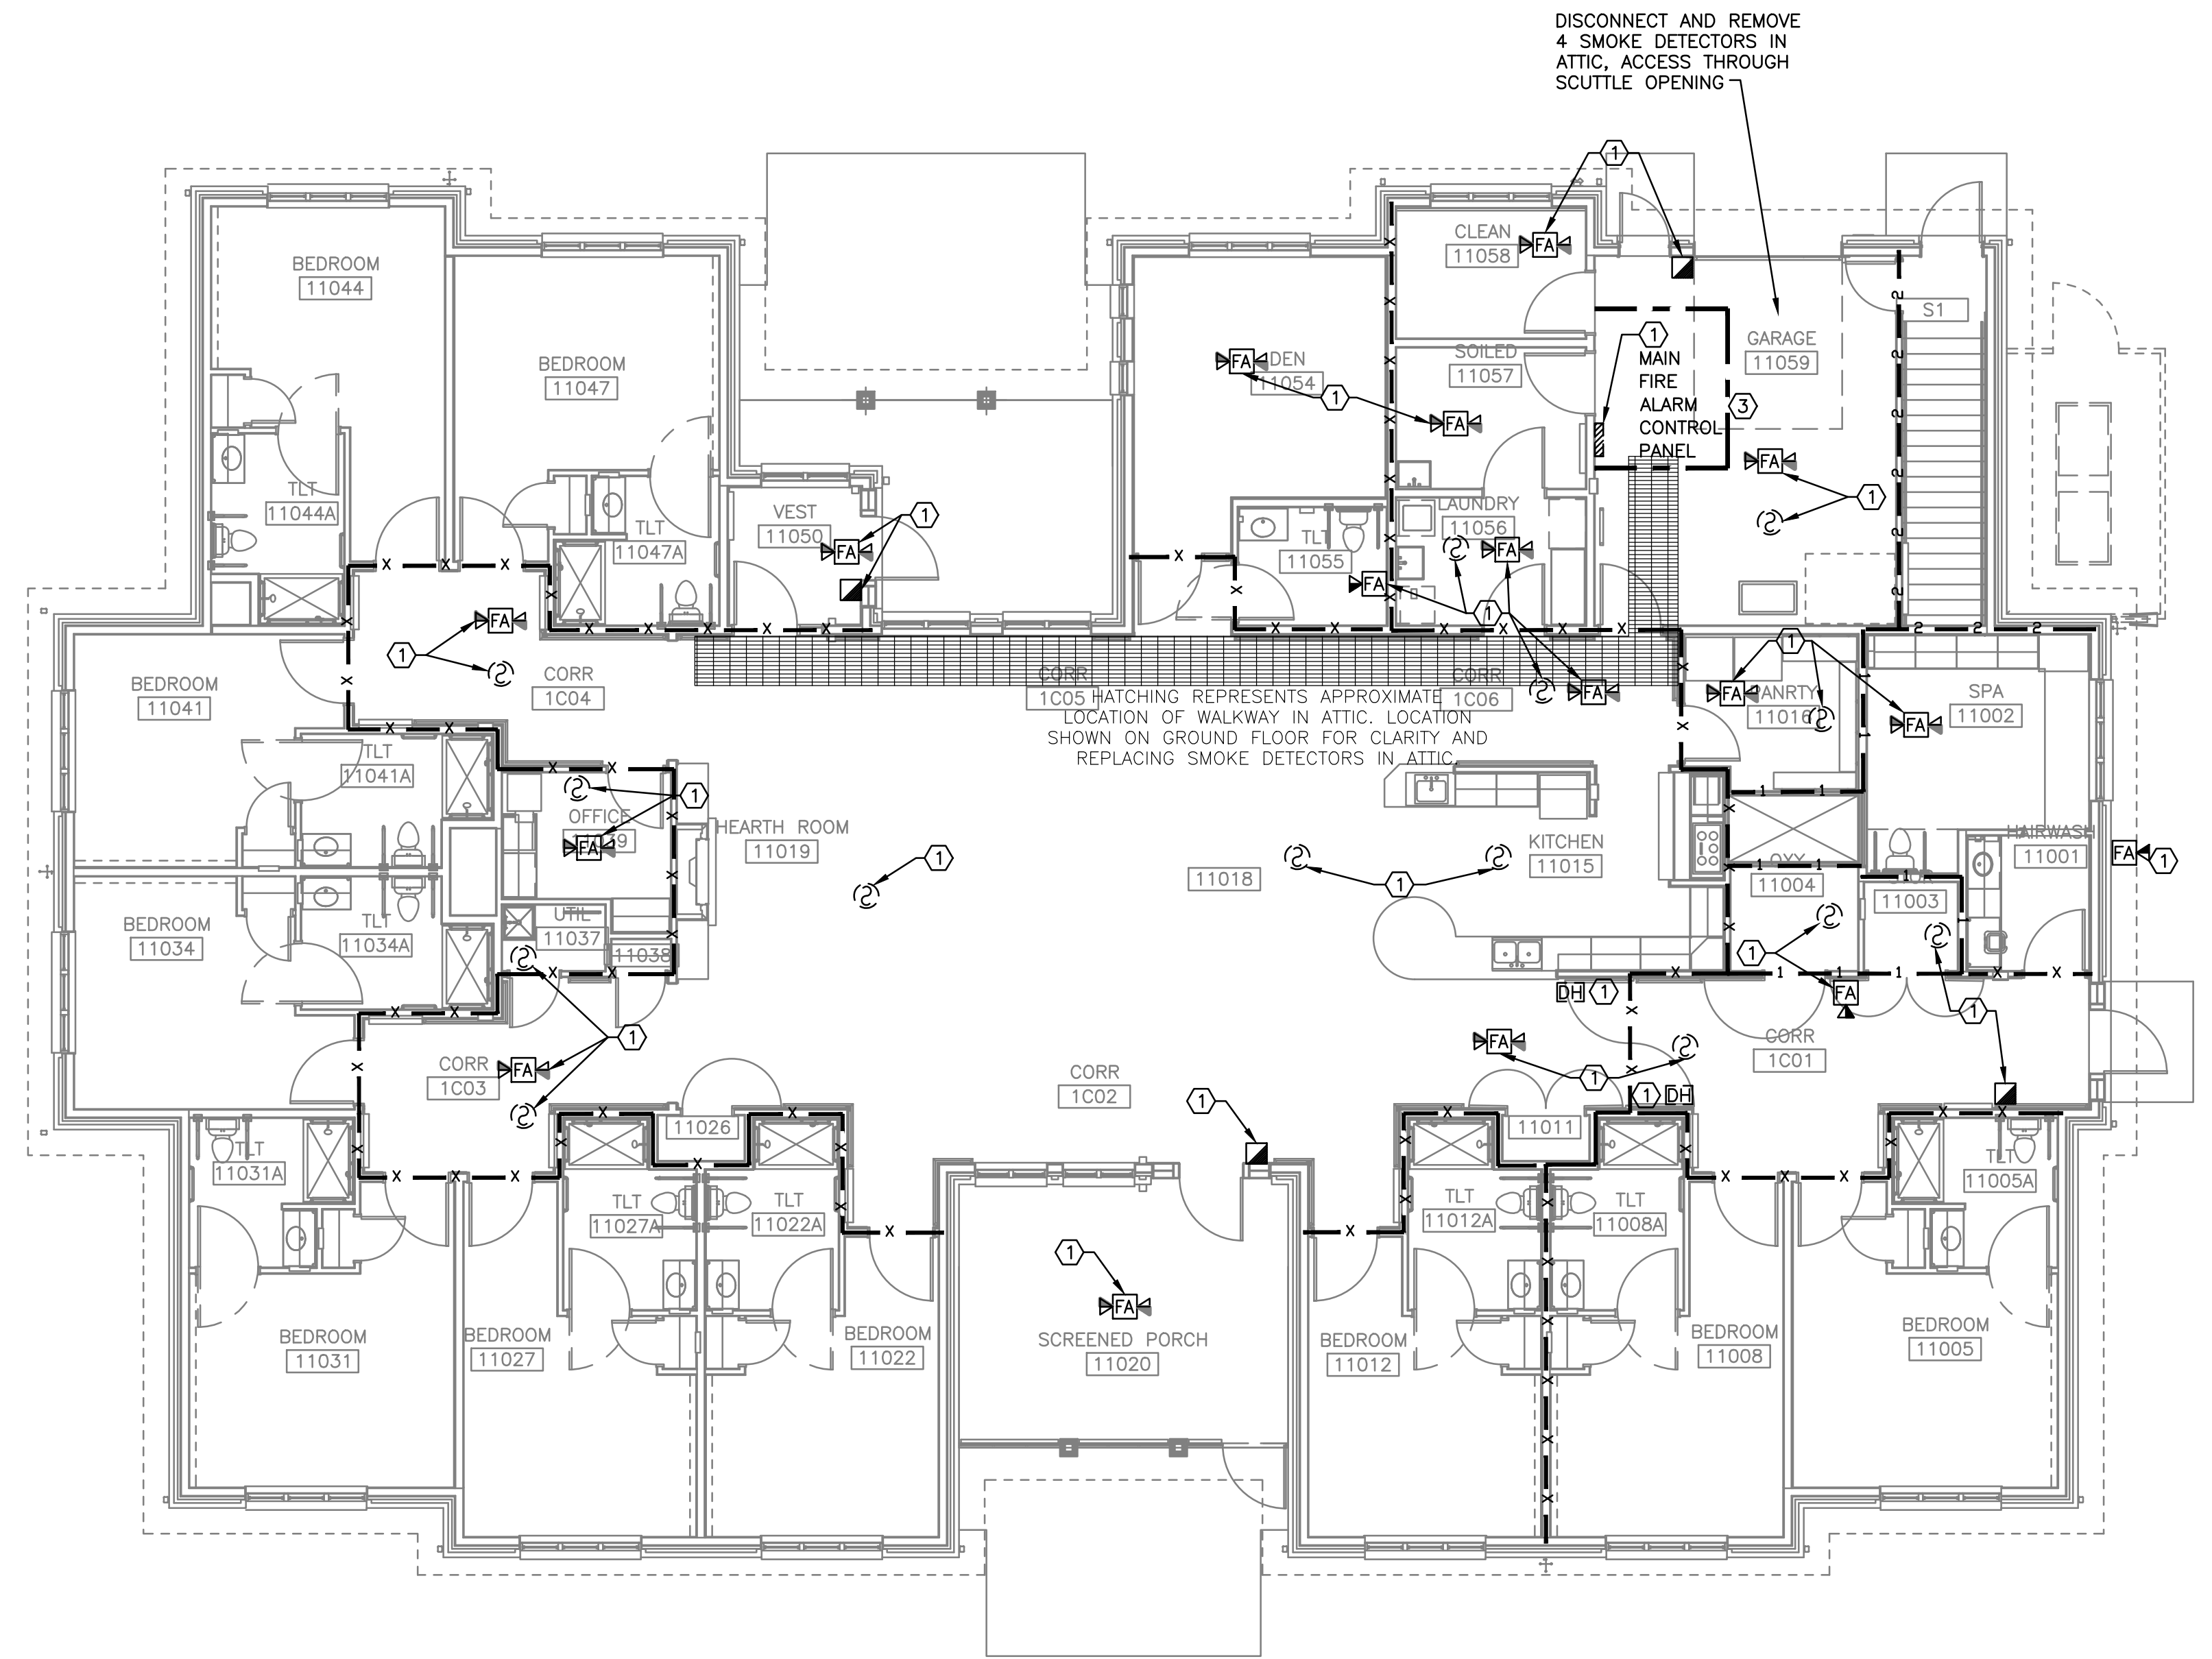


1 FIRST FLOOR PLAN
1/8" = 1'-0"


- GENERAL NOTES:
- SEE SHEET F001 FOR LEGENDS, NOTES AND ABBREVIATIONS.
 - PROTECT ALL DEVICES AND EQUIPMENT TO REMAIN DURING CONSTRUCTION.
 - FIRE PROTECTION CONTRACTOR TO REVIEW ARCHITECTURAL AND ELECTRICAL PLANS FOR ADDITIONAL INFORMATION AND REQUIRED WORK NECESSARY TO FACILITATE A COMPLETE SYSTEM AND IS PART OF FIRE PROTECTION CONTRACTOR'S SCOPE OF WORK.
 - MAINTAIN CONTINUOUS UTILITY SERVICE TO ALL SPACES IN THE BUILDING NOT AFFECTED BY THIS WORK. COORDINATE WITH VA COR ANY DISRUPTION IN SERVICES REQUIRED TO PERFORM WORK.
 - PENETRATIONS THROUGH EXISTING WALLS AND FLOORS REQUIRE FIRE CAULKING BY THIS CONTRACTOR.
 - EXISTING SYSTEM LAYOUT IS BASED ON FIELD SURVEY. EXACT LOCATIONS AND ELEVATIONS MAY VARY.
 - REFER TO ALL OTHER PLANS, DIAGRAMS, DETAILS AND SPECIFICATIONS TO PROVIDE A FULLY FUNCTIONAL SYSTEM. PROVIDE OFFSETS NOT SHOWN ON DIAGRAMS TO AVOID OBSTRUCTIONS.
 - SUPPORT EQUIPMENT, PANELS, DEVICES, CABLES AND WIRING FROM STRUCTURE, WALLS AND FLOOR SO THAT ALL ITEMS ARE ACCESSIBLE FOR MAINTENANCE.
 - ALL BUILDINGS WILL BE CONTINUOUSLY OCCUPIED. ALL SYSTEMS MUST BE AVAILABLE BY 7:00 AM AFTER A NIGHT OR ANY SHUT-DOWN.
 - THIS CONTRACTOR IS RESPONSIBLE TO MOVE EXISTING FURNITURE OUT OF THE WAY OF THE REQUIRED WORK AND MOVE IT BACK AFTER THE WORK IS COMPLETED.
 - DEMOLITION AND REMOVAL OF EXISTING FIRE ALARM DEVICES, CONDUIT, AND ALL OTHER COMPONENTS OF EXISTING FIRE ALARM SYSTEM IS TO TAKE PLACE AFTER INSTALLATION OF NEW FIRE ALARM SYSTEM IS COMPLETE. SEE DETAILS ON SHEET F501.
- KEYED NOTES:
- DISCONNECT AND REMOVE EXISTING FA DEVICE. REMOVE WIRING, FITTINGS, SUPPORTS, SYSTEM JUNCTION BOXES, RADIO TRANSMITTERS AND RECEIVERS. WIRING TO BE REMOVED TO THE SOURCE.
 - WORK TO INSTALL NEW FIRE ALARM PANELS AND REMOVE EXISTING TO TAKE PLACE DURING NORMAL WORK HOURS. SET UP TEMPORARY ICB-1 BARRIER. REMOVE ICB-1 BARRIER AT END OF THE WORK. REMOVE ALL TOOLS AND EQUIPMENT DAILY. PROTECT WORK IN PROGRESS SO THAT ANY OPENINGS IN WALLS OR CEILINGS ARE COVERED. SWEEP UP DUST IN AREA AND DAMP MOP FLOOR FOR DAILY CLEAN-UP.
 - PROVIDE ICB, SEE DETAIL 2 ON DRAWING GC101 FOR REQUIREMENTS.
- NOTE: ACCESS PANELS MUST BE INSTALLED BEFORE ANY DEMOLITION WORK CAN BEGIN. SEE DRAWING FA137 FOR ACCESS PANEL LOCATIONS.

Revisions: <table><tr><td></td><td></td></tr><tr><td></td><td></td></tr><tr><td></td><td></td></tr><tr><td></td><td></td></tr><tr><td>Date</td><td></td></tr></table>									Date		 VETERANS AFFAIRS MEDICAL CENTER 500 E VETERANS ST TOMAH, WI 54660		CONSULTANTS:	PROJECT LEADER:  PCG DESIGN / BUILD SERVICES 1021 N. Superior Ave. Unit 11 Tomah, Wisconsin 54660	Drawing Title FIRE ALARM B410 FIRST FLOOR AND BASEMENT PLANS - DEMOLITION	Project Title UPGRADE FIRE ALARM SYSTEM DESIGN	FINAL BID DOCUMENTS	
Date																		
				Approved: Project Director		Location Tomah, Wisconsin	Project Number 676-22-110	Office of Facilities Management										
						Date APRIL 21, 2026	Building Number B410											
						Checked By: HFB	Drawn By: JMD	Drawing Number FD137										

three inches = one foot
one and one half inches = one foot
one inch = one foot
three quarters inch = one foot
one half inch = one foot
three eighths inch = one foot
one quarter inch = one foot
one eighth inch = one foot

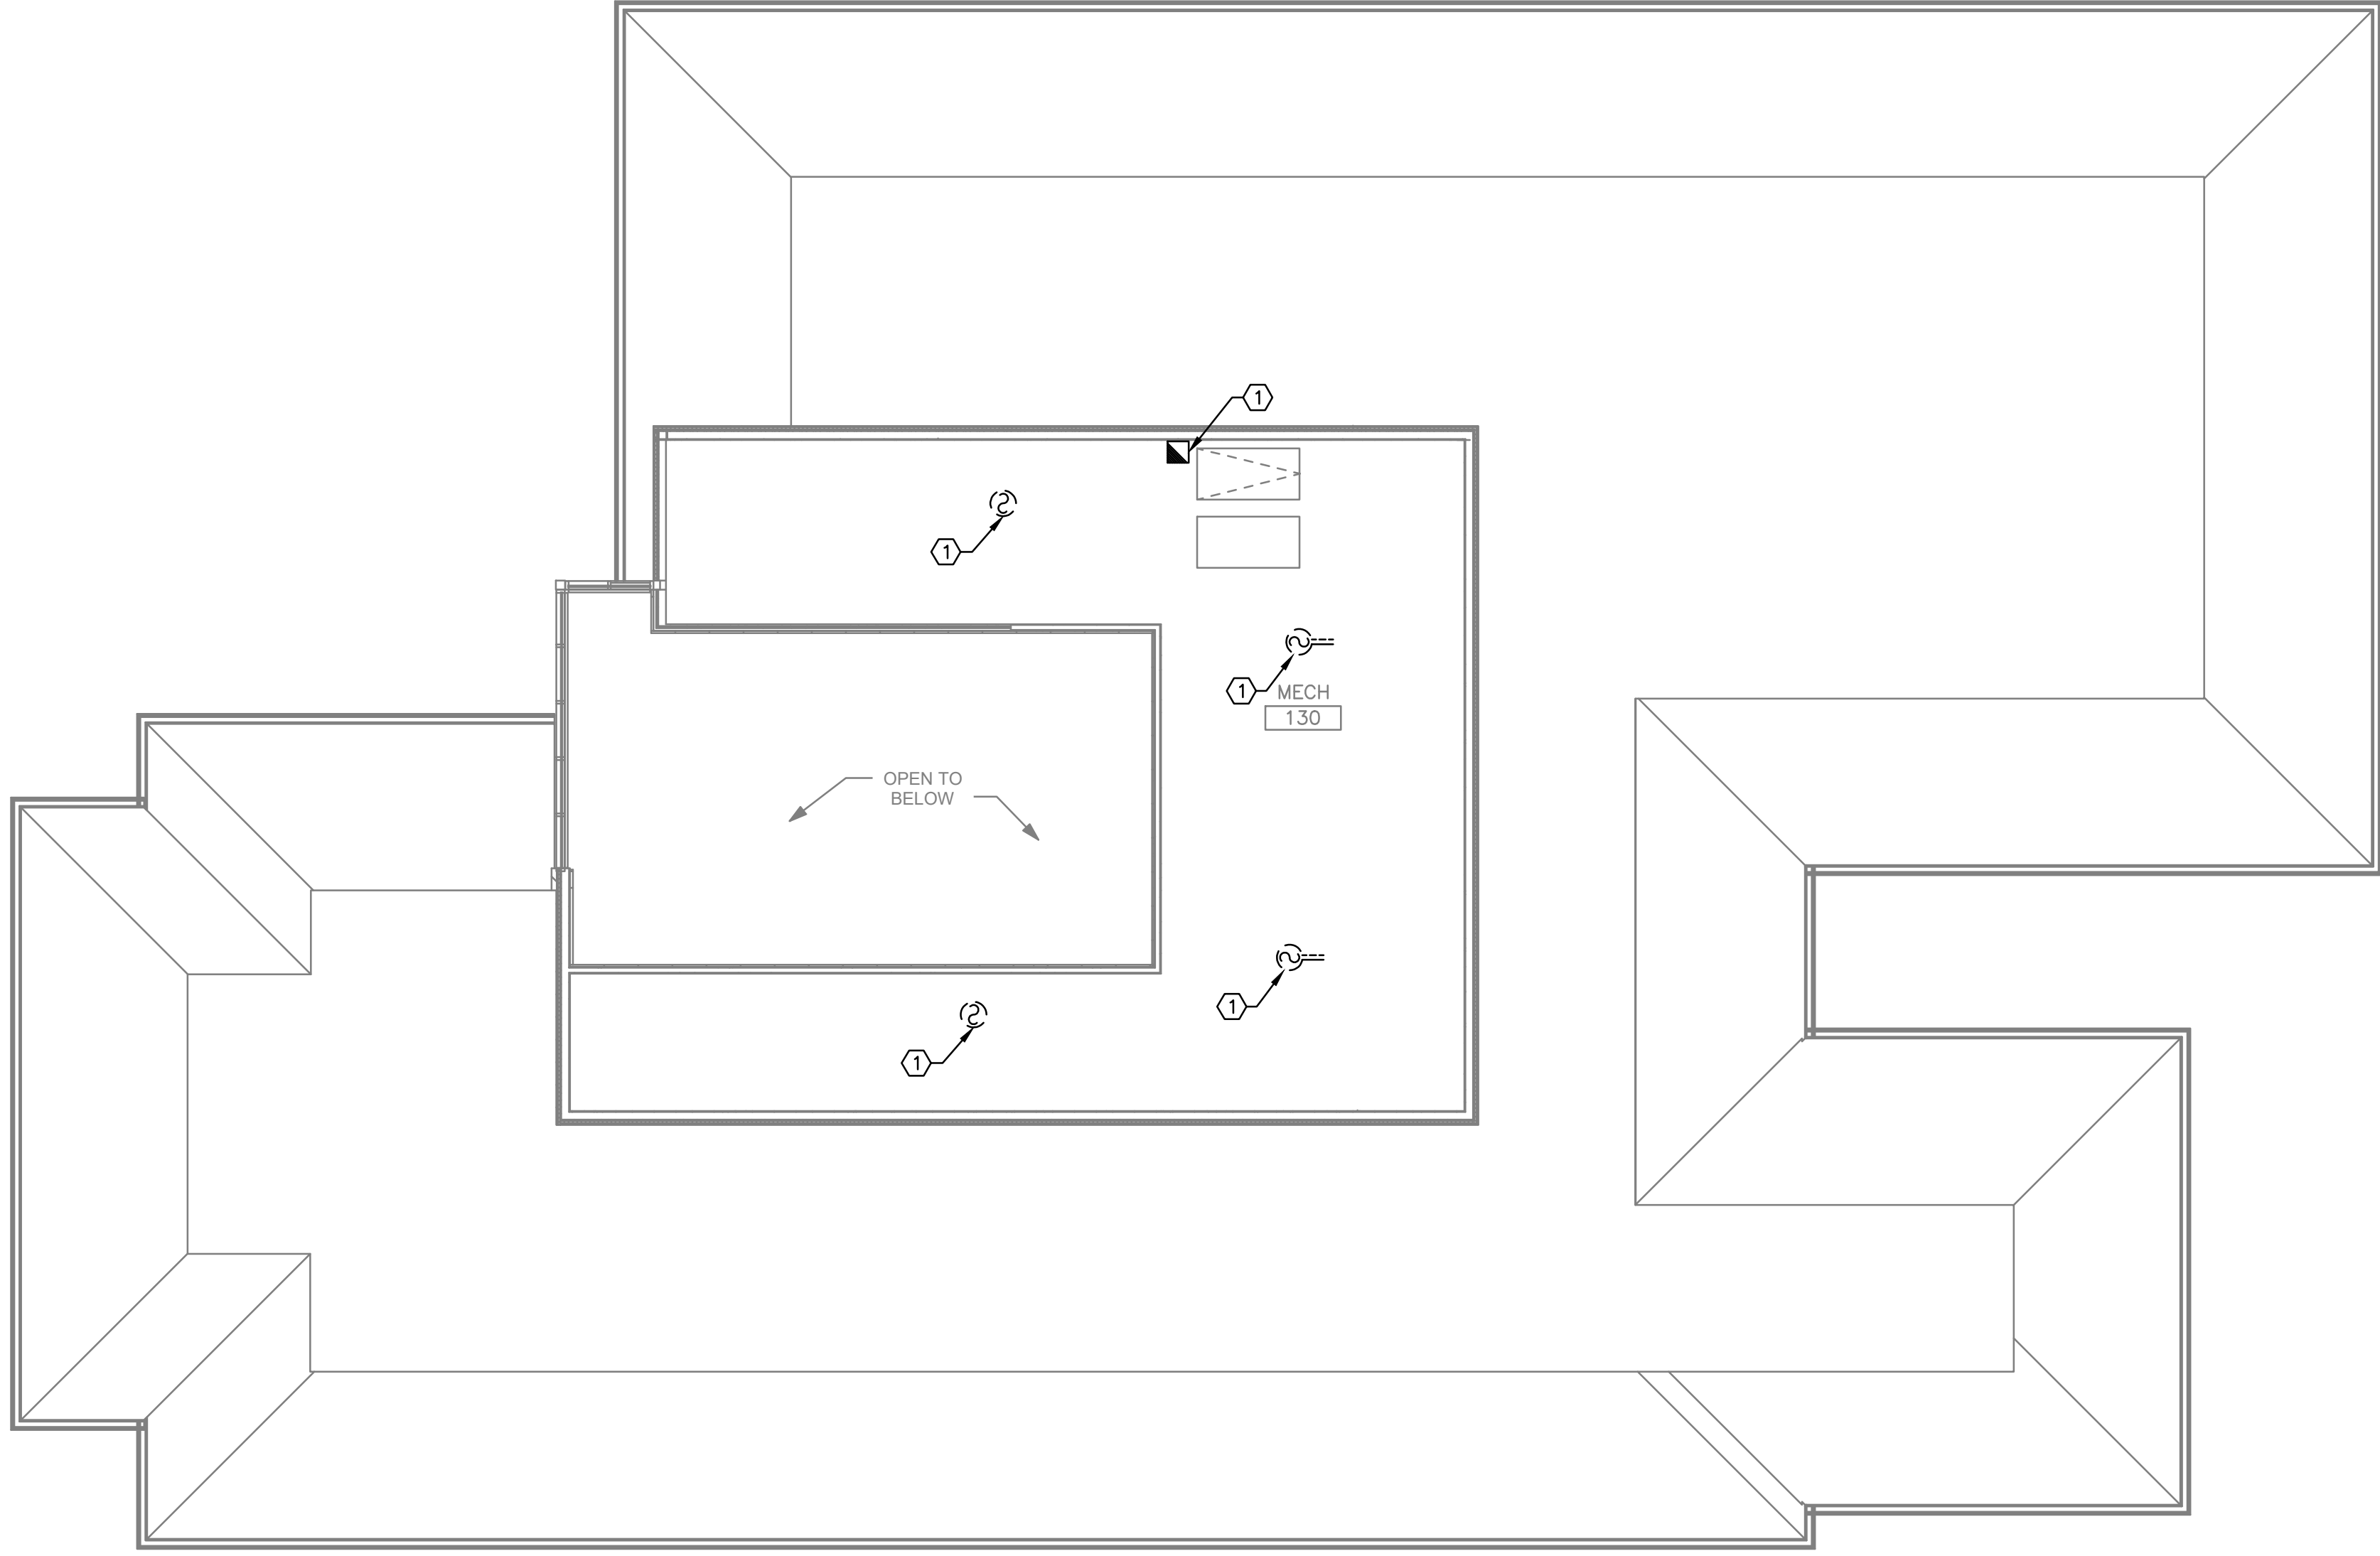

2 ATTIC FLOOR PLAN
1/8" = 1'-0" NORTH

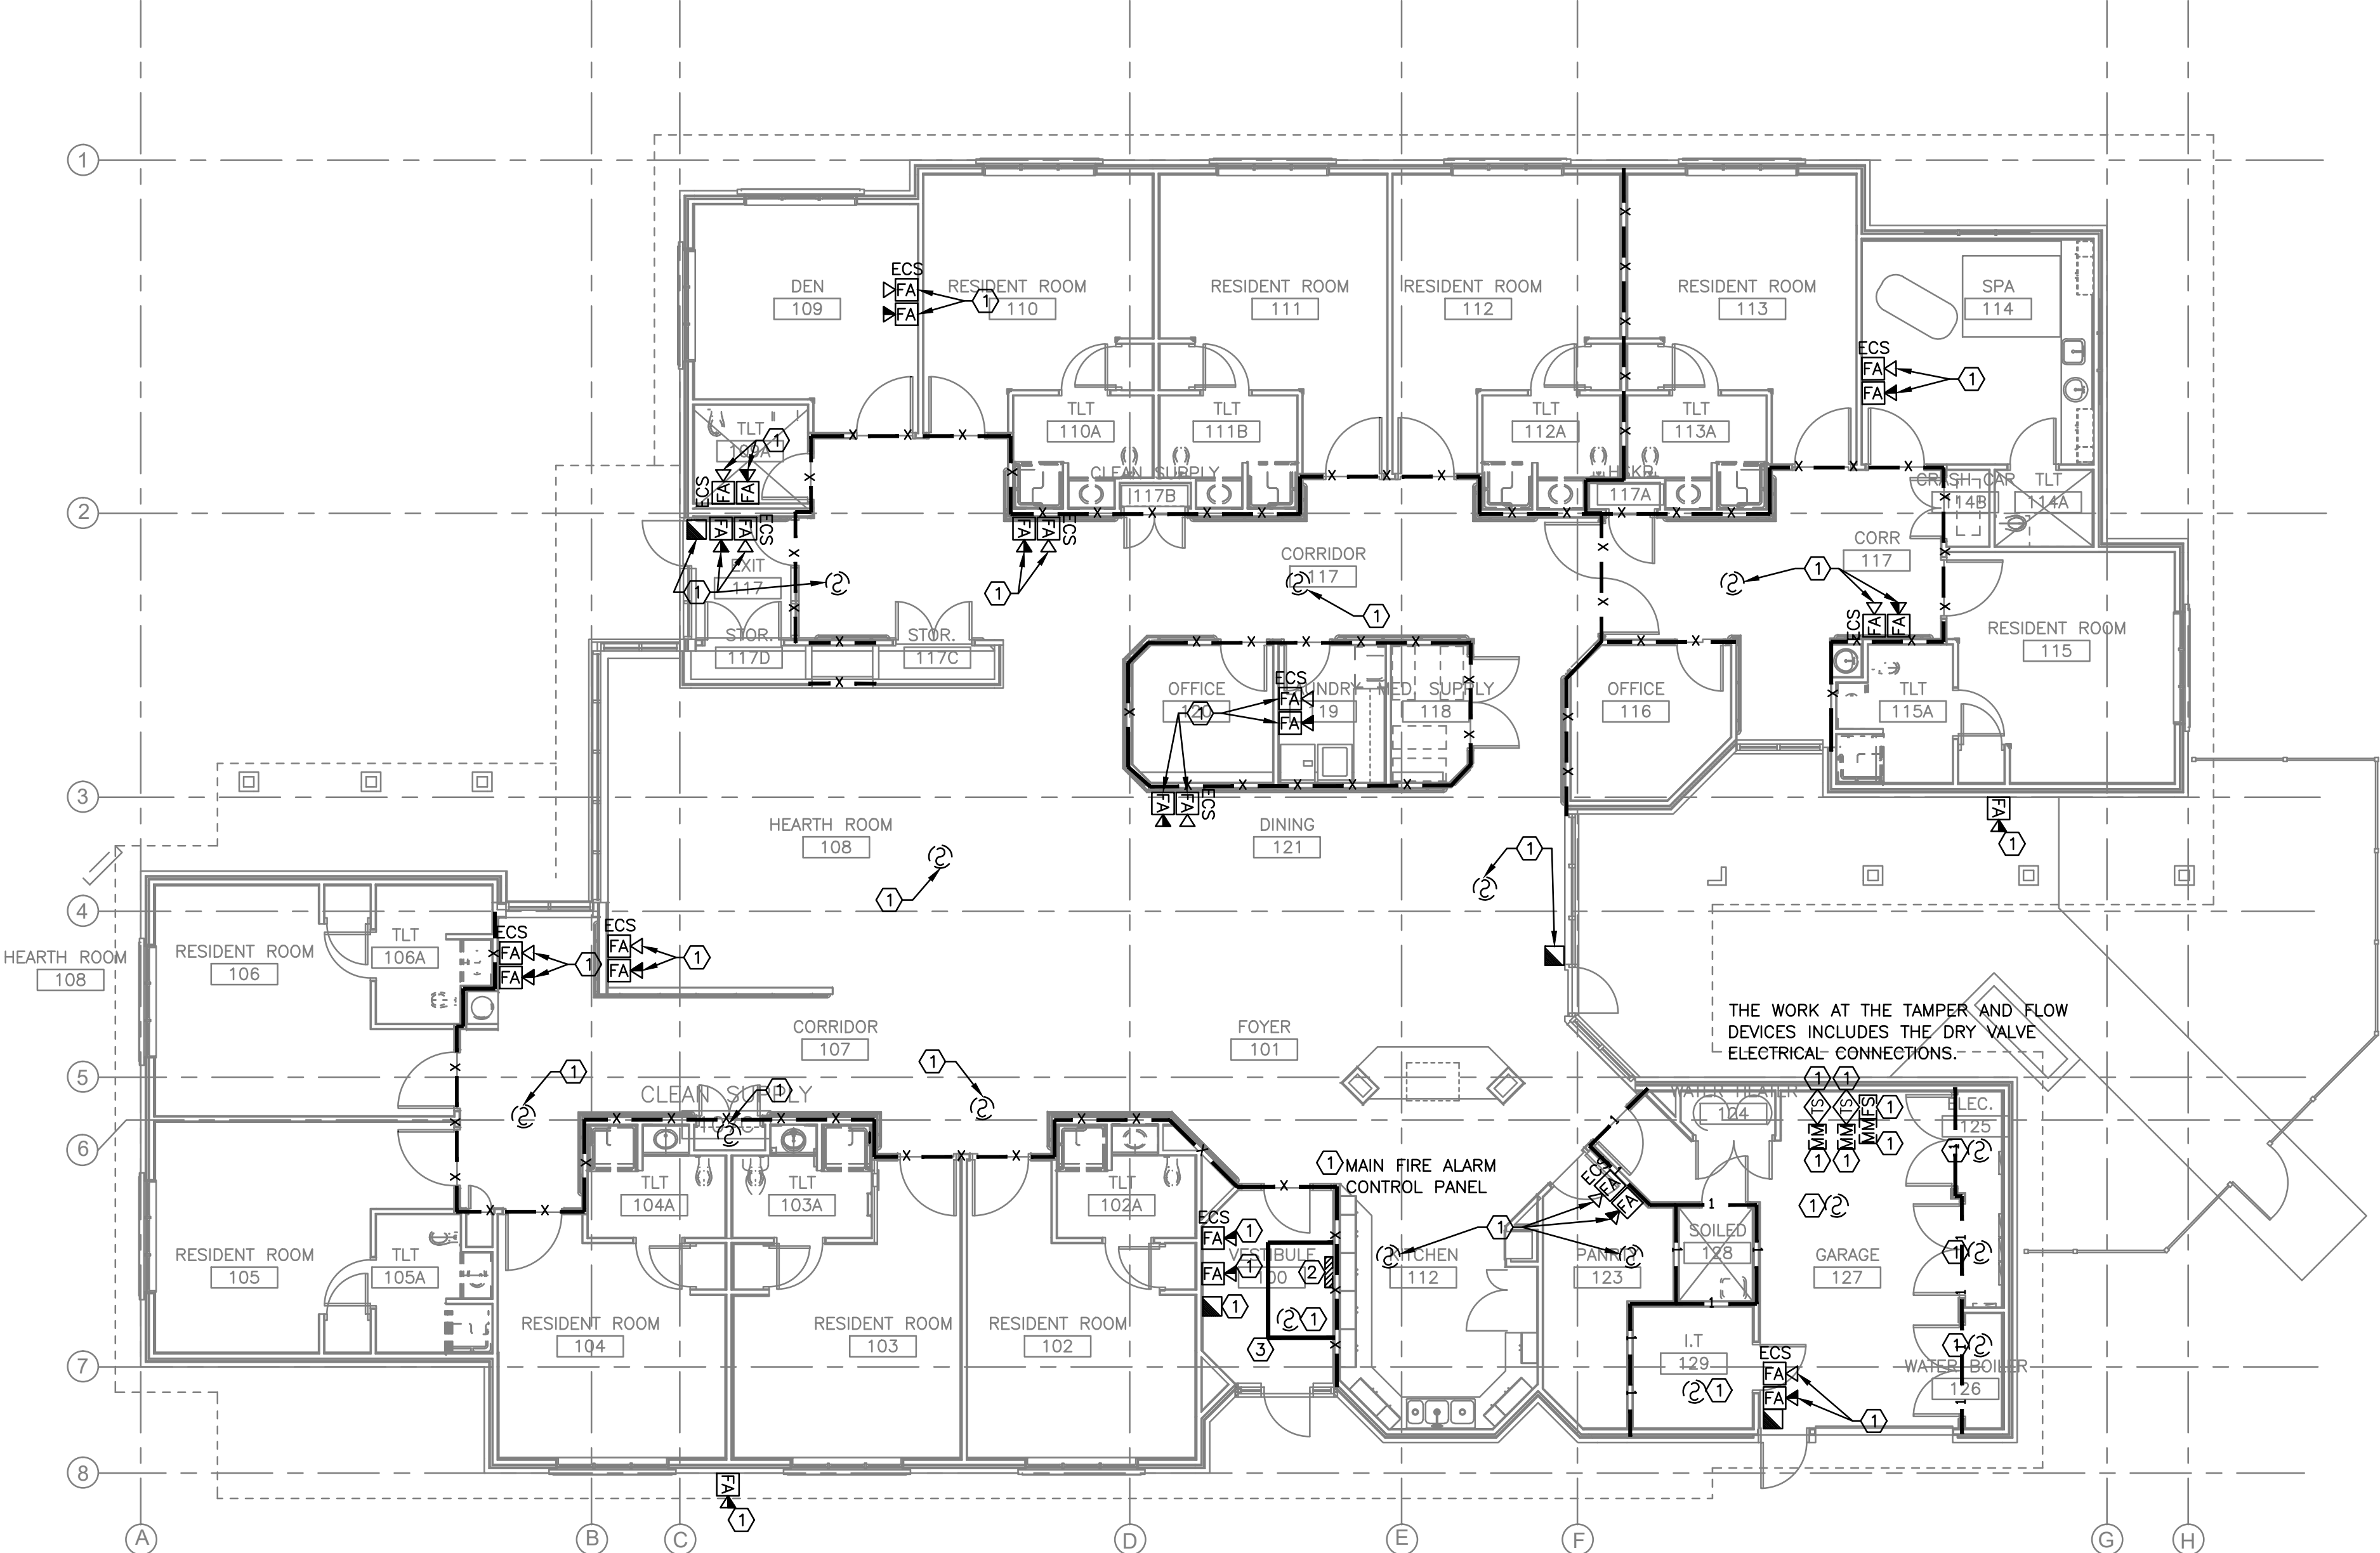


1 FIRST FLOOR
1/8" = 1'-0" NORTH


- GENERAL NOTES:**
- SEE SHEET F001 FOR LEGENDS, NOTES AND ABBREVIATIONS.
 - PROTECT ALL DEVICES AND EQUIPMENT TO REMAIN DURING CONSTRUCTION.
 - FIRE PROTECTION CONTRACTOR TO REVIEW ARCHITECTURAL AND ELECTRICAL PLANS FOR ADDITIONAL INFORMATION AND REQUIRED WORK NECESSARY TO FACILITATE A COMPLETE SYSTEM AND IS PART OF FIRE PROTECTION CONTRACTOR'S SCOPE OF WORK.
 - MAINTAIN CONTINUOUS UTILITY SERVICE TO ALL SPACES IN THE BUILDING NOT AFFECTED BY THIS WORK. COORDINATE WITH VA COR ANY DISRUPTION IN SERVICES REQUIRED TO PERFORM WORK.
 - PENETRATIONS THROUGH EXISTING WALLS AND FLOORS REQUIRE FIRE CAULKING BY THIS CONTRACTOR.
 - EXISTING SYSTEM LAYOUT IS BASED ON FIELD SURVEY. EXACT LOCATIONS AND ELEVATIONS MAY VARY.
 - REFER TO ALL OTHER PLANS, DIAGRAMS, DETAILS AND SPECIFICATIONS TO PROVIDE A FULLY FUNCTIONAL SYSTEM. PROVIDE OFFSETS NOT SHOWN ON DIAGRAMS TO AVOID OBSTRUCTIONS.
 - SUPPORT EQUIPMENT, PANELS, DEVICES, CABLES AND WIRING FROM STRUCTURE, WALLS AND FLOOR SO THAT ALL ITEMS ARE ACCESSIBLE FOR MAINTENANCE.
 - ALL BUILDINGS WILL BE CONTINUOUSLY OCCUPIED. ALL SYSTEMS MUST BE AVAILABLE BY 7:00 AM AFTER A NIGHT OR ANY SHUT-DOWN.
 - THIS CONTRACTOR IS RESPONSIBLE TO MOVE EXISTING FURNITURE OUT OF THE WAY OF THE REQUIRED WORK AND MOVE IT BACK AFTER THE WORK IS COMPLETED.
 - DEMOLITION AND REMOVAL OF EXISTING FIRE ALARM DEVICES, CONDUIT, AND ALL OTHER COMPONENTS OF EXISTING FIRE ALARM SYSTEM TO TAKE PLACE AFTER INSTALLATION OF NEW FIRE ALARM SYSTEM IS COMPLETE. SEE DETAILS ON SHEET F501.

- KEYED NOTES:**
- DISCONNECT AND REMOVE EXISTING FA DEVICE. REMOVE WIRING, FITTINGS, SUPPORTS, SYSTEM JUNCTION BOXES, RADIO TRANSMITTERS AND RECEIVERS. WIRING TO BE REMOVED TO THE SOURCE.
 - WORK TO INSTALL NEW FIRE ALARM PANELS AND REMOVE EXISTING TO TAKE PLACE DURING NORMAL WORK HOURS. SET UP TEMPORARY ICB-1 BARRIER. REMOVE ICB-1 BARRIER AT END OF THE WORK. REMOVE ALL TOOLS AND EQUIPMENT DAILY. PROTECT WORK IN PROGRESS SO THAT ANY OPENINGS IN WALLS OR CEILINGS ARE COVERED. SWEEP UP DUST IN AREA AND DAMP MOP FLOOR FOR DAILY CLEAN-UP.
 - PROVIDE ICB, SEE DETAIL 2 ON DRAWING GC101 FOR REQUIREMENTS.
- NOTE: ACCESS PANELS MUST BE INSTALLED BEFORE ANY DEMOLITION WORK CAN BEGIN. SEE DRAWING FA138 FOR ACCESS PANEL LOCATIONS.


Revisions: Date	VETERANS AFFAIRS MEDICAL CENTER 500 E VETERANS ST TOMAH, WI 54660		CONSULTANTS:	PROJECT LEADER: PCG DESIGN / BUILD SERVICES 1021 N. Superior Ave. Unit 11 Tomah, Wisconsin 54660	Drawing Title FIRE ALARM B411 FIRST FLOOR AND ATTIC PLANS - DEMOLITION	Project Title UPGRADE FIRE ALARM SYSTEM DESIGN	FINAL BID DOCUMENTS	
					Approved: Project Director	Location Tomah, Wisconsin Date APRIL 21, 2026 Checked By: HFB Drawn By: JMD	Project Number 676-22-110 Building Number B411 Drawing Number FD138	Office of Facilities Management Department of Veterans Affairs

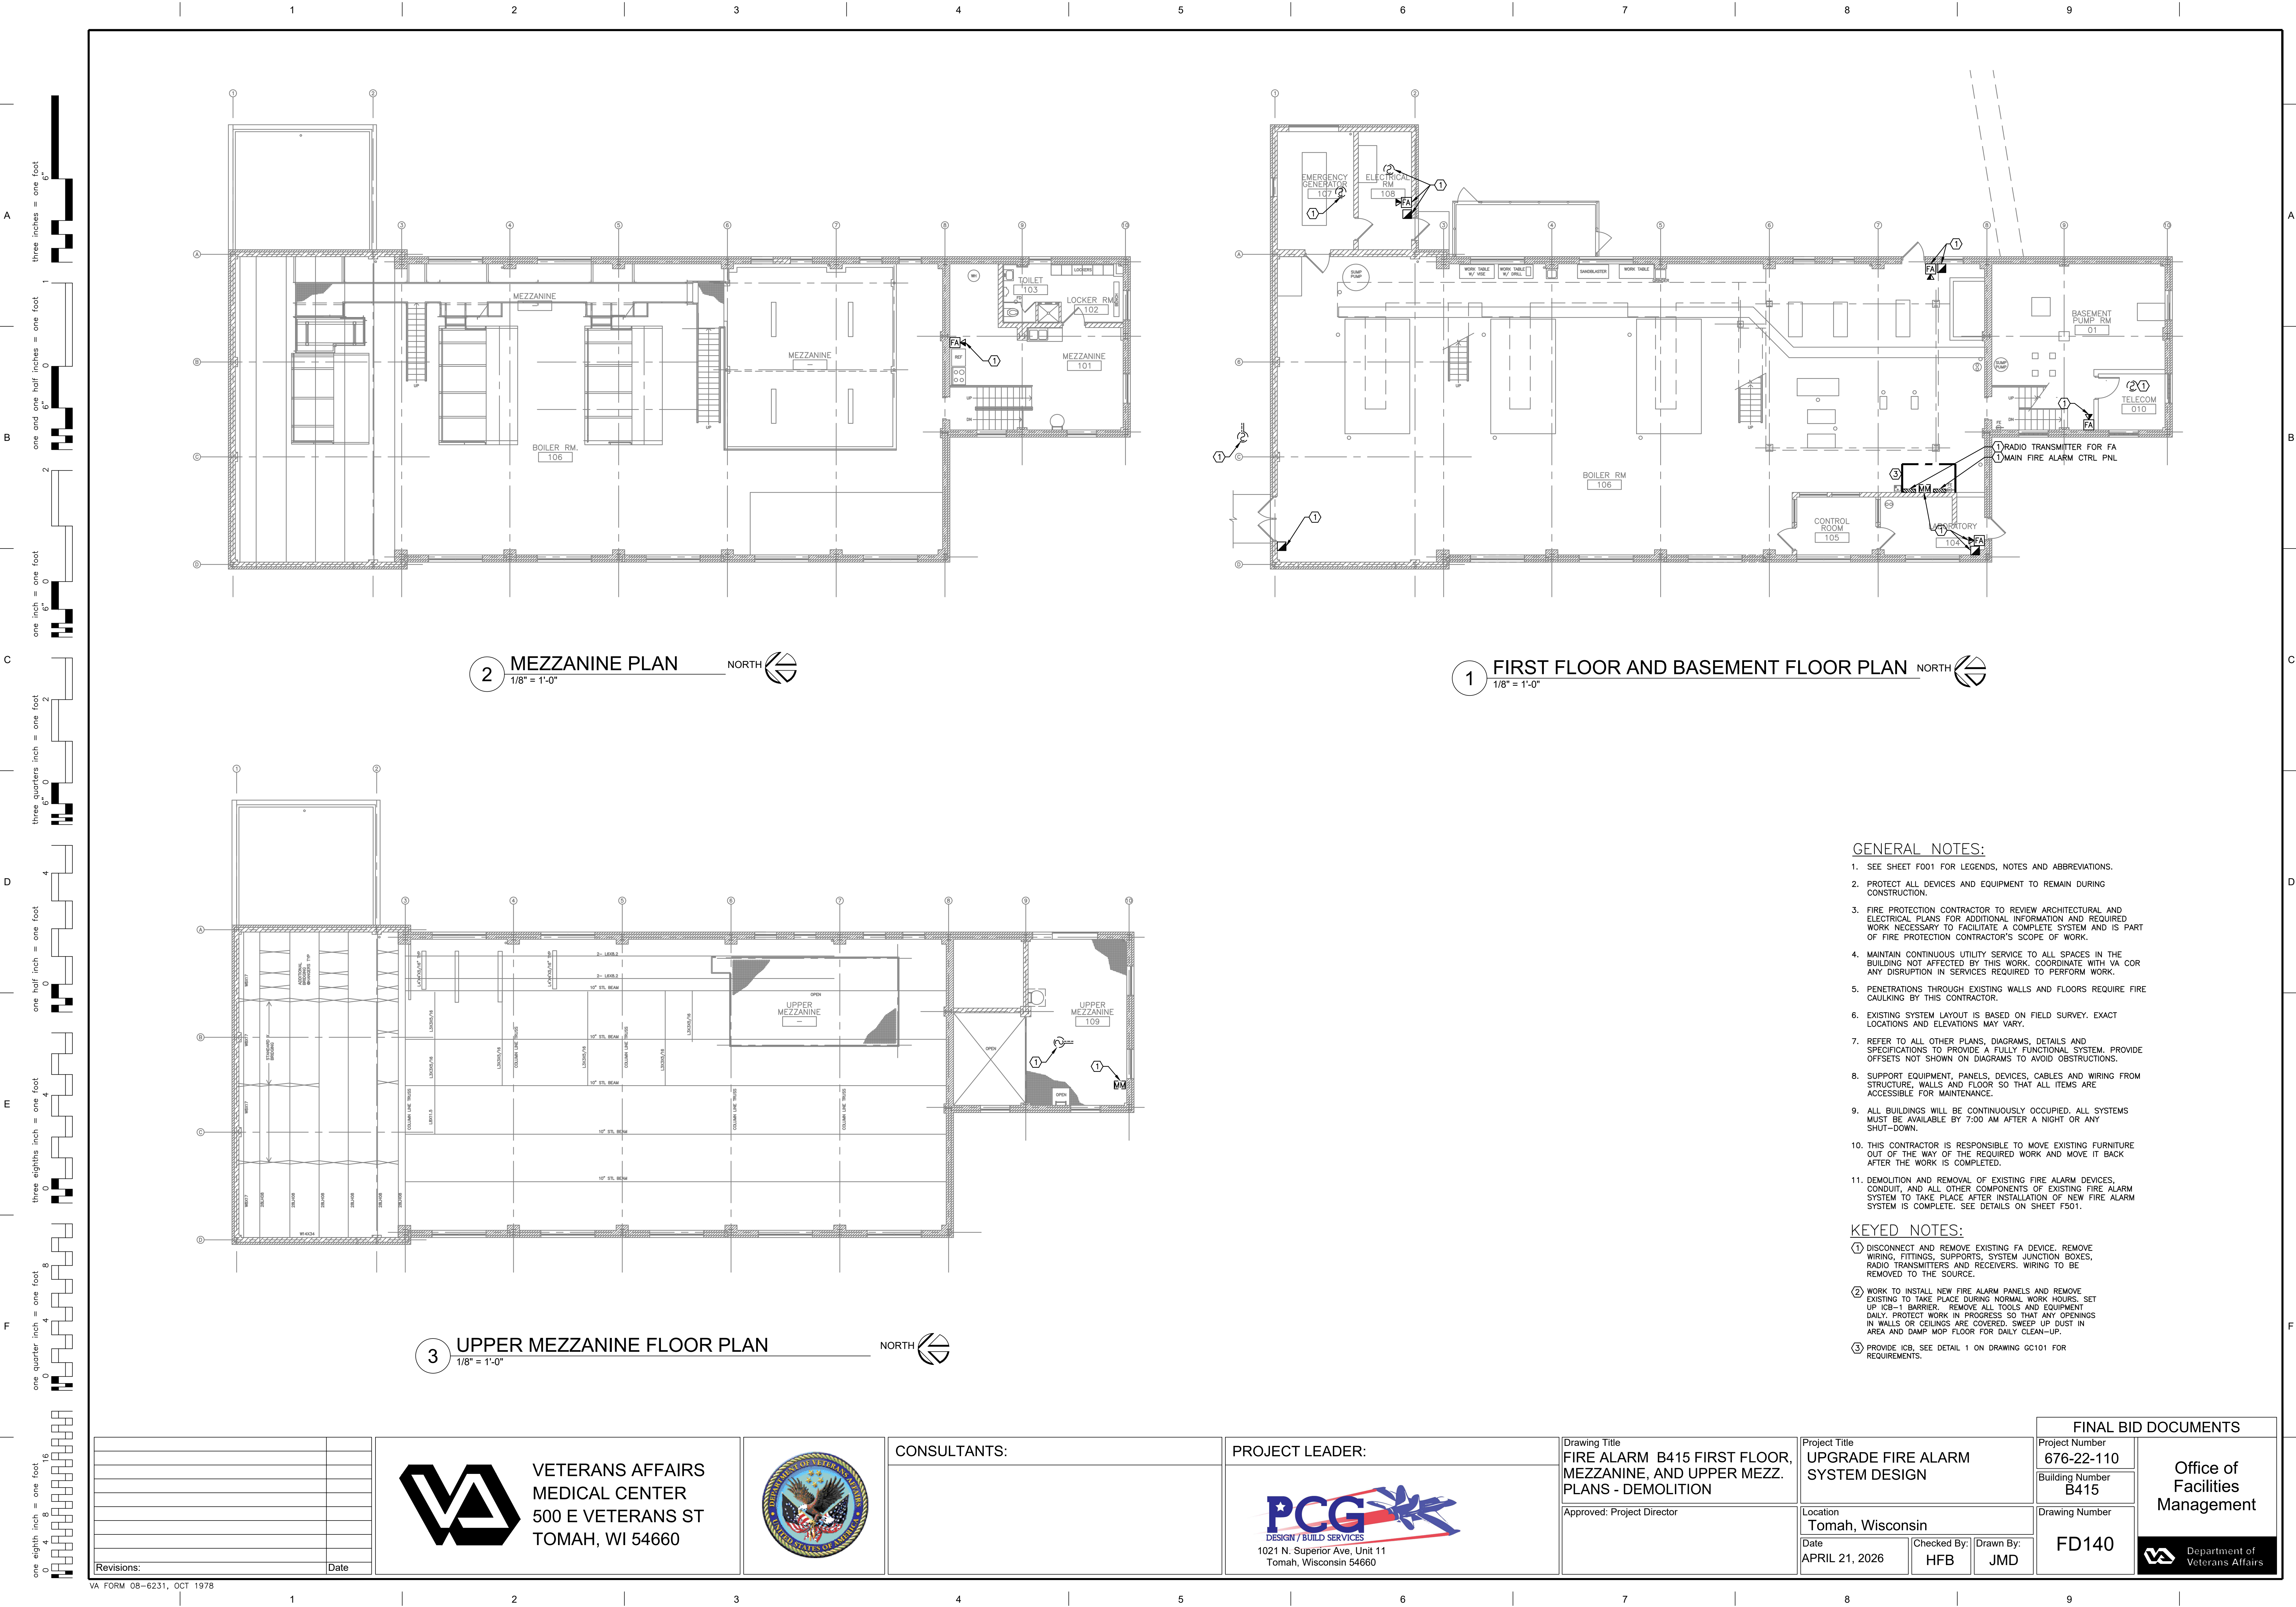

three inches = one foot
one and one half inches = one foot
one inch = one foot
three quarters inch = one foot
one half inch = one foot
three eighths inch = one foot
one quarter inch = one foot
one eighth inch = one foot

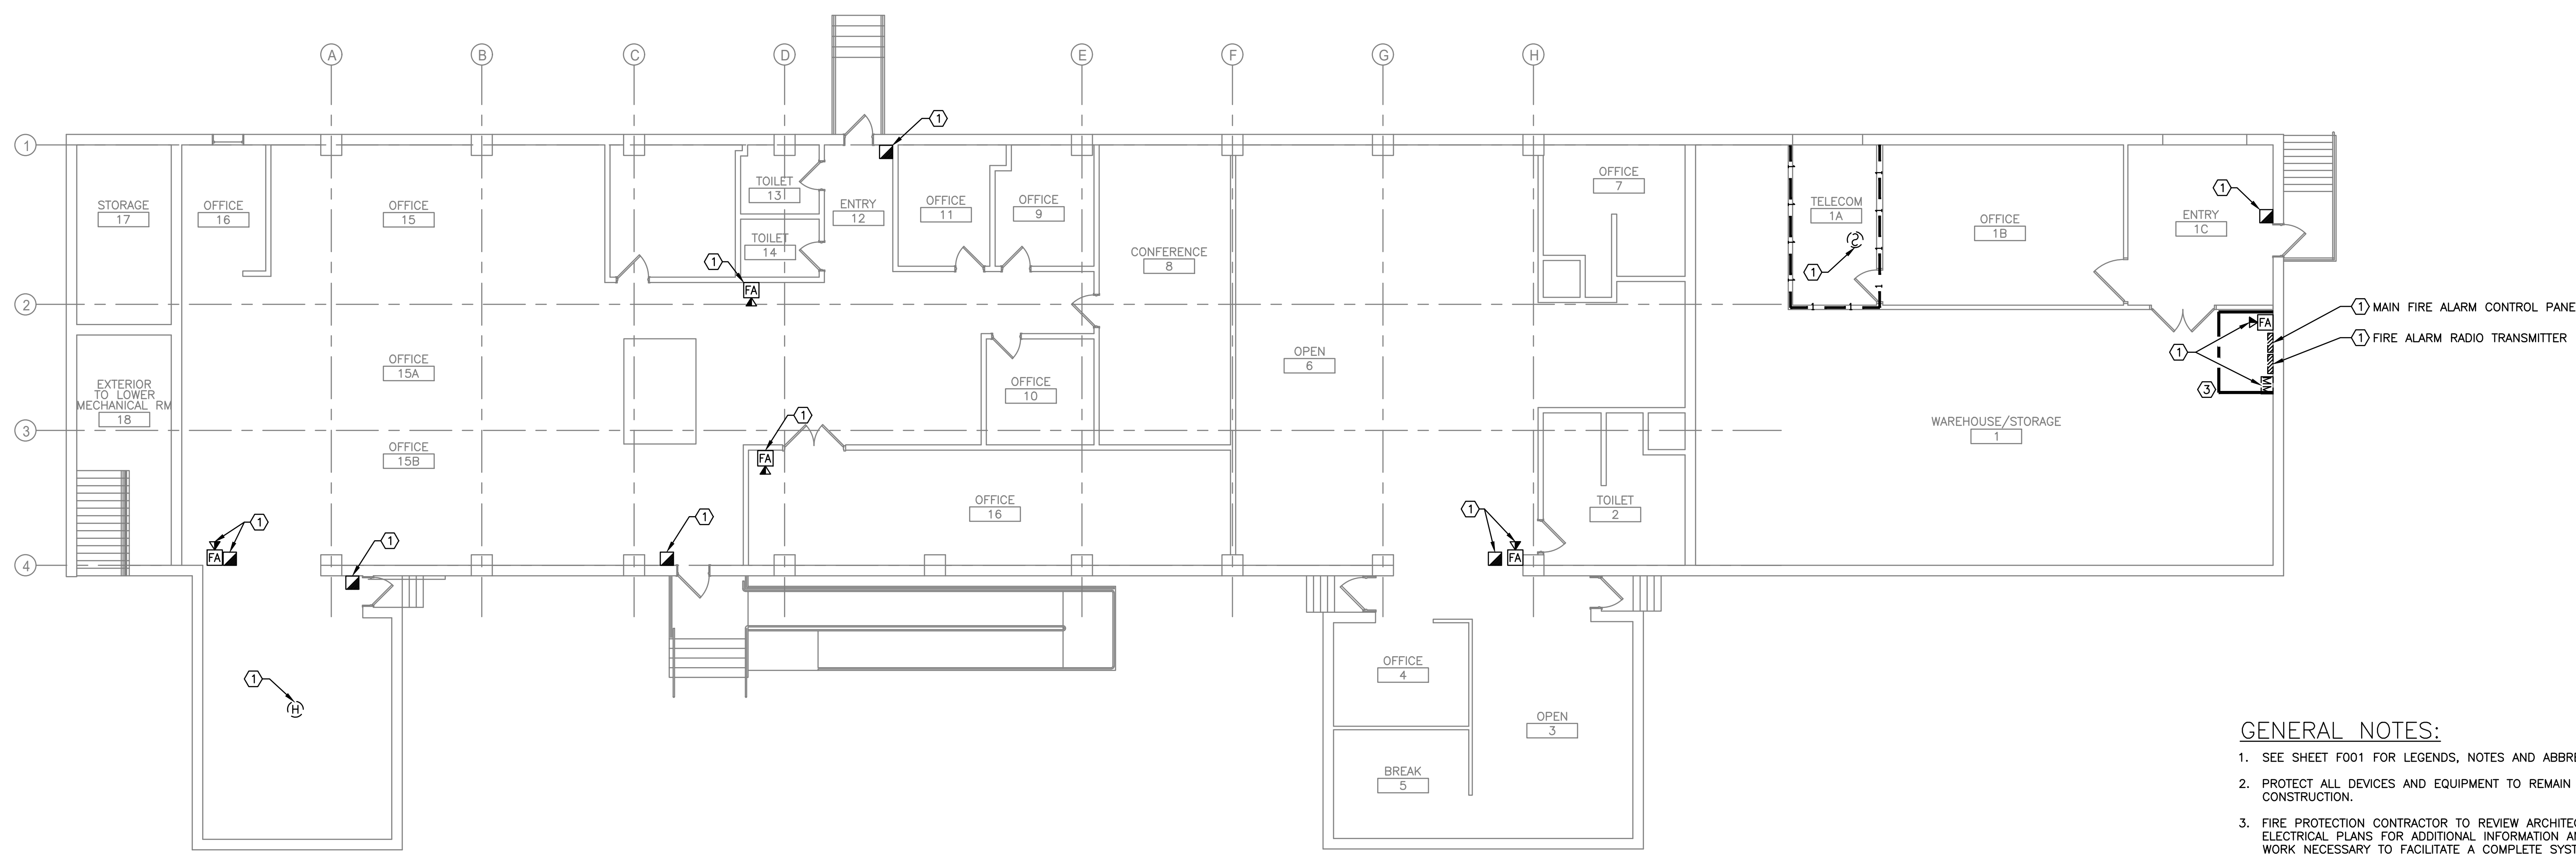

1 FIRST FLOOR
1/8" = 1'-0"

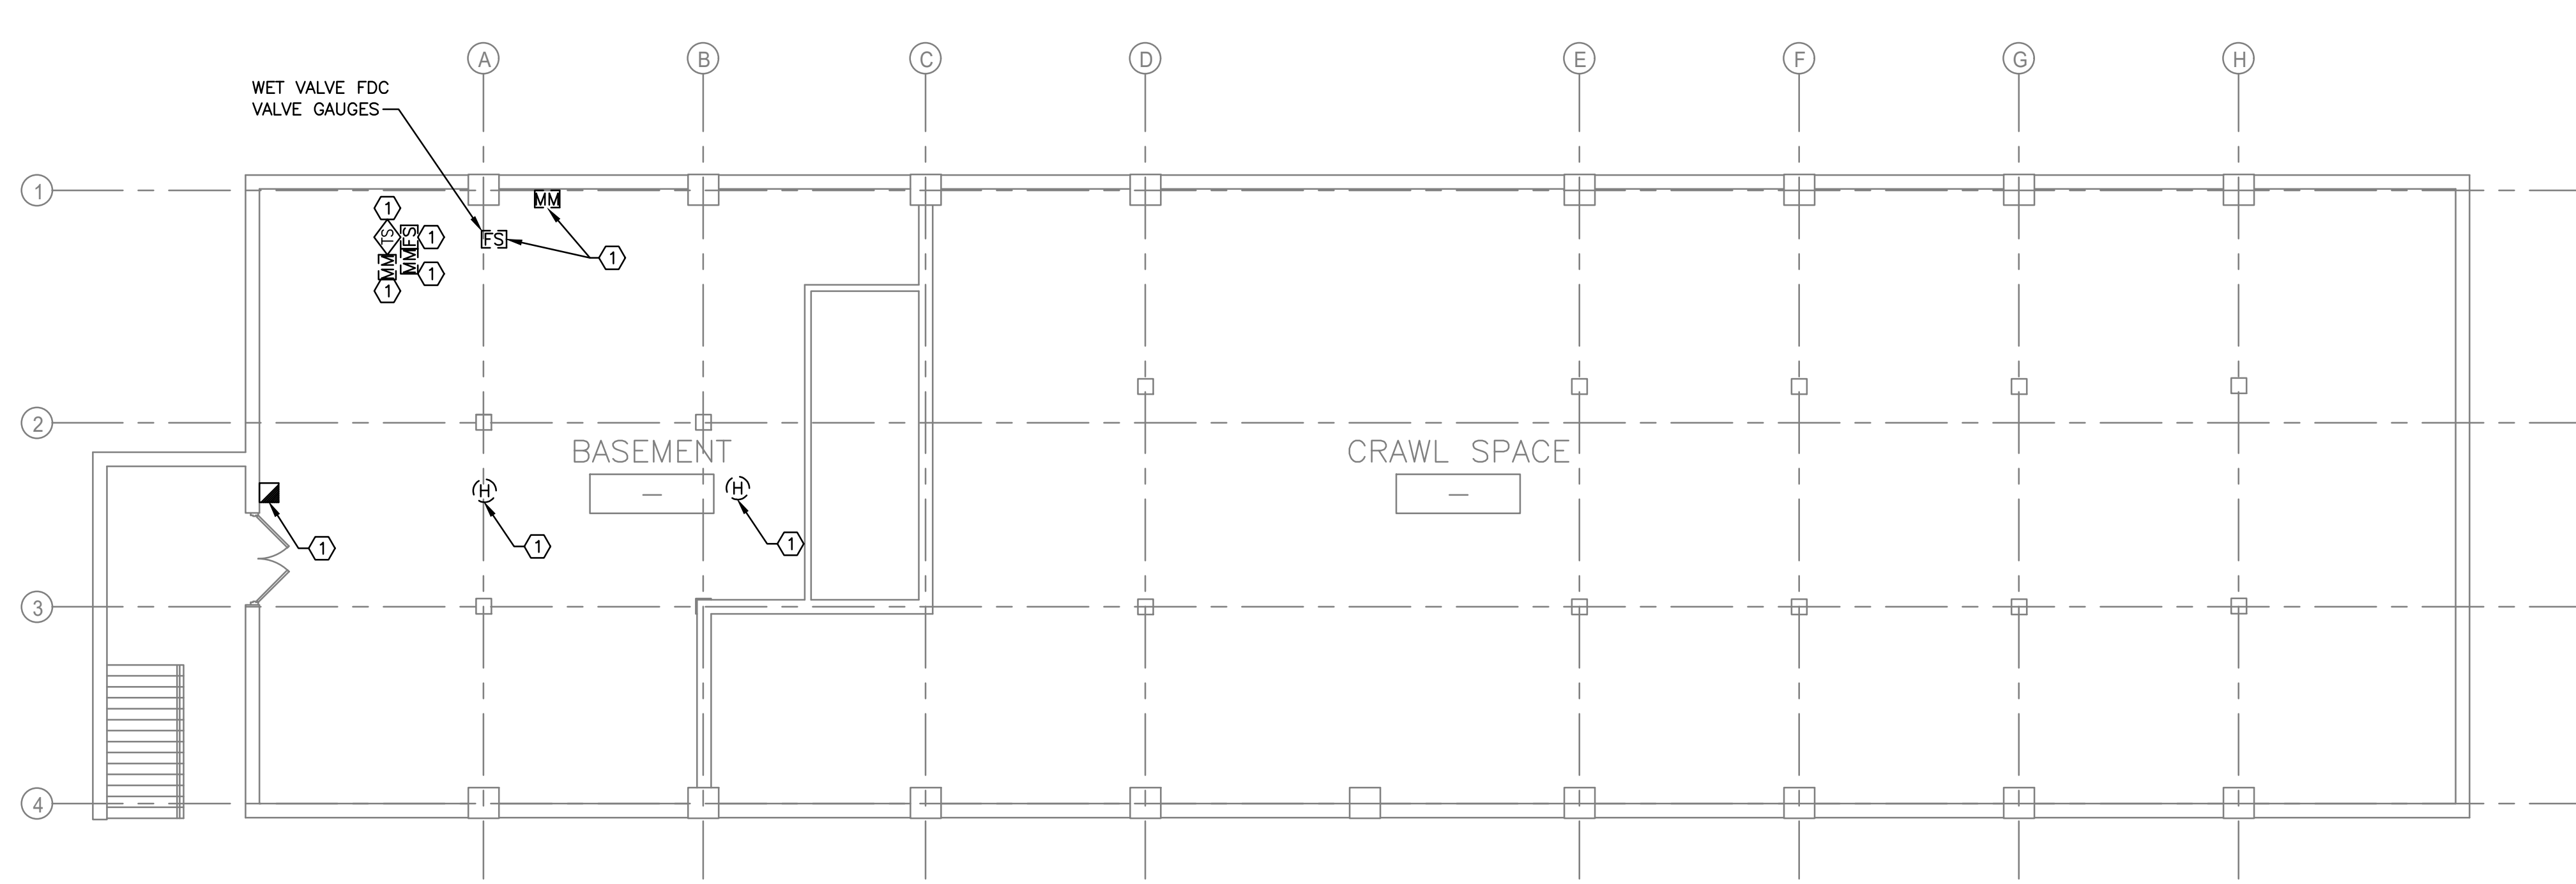

2 BASEMENT FLOOR PLAN
1/8" = 1'-0"

GENERAL NOTES:

- SEE SHEET F001 FOR LEGENDS, NOTES AND ABBREVIATIONS.
- PROTECT ALL DEVICES AND EQUIPMENT TO REMAIN DURING CONSTRUCTION.
- FIRE PROTECTION CONTRACTOR TO REVIEW ARCHITECTURAL AND ELECTRICAL PLANS FOR ADDITIONAL INFORMATION AND REQUIRED WORK NECESSARY TO FACILITATE A COMPLETE SYSTEM AND IS PART OF FIRE PROTECTION CONTRACTOR'S SCOPE OF WORK.
- MAINTAIN CONTINUOUS UTILITY SERVICE TO ALL SPACES IN THE BUILDING NOT AFFECTED BY THIS WORK. COORDINATE WITH VA COR ANY DISRUPTION IN SERVICES REQUIRED TO PERFORM WORK.
- PENETRATIONS THROUGH EXISTING WALLS AND FLOORS REQUIRE FIRE CAULKING BY THIS CONTRACTOR.
- EXISTING SYSTEM LAYOUT IS BASED ON FIELD SURVEY. EXACT LOCATIONS AND ELEVATIONS MAY VARY.
- REFER TO ALL OTHER PLANS, DIAGRAMS, DETAILS AND SPECIFICATIONS TO PROVIDE A FULLY FUNCTIONAL SYSTEM. PROVIDE OFFSETS NOT SHOWN ON DIAGRAMS TO AVOID OBSTRUCTIONS.
- SUPPORT EQUIPMENT, PANELS, DEVICES, CABLES AND WIRING FROM STRUCTURE, WALLS AND FLOOR SO THAT ALL ITEMS ARE ACCESSIBLE FOR MAINTENANCE.
- ALL BUILDINGS WILL BE CONTINUOUSLY OCCUPIED. ALL SYSTEMS MUST BE AVAILABLE BY 7:00 AM AFTER A NIGHT OR ANY SHUT-DOWN.
- THIS CONTRACTOR IS RESPONSIBLE TO MOVE EXISTING FURNITURE OUT OF THE WAY OF THE REQUIRED WORK AND MOVE IT BACK AFTER THE WORK IS COMPLETED.
- DEMOLITION AND REMOVAL OF EXISTING FIRE ALARM DEVICES, CONDUIT, AND ALL OTHER COMPONENTS OF EXISTING FIRE ALARM SYSTEM TO TAKE PLACE AFTER INSTALLATION OF NEW FIRE ALARM SYSTEM IS COMPLETE. SEE DETAILS ON SHEET F501.

KEYED NOTES:

- DISCONNECT AND REMOVE EXISTING FA DEVICE. REMOVE WIRING, FITTINGS, SUPPORTS, SYSTEM JUNCTION BOXES, RADIO TRANSMITTERS AND RECEIVERS. WIRING TO BE REMOVED TO THE SOURCE.
- WORK TO INSTALL NEW FIRE ALARM PANELS AND REMOVE EXISTING TO TAKE PLACE DURING NORMAL WORK HOURS. SET UP ICB-1 BARRIER. REMOVE ALL TOOLS AND EQUIPMENT DAILY. PROTECT WORK IN PROGRESS SO THAT ANY OPENINGS IN WALLS OR CEILINGS ARE COVERED. SWEEP UP DUST IN AREA AND DAMP MOP FLOOR FOR DAILY CLEAN-UP.
- PROVIDE ICB, SEE DETAIL 1 ON DRAWING GC101 FOR REQUIREMENTS.

Revisions: Date	 VETERANS AFFAIRS MEDICAL CENTER 500 E VETERANS ST TOMAH, WI 54660		CONSULTANTS:	PROJECT LEADER:  1021 N. Superior Ave. Unit 11 Tomah, Wisconsin 54660	Drawing Title FIRE ALARM B416 FIRST FLOOR AND BASEMENT PLANS - DEMOLITION	Project Title UPGRADE FIRE ALARM SYSTEM DESIGN	FINAL BID DOCUMENTS	
					Approved: Project Director	Location Tomah, Wisconsin Date APRIL 21, 2026 Checked By: HFB Drawn By: JMD	Project Number 676-22-110 Building Number B416 Drawing Number FD141	Office of Facilities Management 

three inches = one foot

one and one half inches = one foot

one inch = one foot


three quarters inch = one foot

one half inch = one foot


three eighths inch = one foot

one quarter inch = one foot

one eighth inch = one foot

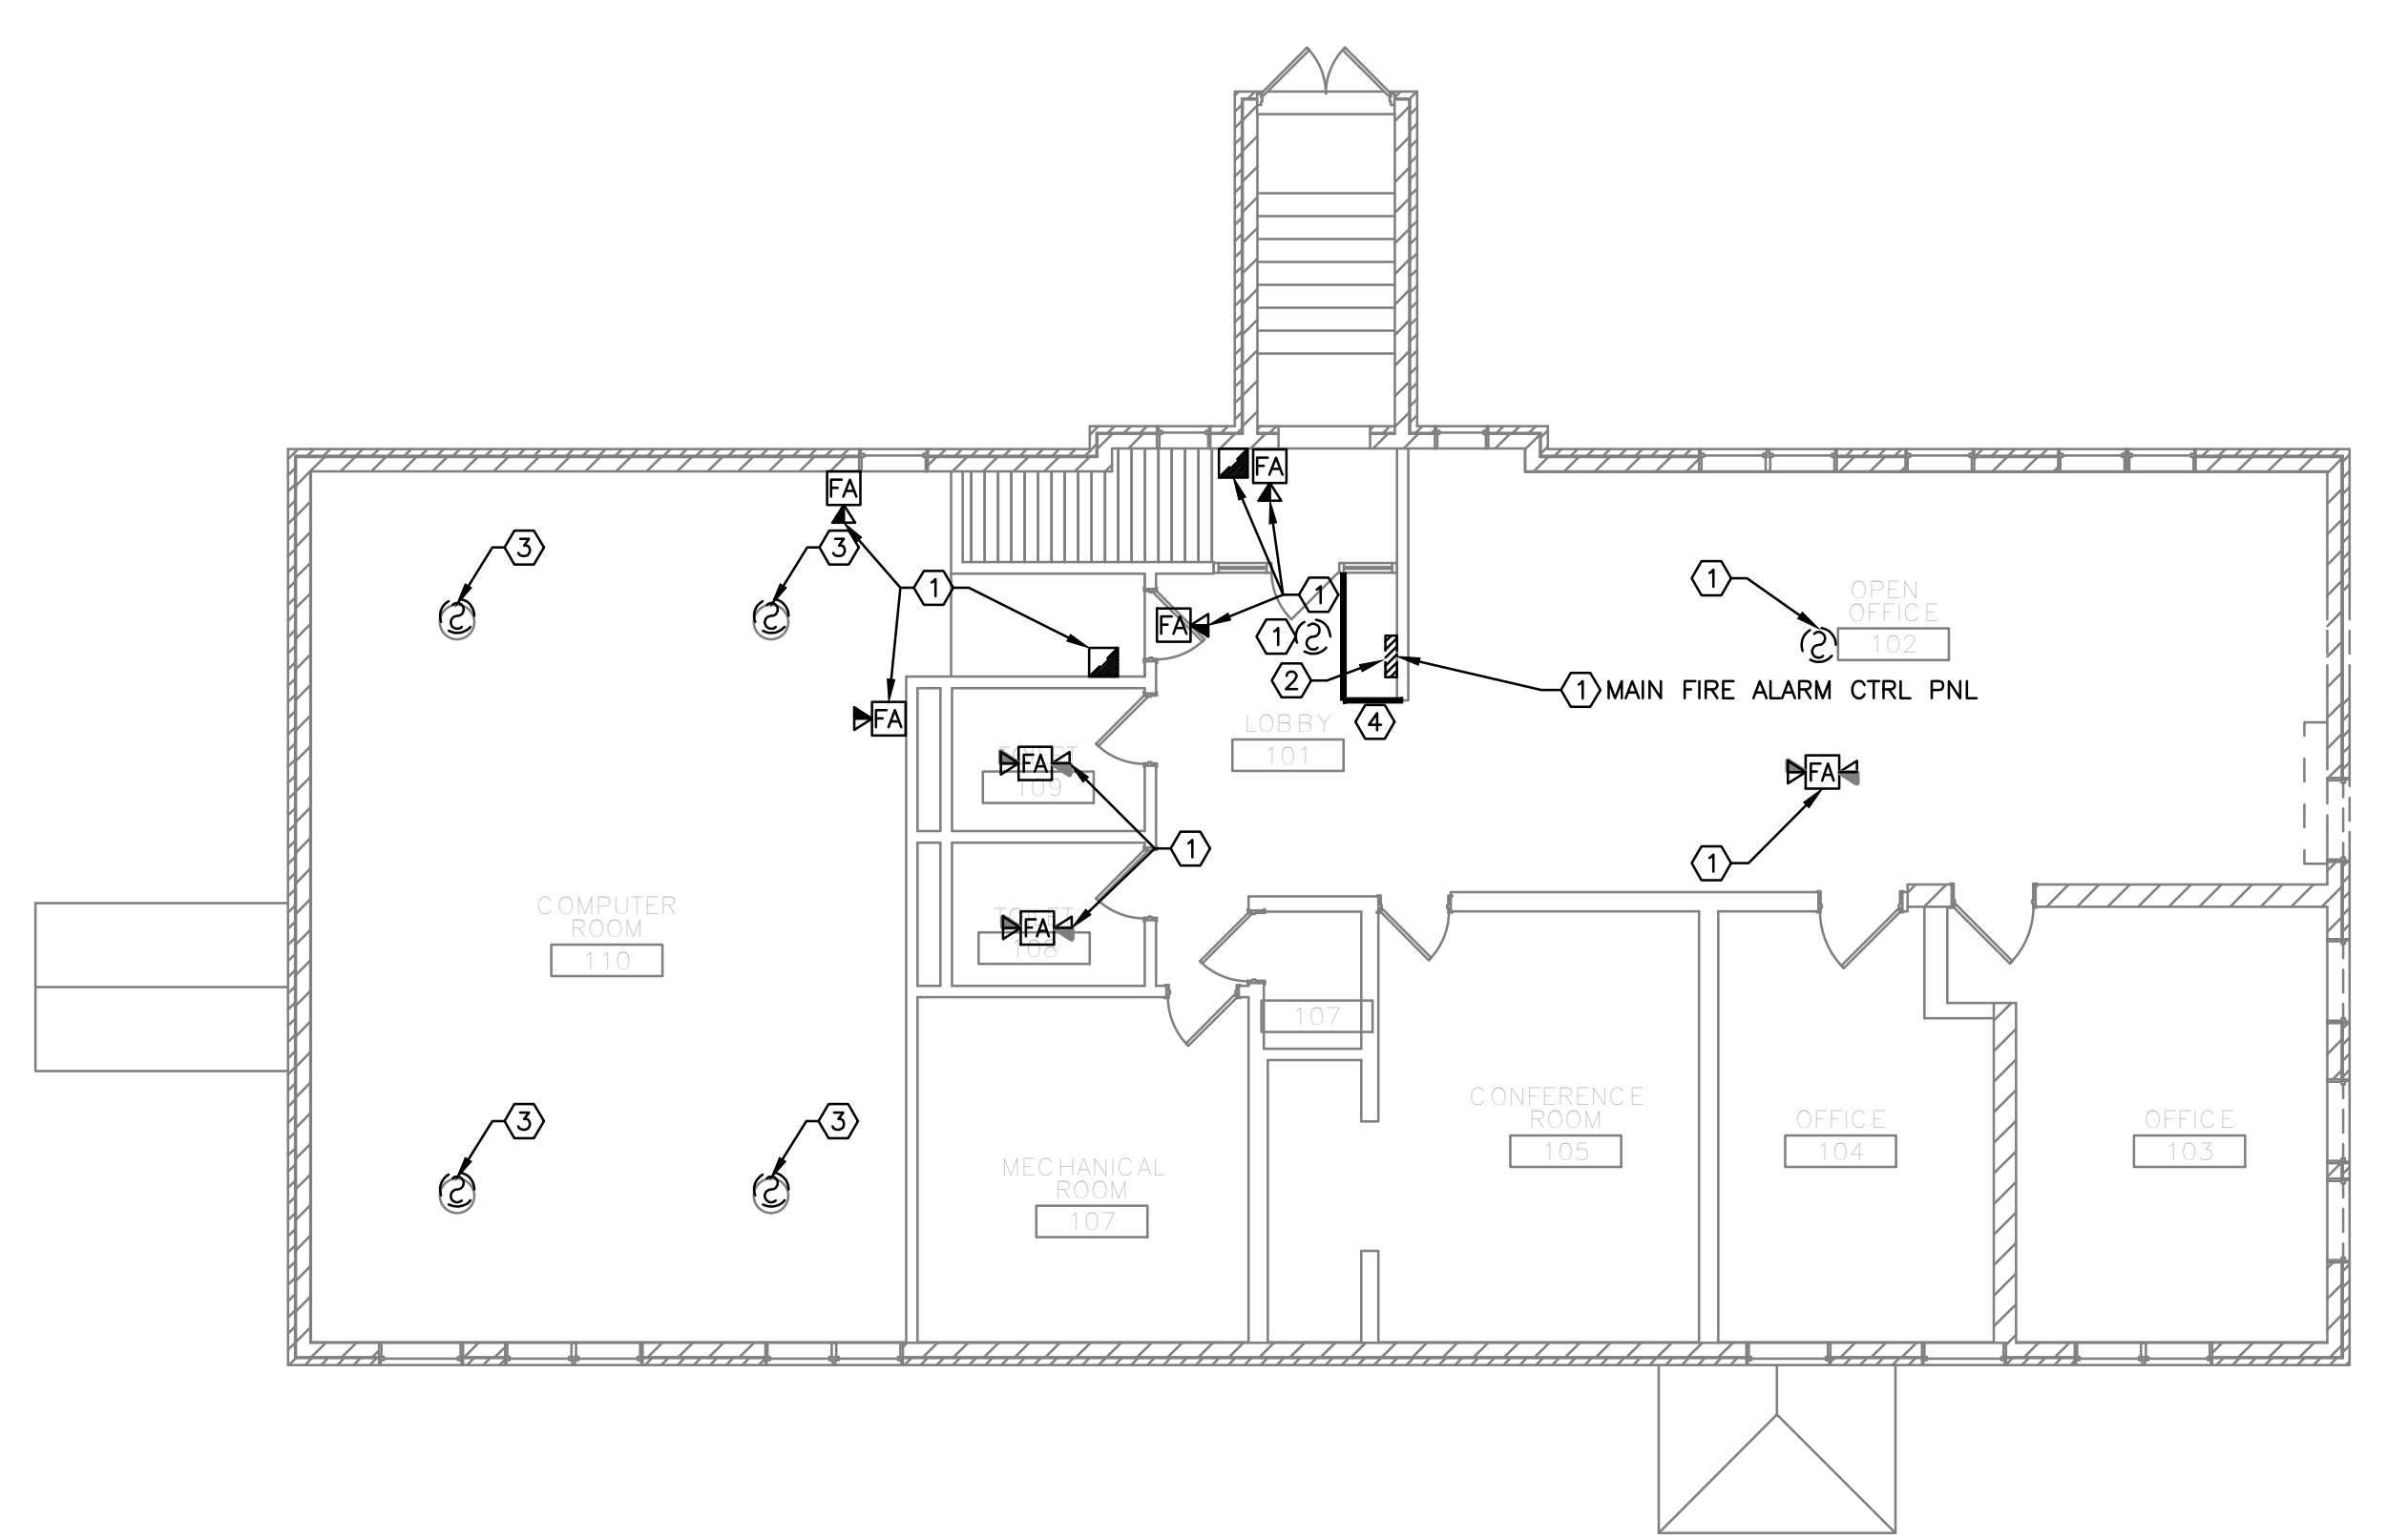

1 FIRST FLOOR
1/8" = 1'-0"

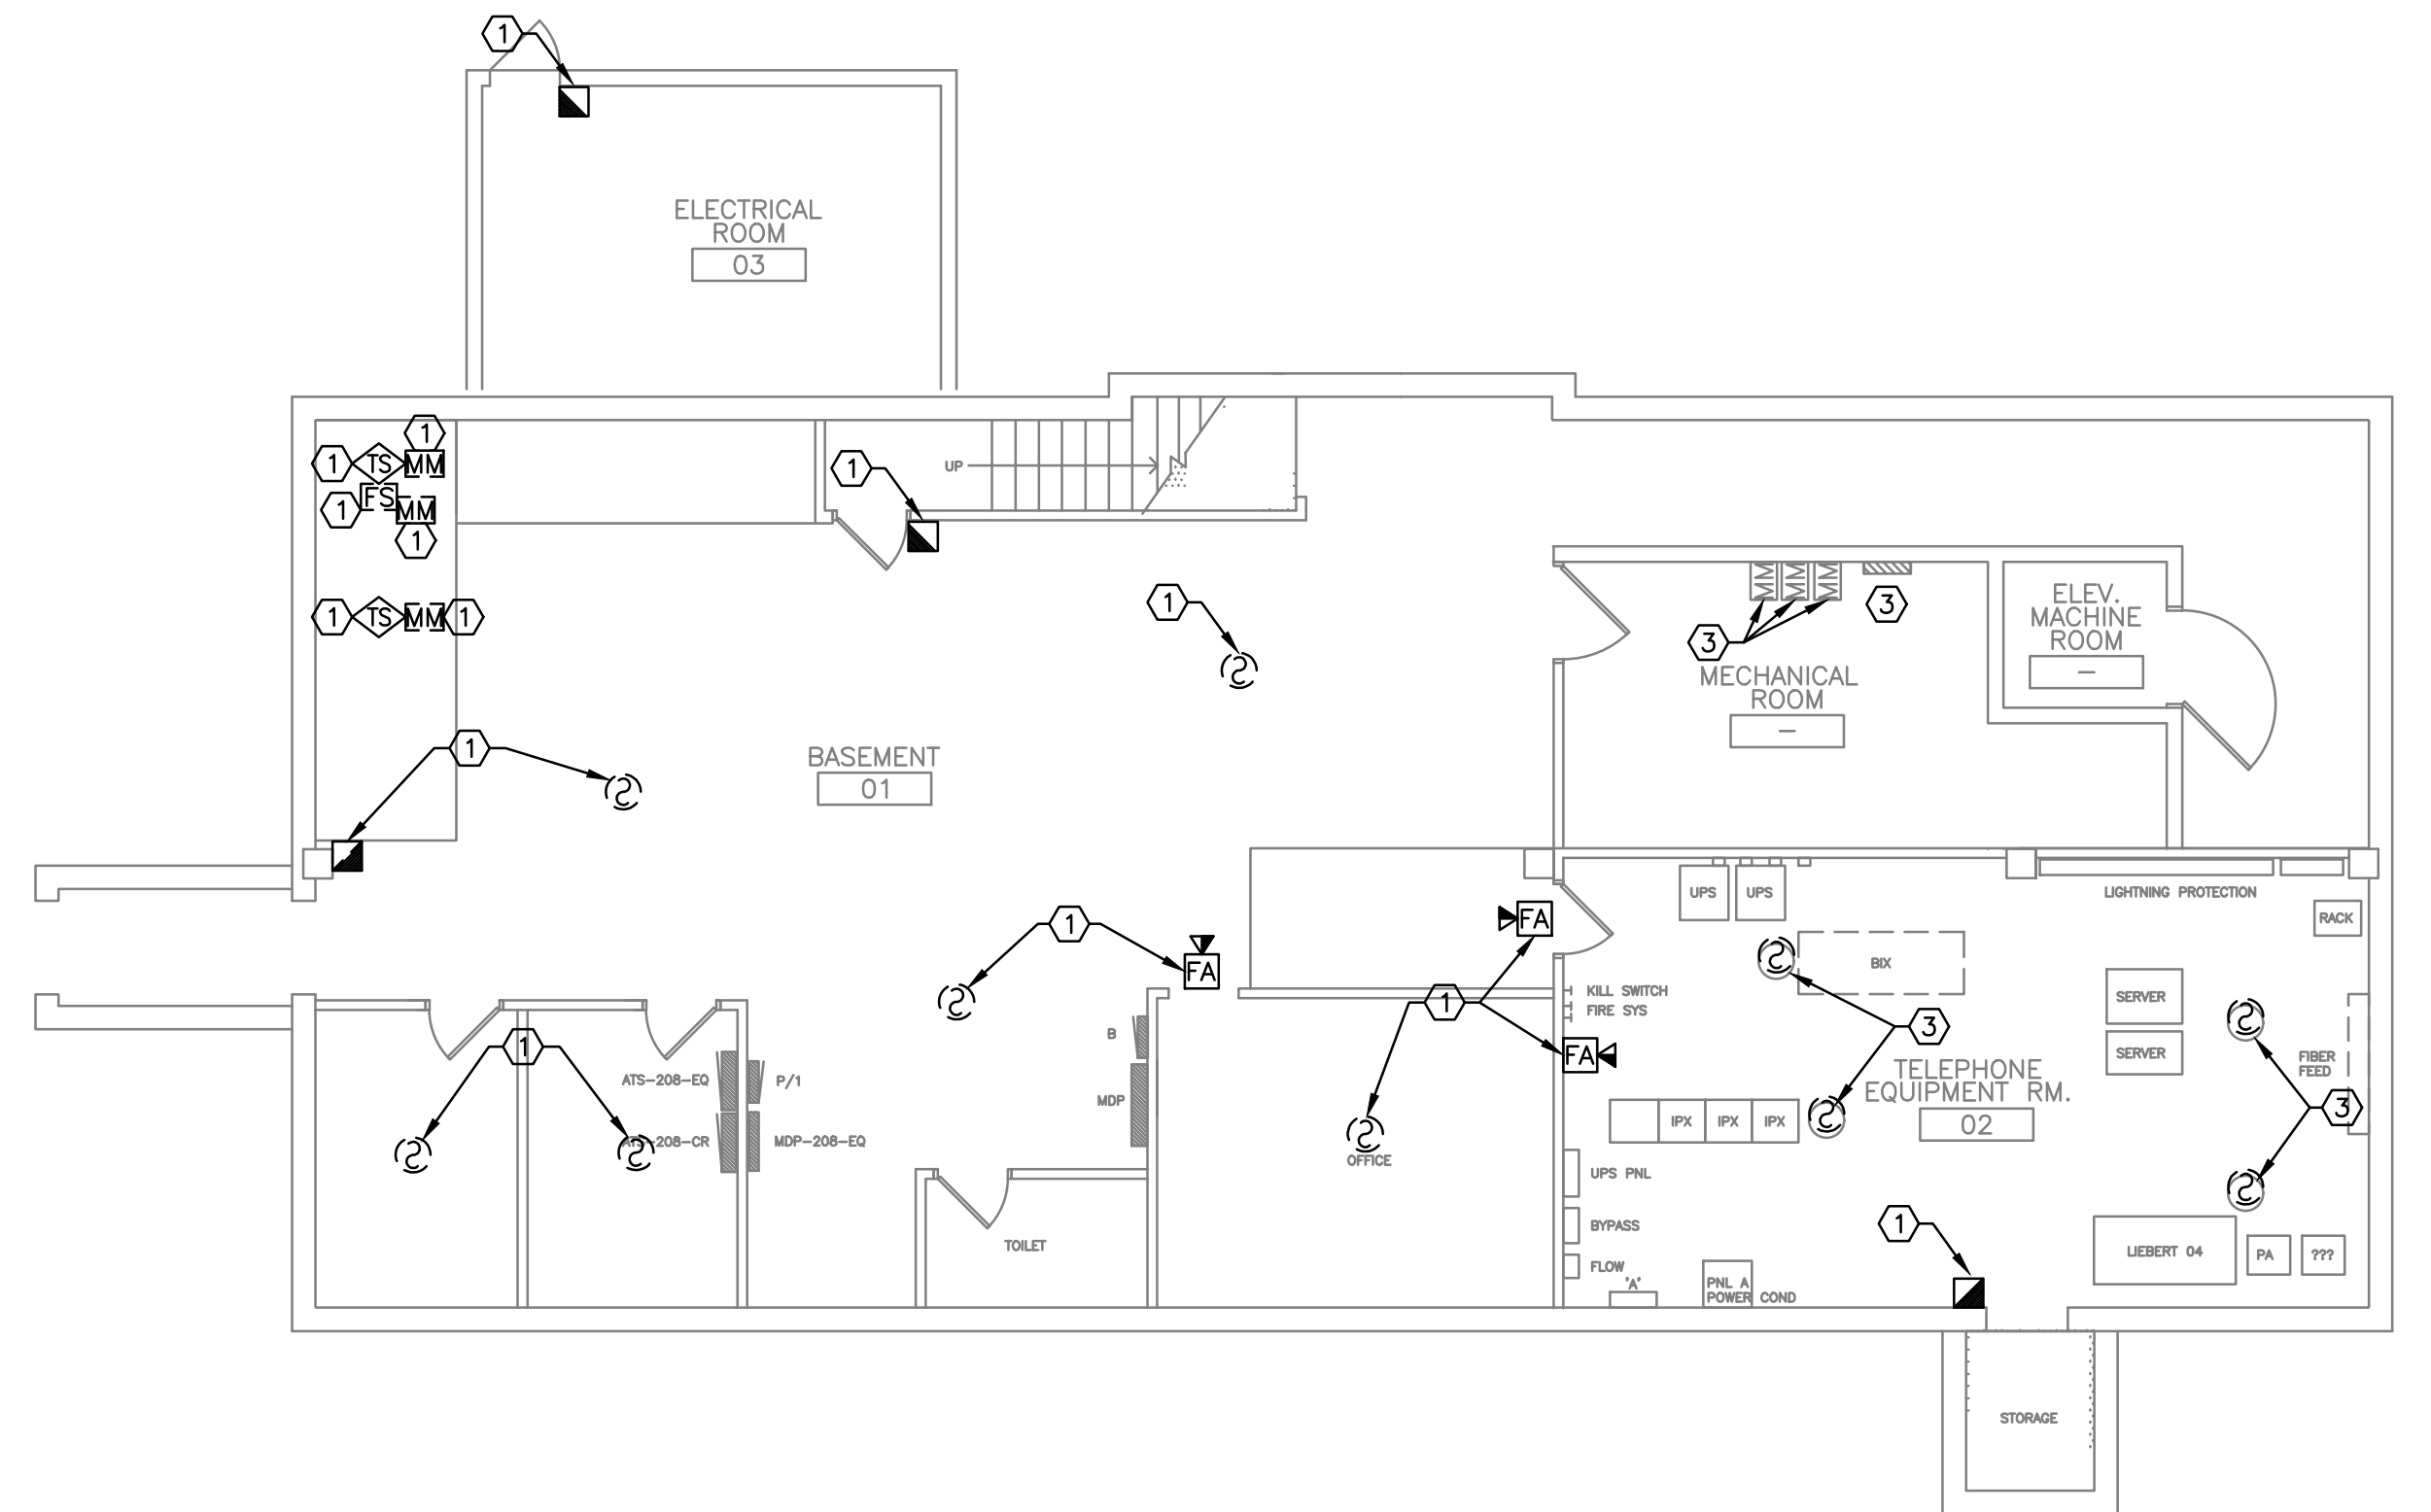

2 BASEMENT FLOOR PLAN
1/8" = 1'-0"

GENERAL NOTES:


- SEE SHEET F001 FOR LEGENDS, NOTES AND ABBREVIATIONS.
- PROTECT ALL DEVICES AND EQUIPMENT TO REMAIN DURING CONSTRUCTION.
- FIRE PROTECTION CONTRACTOR TO REVIEW ARCHITECTURAL AND ELECTRICAL PLANS FOR ADDITIONAL INFORMATION AND REQUIRED WORK NECESSARY TO FACILITATE A COMPLETE SYSTEM AND IS PART OF FIRE PROTECTION CONTRACTOR'S SCOPE OF WORK.
- MAINTAIN CONTINUOUS UTILITY SERVICE TO ALL SPACES IN THE BUILDING NOT AFFECTED BY THIS WORK. COORDINATE WITH VA COR ANY DISRUPTION IN SERVICES REQUIRED TO PERFORM WORK.
- PENETRATIONS THROUGH EXISTING WALLS AND FLOORS REQUIRE FIRE CAULKING BY THIS CONTRACTOR.
- EXISTING SYSTEM LAYOUT IS BASED ON FIELD SURVEY. EXACT LOCATIONS AND ELEVATIONS MAY VARY.
- REFER TO ALL OTHER PLANS, DIAGRAMS, DETAILS AND SPECIFICATIONS TO PROVIDE A FULLY FUNCTIONAL SYSTEM. PROVIDE OFFSETS NOT SHOWN ON DIAGRAMS TO AVOID OBSTRUCTIONS.
- SUPPORT EQUIPMENT, PANELS, DEVICES, CABLES AND WIRING FROM STRUCTURE, WALLS AND FLOOR SO THAT ALL ITEMS ARE ACCESSIBLE FOR MAINTENANCE.
- ALL BUILDINGS WILL BE CONTINUOUSLY OCCUPIED. ALL SYSTEMS MUST BE AVAILABLE BY 7:00 AM AFTER A NIGHT OR ANY SHUT-DOWN.
- THIS CONTRACTOR IS RESPONSIBLE TO MOVE EXISTING FURNITURE OUT OF THE WAY OF THE REQUIRED WORK AND MOVE IT BACK AFTER THE WORK IS COMPLETED.
- DEMOLITION AND REMOVAL OF EXISTING FIRE ALARM DEVICES, CONDUIT, AND ALL OTHER COMPONENTS OF EXISTING FIRE ALARM SYSTEM TO TAKE PLACE AFTER INSTALLATION OF NEW FIRE ALARM SYSTEM IS COMPLETE. SEE DETAILS ON SHEET F501.

KEYED NOTES:

- ① DISCONNECT AND REMOVE EXISTING FA DEVICE. REMOVE WIRING, FITTINGS, SUPPORTS, SYSTEM JUNCTION BOXES, RADIO TRANSMITTERS AND RECEIVERS. WIRING TO BE REMOVED TO THE SOURCE.
- ② WORK TO INSTALL NEW FIRE ALARM PANELS AND REMOVE EXISTING TO TAKE PLACE DURING NORMAL WORK HOURS. SET UP ICB-1 BARRIER. REMOVE ALL TOOLS AND EQUIPMENT DAILY. PROTECT WORK IN PROGRESS SO THAT ANY OPENINGS IN WALLS OR CEILINGS ARE COVERED. SWEEP UP DUST IN AREA AND DAMP MOP FLOOR FOR DAILY CLEAN-UP.
- ③ EXISTING DEVICES TO REMAIN, THEY ARE PART OF A SEPARATE DRY FIRE SUPPRESSION SYSTEM.
- ④ PROVIDE ICB, SEE DETAIL 2 ON DRAWING GC101 FOR REQUIREMENTS.

Revisions: <table><tr><td></td><td></td></tr><tr><td></td><td></td></tr><tr><td></td><td></td></tr><tr><td></td><td></td></tr><tr><td></td><td>Date</td></tr></table>										Date	VETERANS AFFAIRS MEDICAL CENTER 500 E VETERANS ST TOMAH, WI 54660		CONSULTANTS:	PROJECT LEADER: DESIGN / BUILD SERVICES 1021 N. Superior Ave. Unit 11 Tomah, Wisconsin 54660	Drawing Title FIRE ALARM B32 FIRST FLOOR AND BASEMENT PLANS - DEMOLITION Approved: Project Director	Project Title UPGRADE FIRE ALARM SYSTEM DESIGN Location Tomah, Wisconsin Date APRIL 21, 2026 Checked By: HFB Drawn By: JMD	FINAL BID DOCUMENTS Project Number 676-22-110 Building Number B32 Drawing Number FD142 Office of Facilities Management Department of Veterans Affairs
	Date																

three inches = one foot
one and one half inches = one foot
one inch = one foot
three quarters inch = one foot
one half inch = one foot
three eighths inch = one foot
one quarter inch = one foot
one eighth inch = one foot

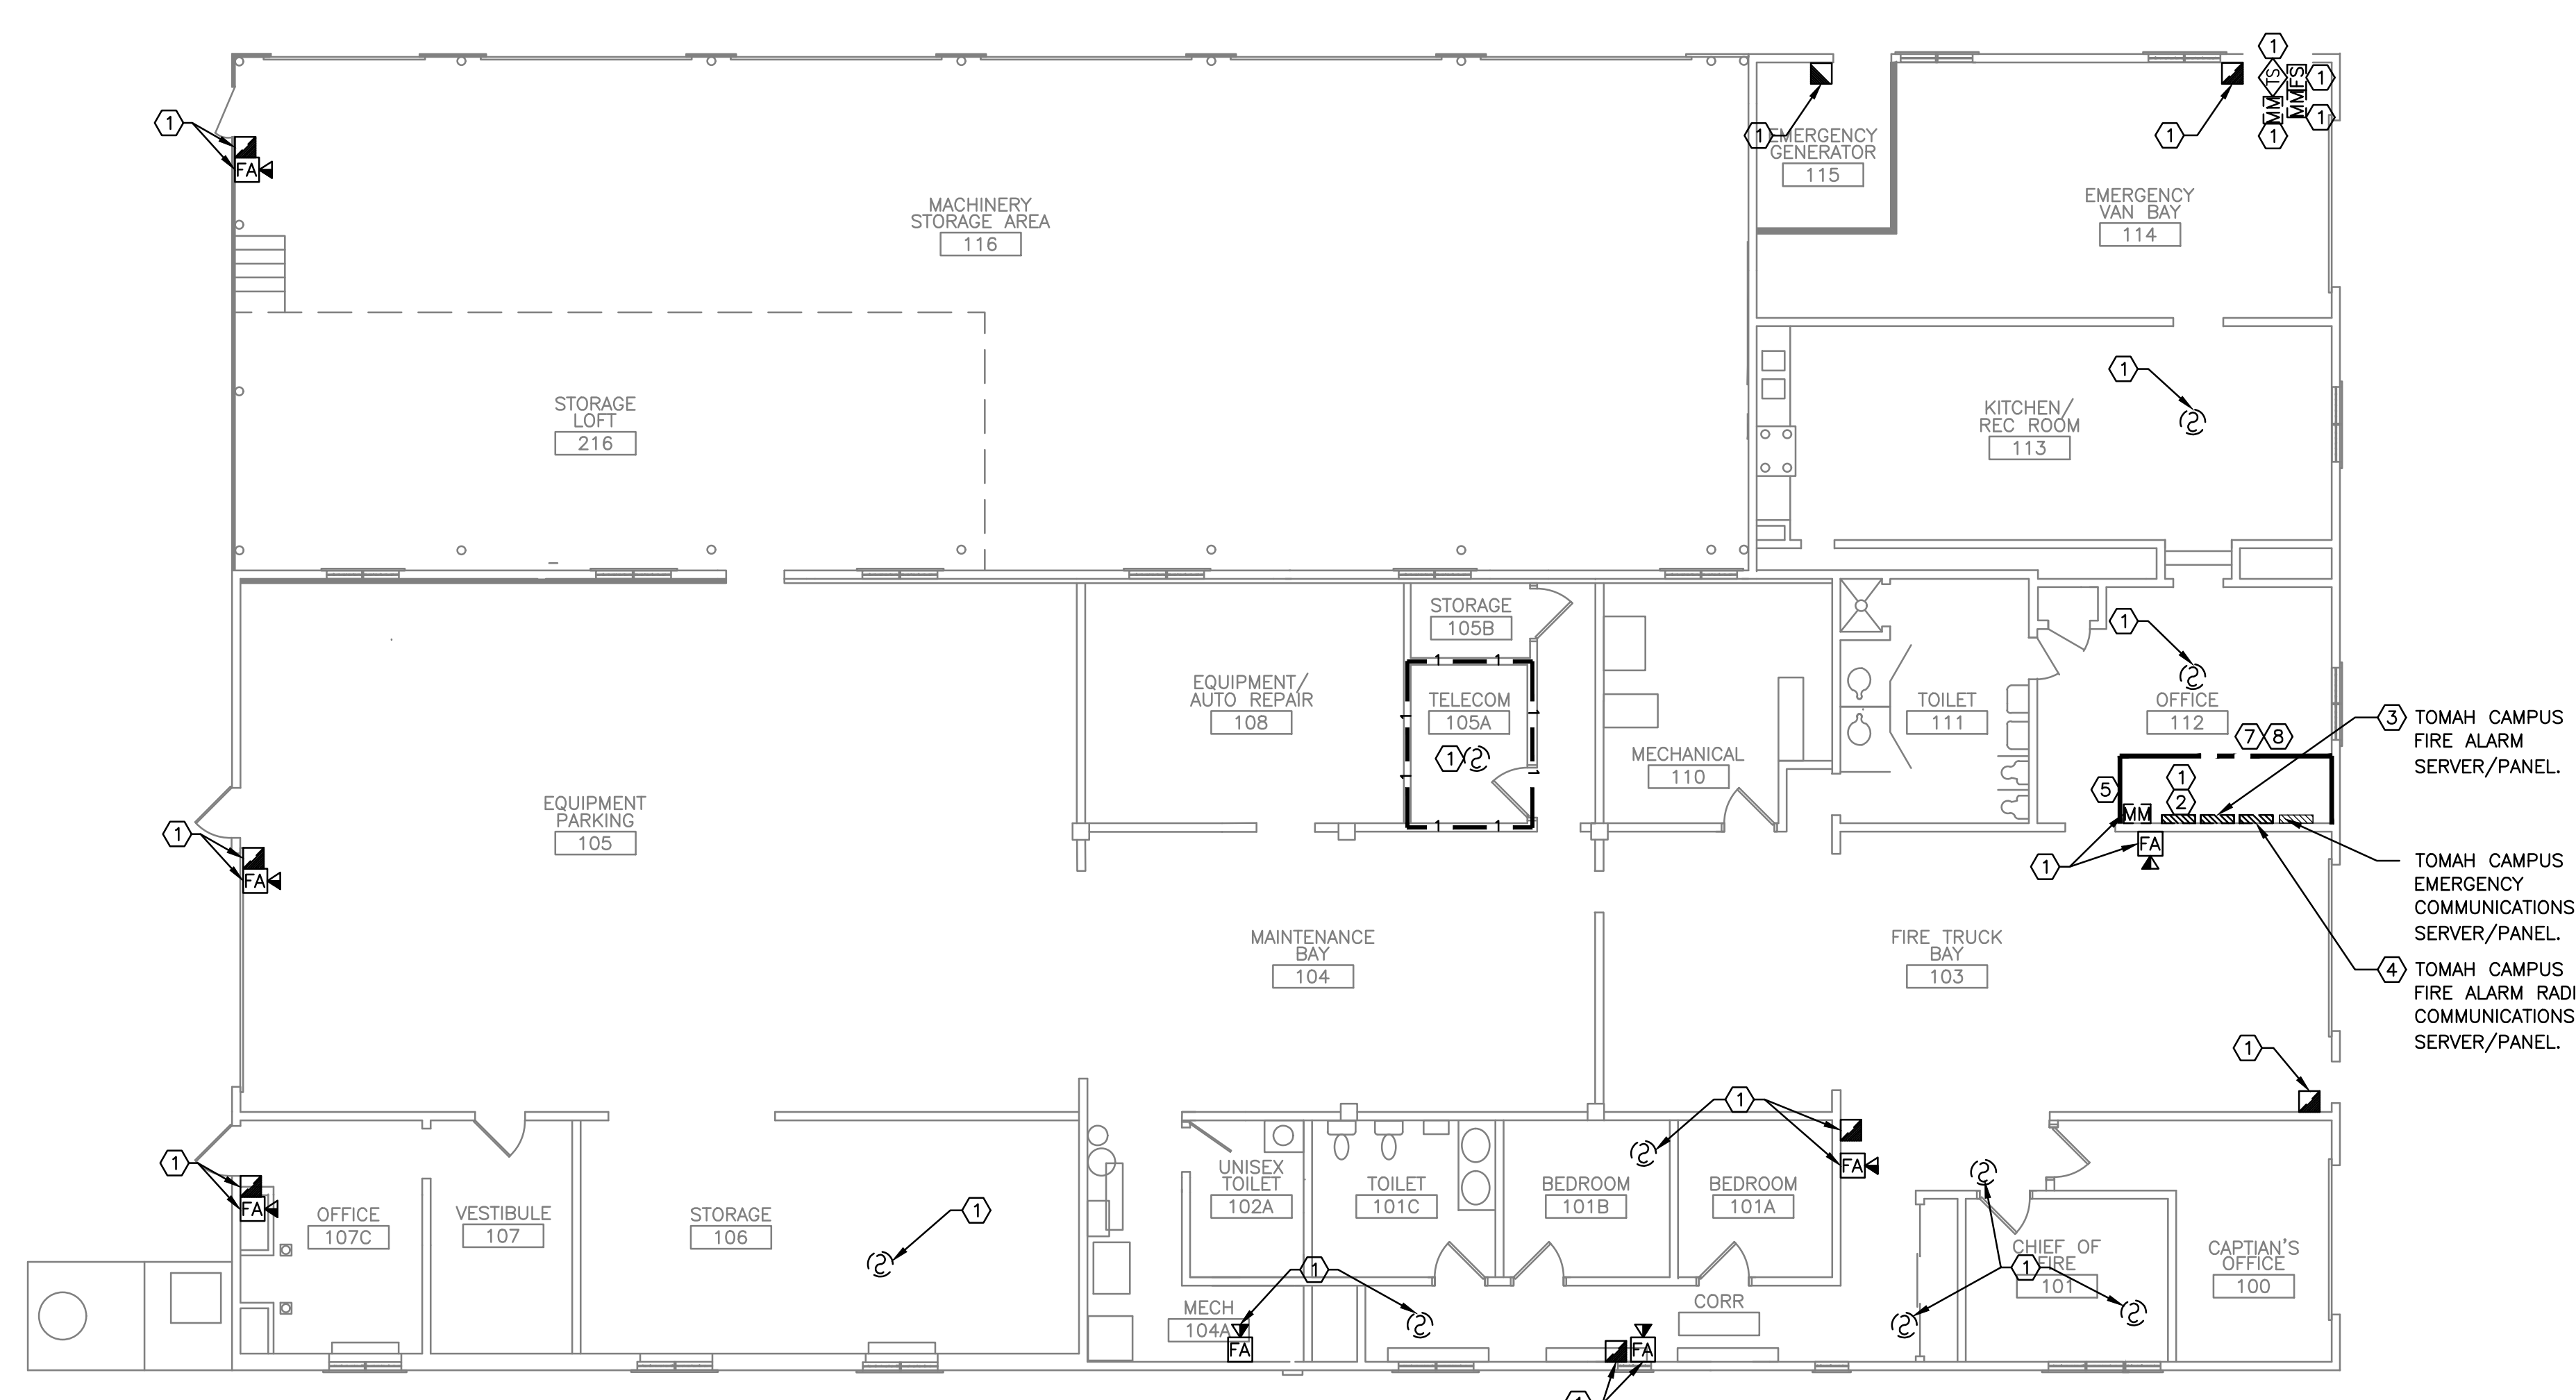

1 B36 - GROUND FLOOR PLAN
1/8" = 1'-0"




2 B40 - GROUND FLOOR PLAN
1/8" = 1'-0"

- GENERAL NOTES:**
- SEE SHEET F001 FOR LEGENDS, NOTES AND ABBREVIATIONS.
 - PROTECT ALL DEVICES AND EQUIPMENT TO REMAIN DURING CONSTRUCTION.
 - FIRE PROTECTION CONTRACTOR TO REVIEW ARCHITECTURAL AND ELECTRICAL PLANS FOR ADDITIONAL INFORMATION AND REQUIRED WORK NECESSARY TO FACILITATE A COMPLETE SYSTEM AND IS PART OF FIRE PROTECTION CONTRACTOR'S SCOPE OF WORK.
 - MAINTAIN CONTINUOUS UTILITY SERVICE TO ALL SPACES IN THE BUILDING NOT AFFECTED BY THIS WORK. COORDINATE WITH VA COR ANY DISRUPTION IN SERVICES REQUIRED TO PERFORM WORK.
 - PENETRATIONS THROUGH EXISTING WALLS AND FLOORS REQUIRE FIRE CAULKING BY THIS CONTRACTOR.
 - EXISTING SYSTEM LAYOUT IS BASED ON FIELD SURVEY. EXACT LOCATIONS AND ELEVATIONS MAY VARY.
 - REFER TO ALL OTHER PLANS, DIAGRAMS, DETAILS AND SPECIFICATIONS TO PROVIDE A FULLY FUNCTIONAL SYSTEM. PROVIDE OFFSETS NOT SHOWN ON DIAGRAMS TO AVOID OBSTRUCTIONS.
 - SUPPORT EQUIPMENT, PANELS, DEVICES, CABLES AND WIRING FROM STRUCTURE, WALLS AND FLOOR SO THAT ALL ITEMS ARE ACCESSIBLE FOR MAINTENANCE.
 - ALL BUILDINGS WILL BE CONTINUOUSLY OCCUPIED. ALL SYSTEMS MUST BE AVAILABLE BY 7:00 AM AFTER A NIGHT OR ANY SHUT-DOWN.
 - THIS CONTRACTOR IS RESPONSIBLE TO MOVE EXISTING FURNITURE OUT OF THE WAY OF THE REQUIRED WORK AND MOVE IT BACK AFTER THE WORK IS COMPLETED.
 - DEMOLITION AND REMOVAL OF EXISTING FIRE ALARM DEVICES, CONDUIT, AND ALL OTHER COMPONENTS OF EXISTING FIRE ALARM SYSTEM TO TAKE PLACE AFTER INSTALLATION OF NEW FIRE ALARM SYSTEM IS COMPLETE. SEE DETAILS ON SHEET F501.

- KEYED NOTES:**
- DISCONNECT AND REMOVE EXISTING FA DEVICE. REMOVE WIRING, FITTINGS, SUPPORTS, SYSTEM JUNCTION BOXES, RADIO TRANSMITTERS AND RECEIVERS. WIRING TO BE REMOVED TO THE SOURCE.
 - WORK TO INSTALL NEW FIRE ALARM PANELS AND REMOVE EXISTING TO TAKE PLACE DURING NORMAL WORK HOURS. SET UP ICB-1 BARRIER. REMOVE ALL TOOLS AND EQUIPMENT DAILY. PROTECT WORK IN PROGRESS SO THAT ANY OPENINGS IN WALLS OR CEILINGS ARE COVERED. SWEEP UP DUST IN AREA AND DAMP MOP FLOOR FOR DAILY CLEAN-UP.
 - EXISTING CAMPUS FIRE ALARM MAIN CONTROL VIRTUAL SERVER WITH CONTROL PANEL AND EMERGENCY COMMUNICATIONS LOCATED HERE. THE EXISTING FIRE ALARM MUST REMAIN ACTIVE WHILE ANY REMOTE BUILDING'S FACP AND FIRE ALARM SYSTEM IS OPERATIONAL. ONLY WHEN EVERY NEW BUILDING SYSTEMS ARE FULLY OPERATIONAL, COMMISSIONED, AND ACCEPTED BY THE TOMAH VA FIRE DEPARTMENT FOR THE ENTIRE CAMPUS MAY THE EXISTING FIRE ALARM MAIN CONTROL SERVER/PANEL BE DE-COMMISSIONED. DO NOT DISTURB OR ALTER THE EMERGENCY COMMUNICATIONS SYSTEM FUNCTIONALITY.
 - EXISTING TOMAH CAMPUS FIRE ALARM RADIO COMMUNICATIONS SYSTEM LOCATION IS IN THIS FIRE DEPARTMENT OPERATIONS ROOM AS WELL. THE EXISTING RADIO SYSTEM MUST REMAIN ACTIVE WHILE ANY REMOTE BUILDING'S FACP AND FIRE ALARM SYSTEM IS OPERATIONAL. ONLY WHEN EVERY NEW BUILDING SYSTEMS ARE FULLY OPERATIONAL, COMMISSIONED, AND ACCEPTED BY THE TOMAH VA FIRE DEPARTMENT FOR THE ENTIRE CAMPUS MAY THE EXISTING FIRE ALARM RADIO SYSTEM BE DE-COMMISSIONED.
 - PROVIDE ICB, SEE DETAIL 1 ON DRAWING GC101 FOR REQUIREMENTS. COORDINATE LOCATION AND DURATION WITH FIRE DEPARTMENT PERSONNEL. THE FIRE DEPARTMENT PERSONNEL MUST BE ABLE TO FREELY ACCESS THE EXISTING CAMPUS FIRE ALARM MAIN CONTROL SERVER/PANEL, EMERGENCY COMMUNICATIONS SYSTEM, AND FIRE ALARM RADIO SYSTEM, 24 HOURS PER DAY, 7 DAYS PER WEEK, NO EXCEPTIONS.
 - PROVIDE ICB, SEE DETAIL 2 ON DRAWING GC101 FOR REQUIREMENTS.
 - THE NEW FIRE ALARM DETECTION AND ALARM SYSTEM SHALL UTILIZE RADIO FREQUENCY (RF) TO COMMUNICATION WITH THE FIRE COMMAND CENTER, LOCATED IN BUILDING 36, AND POLICE STATION, LOCATED IN BUILDING 407. THE NEW FIRE ALARM DETECTION AND ALARM SYSTEM SHALL HAVE A RF ANTENNA INTERNAL TO THE UNIT. THE NEW FIRE ALARM DETECTION AND ALARM SYSTEM SHALL HAVE A COMMAND CENTER CONSOLE AND DISPLAYS LOCATED IN BUILDINGS 36 AND 407. THE FIRE ALARM DETECTION AND ALARM SYSTEM SOFTWARE SHALL BE INSTALLED ON A MAIN SERVER IN BUILDING 32 IN THE COMPUTER ROOM DESIGNATED BY THE IT OPERATIONS AT THE TOMAH VHA MEDICAL CENTER.
 - THE CONTRACTOR SHALL CONDUCT ACCEPTANCE TESTING FOR EVERY FACP AND BUILDING THAT BECOMES ACTIVE WITHIN THE NEW FIRE ALARM DETECTION AND ALARM SYSTEM PROGRAMMING, AND ACCORDING TO A SCHEDULE COORDINATED WITH COR AND COR. EITHER OR BOTH MAY ELECT TO BE IN ATTENDANCE TO WITNESS THE TEST PROCEDURES. NOTIFY THE FIRE DEPARTMENT AND POLICE DEPARTMENT IN ADVANCE, 10 WORKING DAYS OF THE PROPOSED SCHEDULED DATE. THE CONTRACTOR SHALL PROVIDE A COMPETENT PERSON AT EACH LOCATION (B36 AND B407) AND AT LEAST ONE TECHNICIAN FROM THE NEW FIRE ALARM DETECTION AND ALARM SYSTEM'S COMPANY AT EACH LOCATION (B36 AND B407) TO LEAD THE PROCESS FOR EACH NEW FACP INTO THE OVERALL SYSTEM. THE NOTIFICATION SHALL INCLUDE A WRITTEN DESCRIPTION OF THE PROPOSED CONDUCT OF THE TESTS INCLUDING COPIES OF BLANK TEST RESULT SHEETS TO BE USED.

 VETERANS AFFAIRS MEDICAL CENTER 500 E VETERANS ST TOMAH, WI 54660			CONSULTANTS:	PROJECT LEADER:  PCG DESIGN / BUILD SERVICES 1021 N. Superior Ave, Unit 11 Tomah, Wisconsin 54660	Drawing Title FIRE ALARM B36 AND B40 GROUND FLOOR PLANS - DEMOLITION	Project Title UPGRADE FIRE ALARM SYSTEM DESIGN	FINAL BID DOCUMENTS Project Number 676-22-110 Building Number B36/B40 Drawing Number FD143		Office of Facilities Management 				
Revisions:		Date:		Approved: Project Director		Location Tomah, Wisconsin		Date APRIL 21, 2026		Checked By: HFB		Drawn By: JMD	

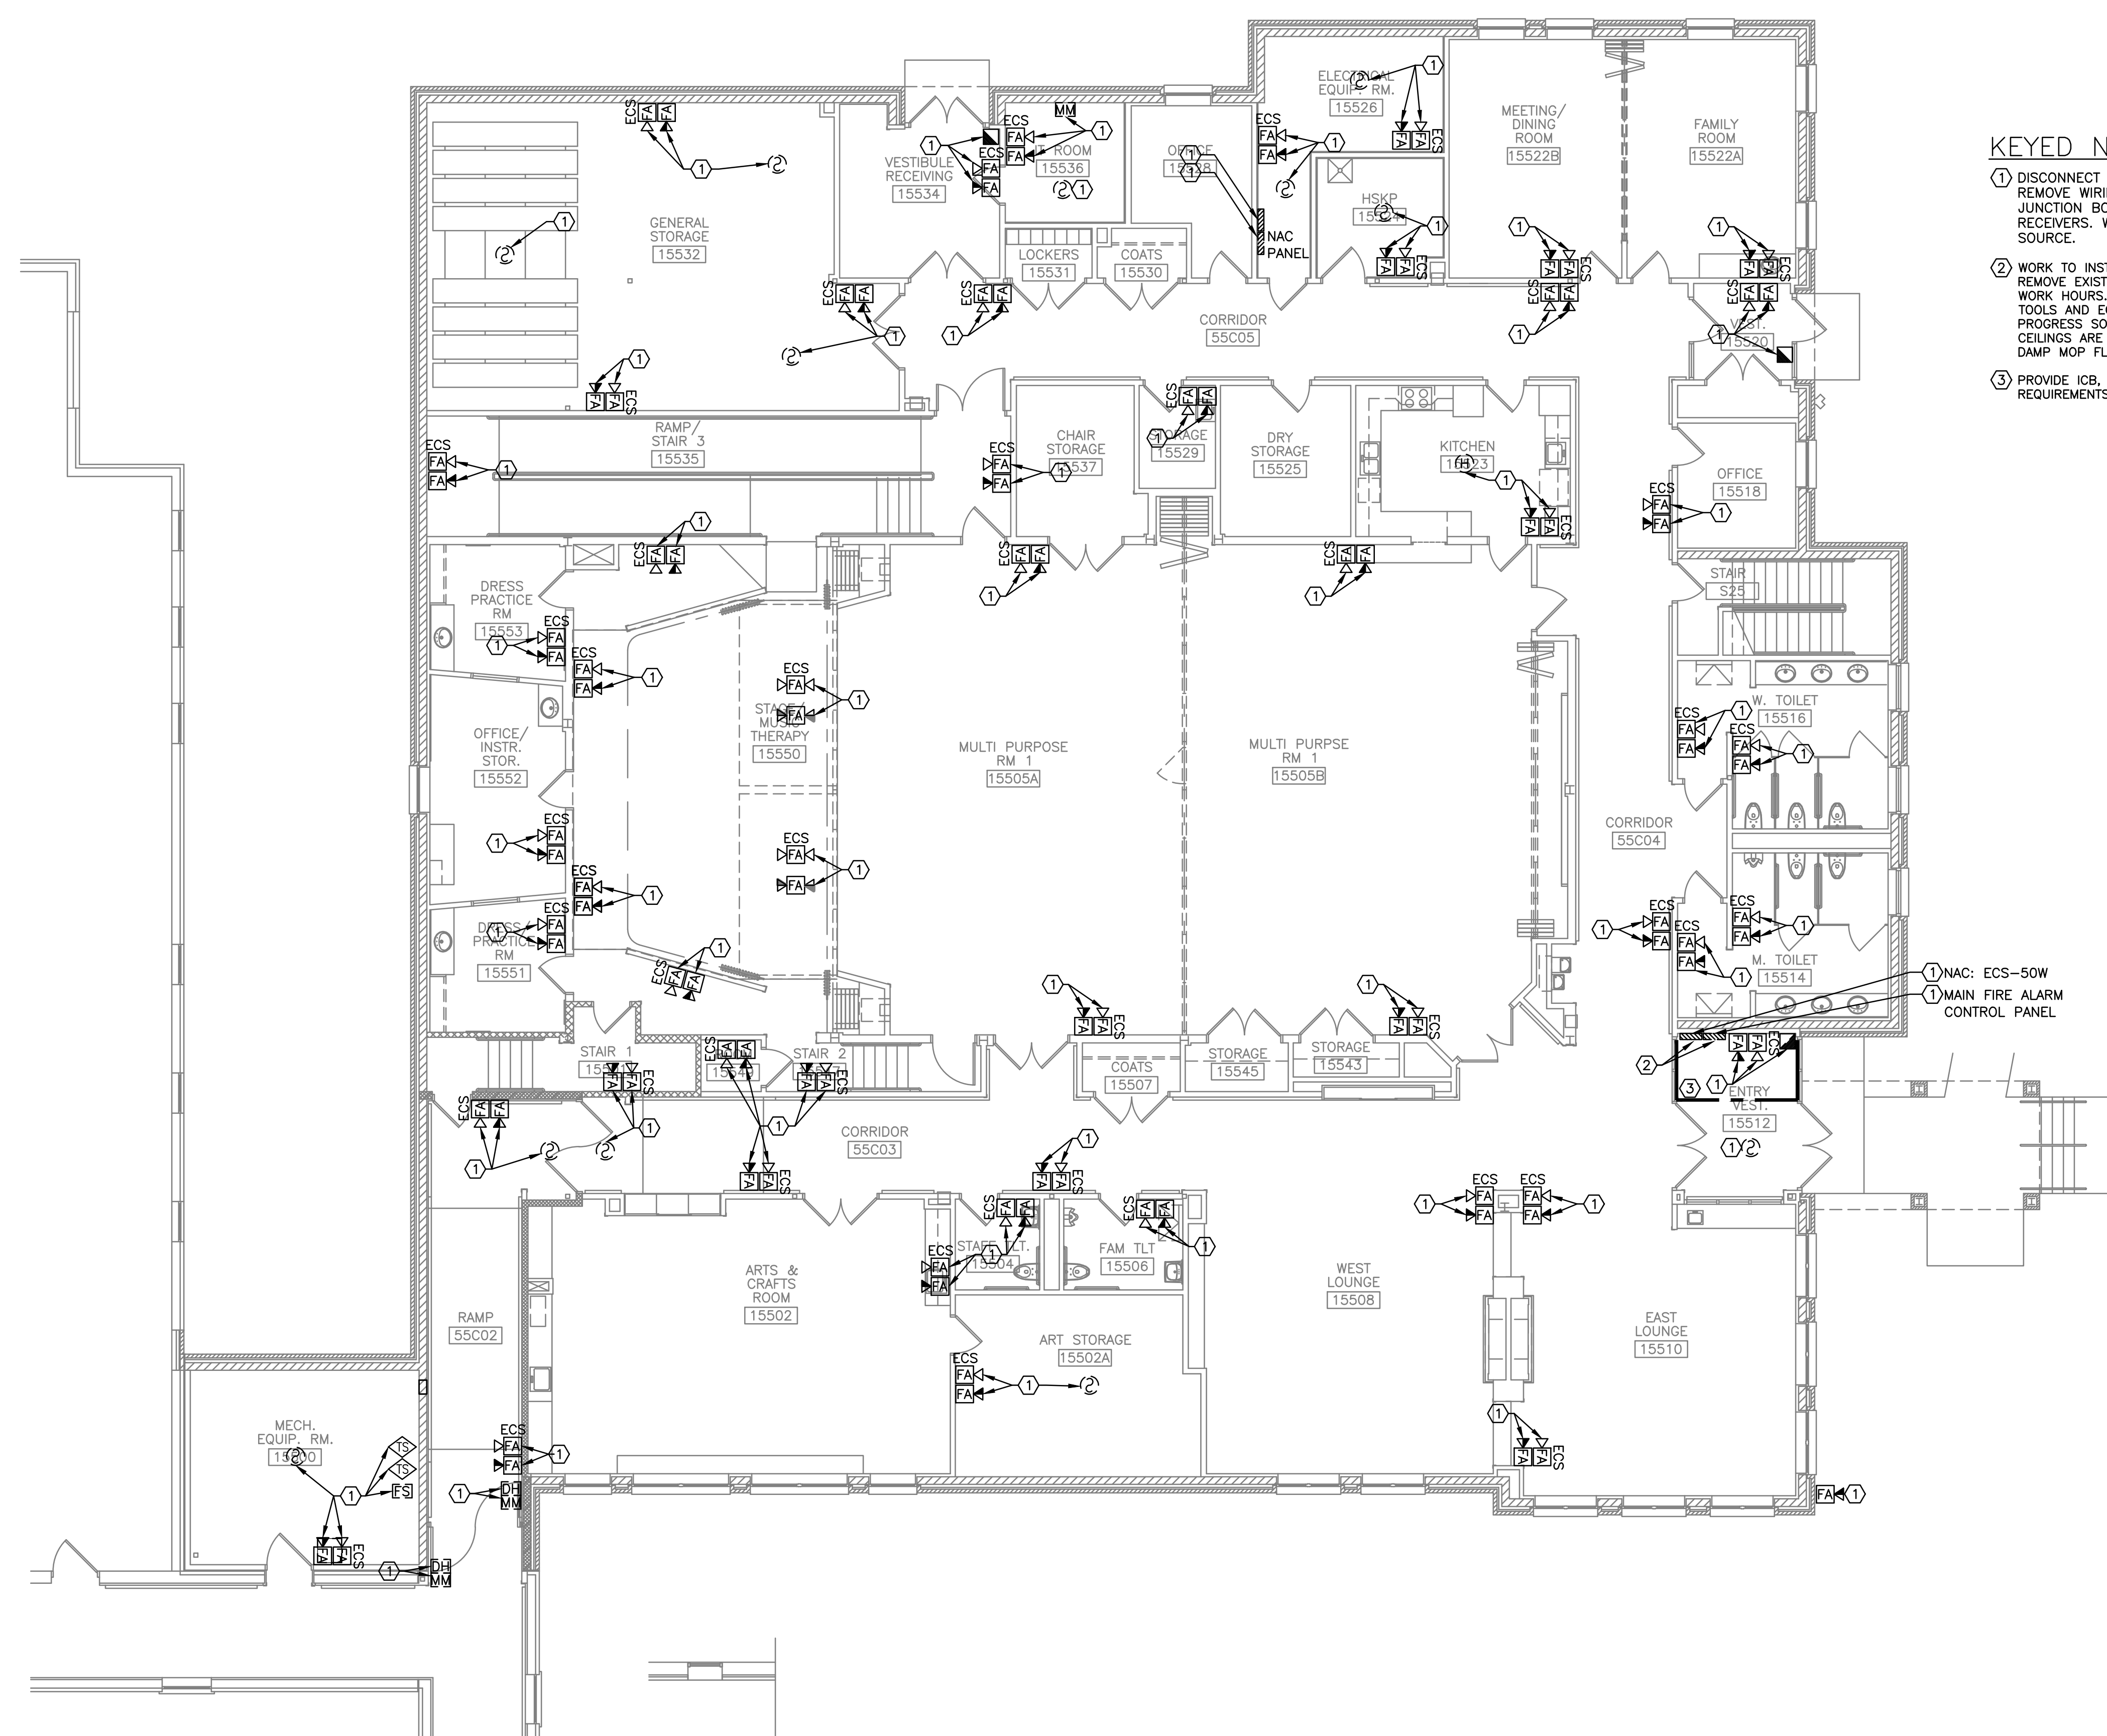


KEYED NOTES:

- ① DISCONNECT AND REMOVE EXISTING FA DEVICE. REMOVE WIRING, FITTINGS, SUPPORTS, SYSTEM JUNCTION BOXES, RADIO TRANSMITTERS AND RECEIVERS. WIRING TO BE REMOVED TO THE SOURCE.
- ② WORK TO INSTALL NEW FIRE ALARM PANELS AND REMOVE EXISTING TO TAKE PLACE DURING NORMAL WORK HOURS. SET UP ICB-1 BARRIER. REMOVE ALL TOOLS AND EQUIPMENT DAILY. PROTECT WORK IN PROGRESS SO THAT ANY OPENINGS IN WALLS OR FLOORS ARE COVERED WITH PLANKS IN AREA AND DAMP MOP FLOOR FOR DAILY CLEAN-UP.
- ③ PROVIDE ICB, SEE DETAIL 2 ON DRAWING GC101 FOR REQUIREMENTS.

GENERAL NOTES:

1. SEE SHEET F001 FOR LEGENDS, NOTES AND ABBREVIATIONS.
2. PROTECT ALL DEVICES AND EQUIPMENT TO REMAIN DURING CONSTRUCTION.
3. FIRE PROTECTION CONTRACTOR TO REVIEW ARCHITECTURAL AND ELECTRICAL PLANS FOR ADDITIONAL INFORMATION AND REQUIRED WORK NECESSARY TO FACILITATE A COMPLETE SYSTEM AND IS PART OF FIRE PROTECTION CONTRACTOR'S SCOPE OF WORK.
4. MAINTAIN CONTINUOUS UTILITY SERVICE TO ALL SPACES IN THE BUILDING NOT AFFECTED BY THIS WORK. COORDINATE WITH VA COR ANY DISRUPTION IN SERVICES REQUIRED TO PERFORM WORK.
5. PENETRATIONS THROUGH EXISTING WALLS AND FLOORS REQUIRE FIRE CAULKING BY THIS CONTRACTOR.
6. EXISTING SYSTEM LAYOUT IS BASED ON FIELD SURVEY. EXACT LOCATIONS AND ELEVATIONS MAY VARY.
7. REFER TO ALL OTHER PLANS, DIAGRAMS, DETAILS AND SPECIFICATIONS TO PROVIDE A FULLY FUNCTIONAL SYSTEM. PROVIDE OFFSETS NOT SHOWN ON DIAGRAMS TO AVOID OBSTRUCTIONS.
8. SUPPORT EQUIPMENT, PANELS, DEVICES, CABLES AND WIRING FROM STRUCTURE, WALLS AND FLOOR SO THAT ALL ITEMS ARE ACCESSIBLE FOR MAINTENANCE.
9. ALL BUILDINGS WILL BE CONTINUOUSLY OCCUPIED. ALL SYSTEMS MUST BE AVAILABLE BY 7:00 AM AFTER A NIGHT OR ANY SHUT-DOWN.
10. THIS CONTRACTOR IS RESPONSIBLE TO MOVE EXISTING FURNITURE OUT OF THE WAY OF THE REQUIRED WORK AND MOVE IT BACK AFTER THE WORK IS COMPLETED.
11. DEMOLITION AND REMOVAL OF EXISTING FIRE ALARM DEVICES, CONDUIT, AND ALL OTHER COMPONENTS OF EXISTING FIRE ALARM SYSTEM IS TAKE PART IN THE INSTALLATION OF NEW FIRE ALARM SYSTEM IS COMPLETE. SEE DETAILS ON SHEET F501.

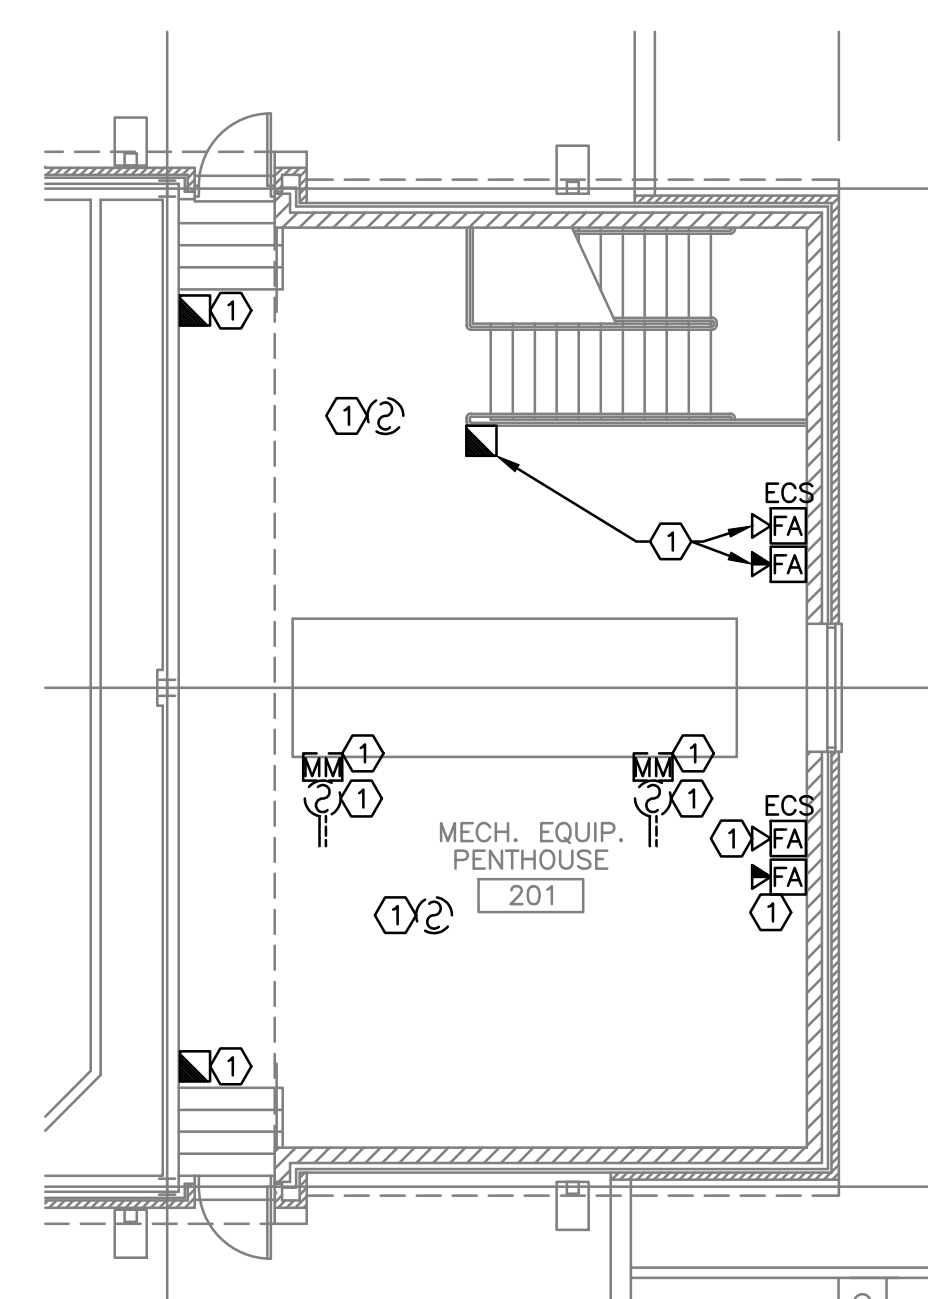

1 FIRST FLOOR PLAN
1/8" = 1'-0"



2 MEZZANINE MECHANICAL ROOM
1/8" = 1'-0"

[illegible]

VETERANS AFFAIRS
MEDICAL CENTER
500 E VETERANS ST
TOMAH, WI 54660



CONSULTANTS:

PROJECT LEADER:



Drawing Title
FIRE ALARM
B455 FIRST FLOOR AND MEZZ.
PLANS - DEMOLITION

Approved: Project Director

Project Title	UPGRADE FIRE ALARM SYSTEM DESIGN
---------------	-------------------------------------

Location	Tomah, Wisconsin
----------	------------------

Date
APRIL 21, 2026

Checked By:
HFB

Drawn By:
JMD


FINAL BID DOCUMENTS

Project Number	676-22-110
Building Number	B455


Drawing Number	ED144
----------------	-------

Office of
Facilities
Management



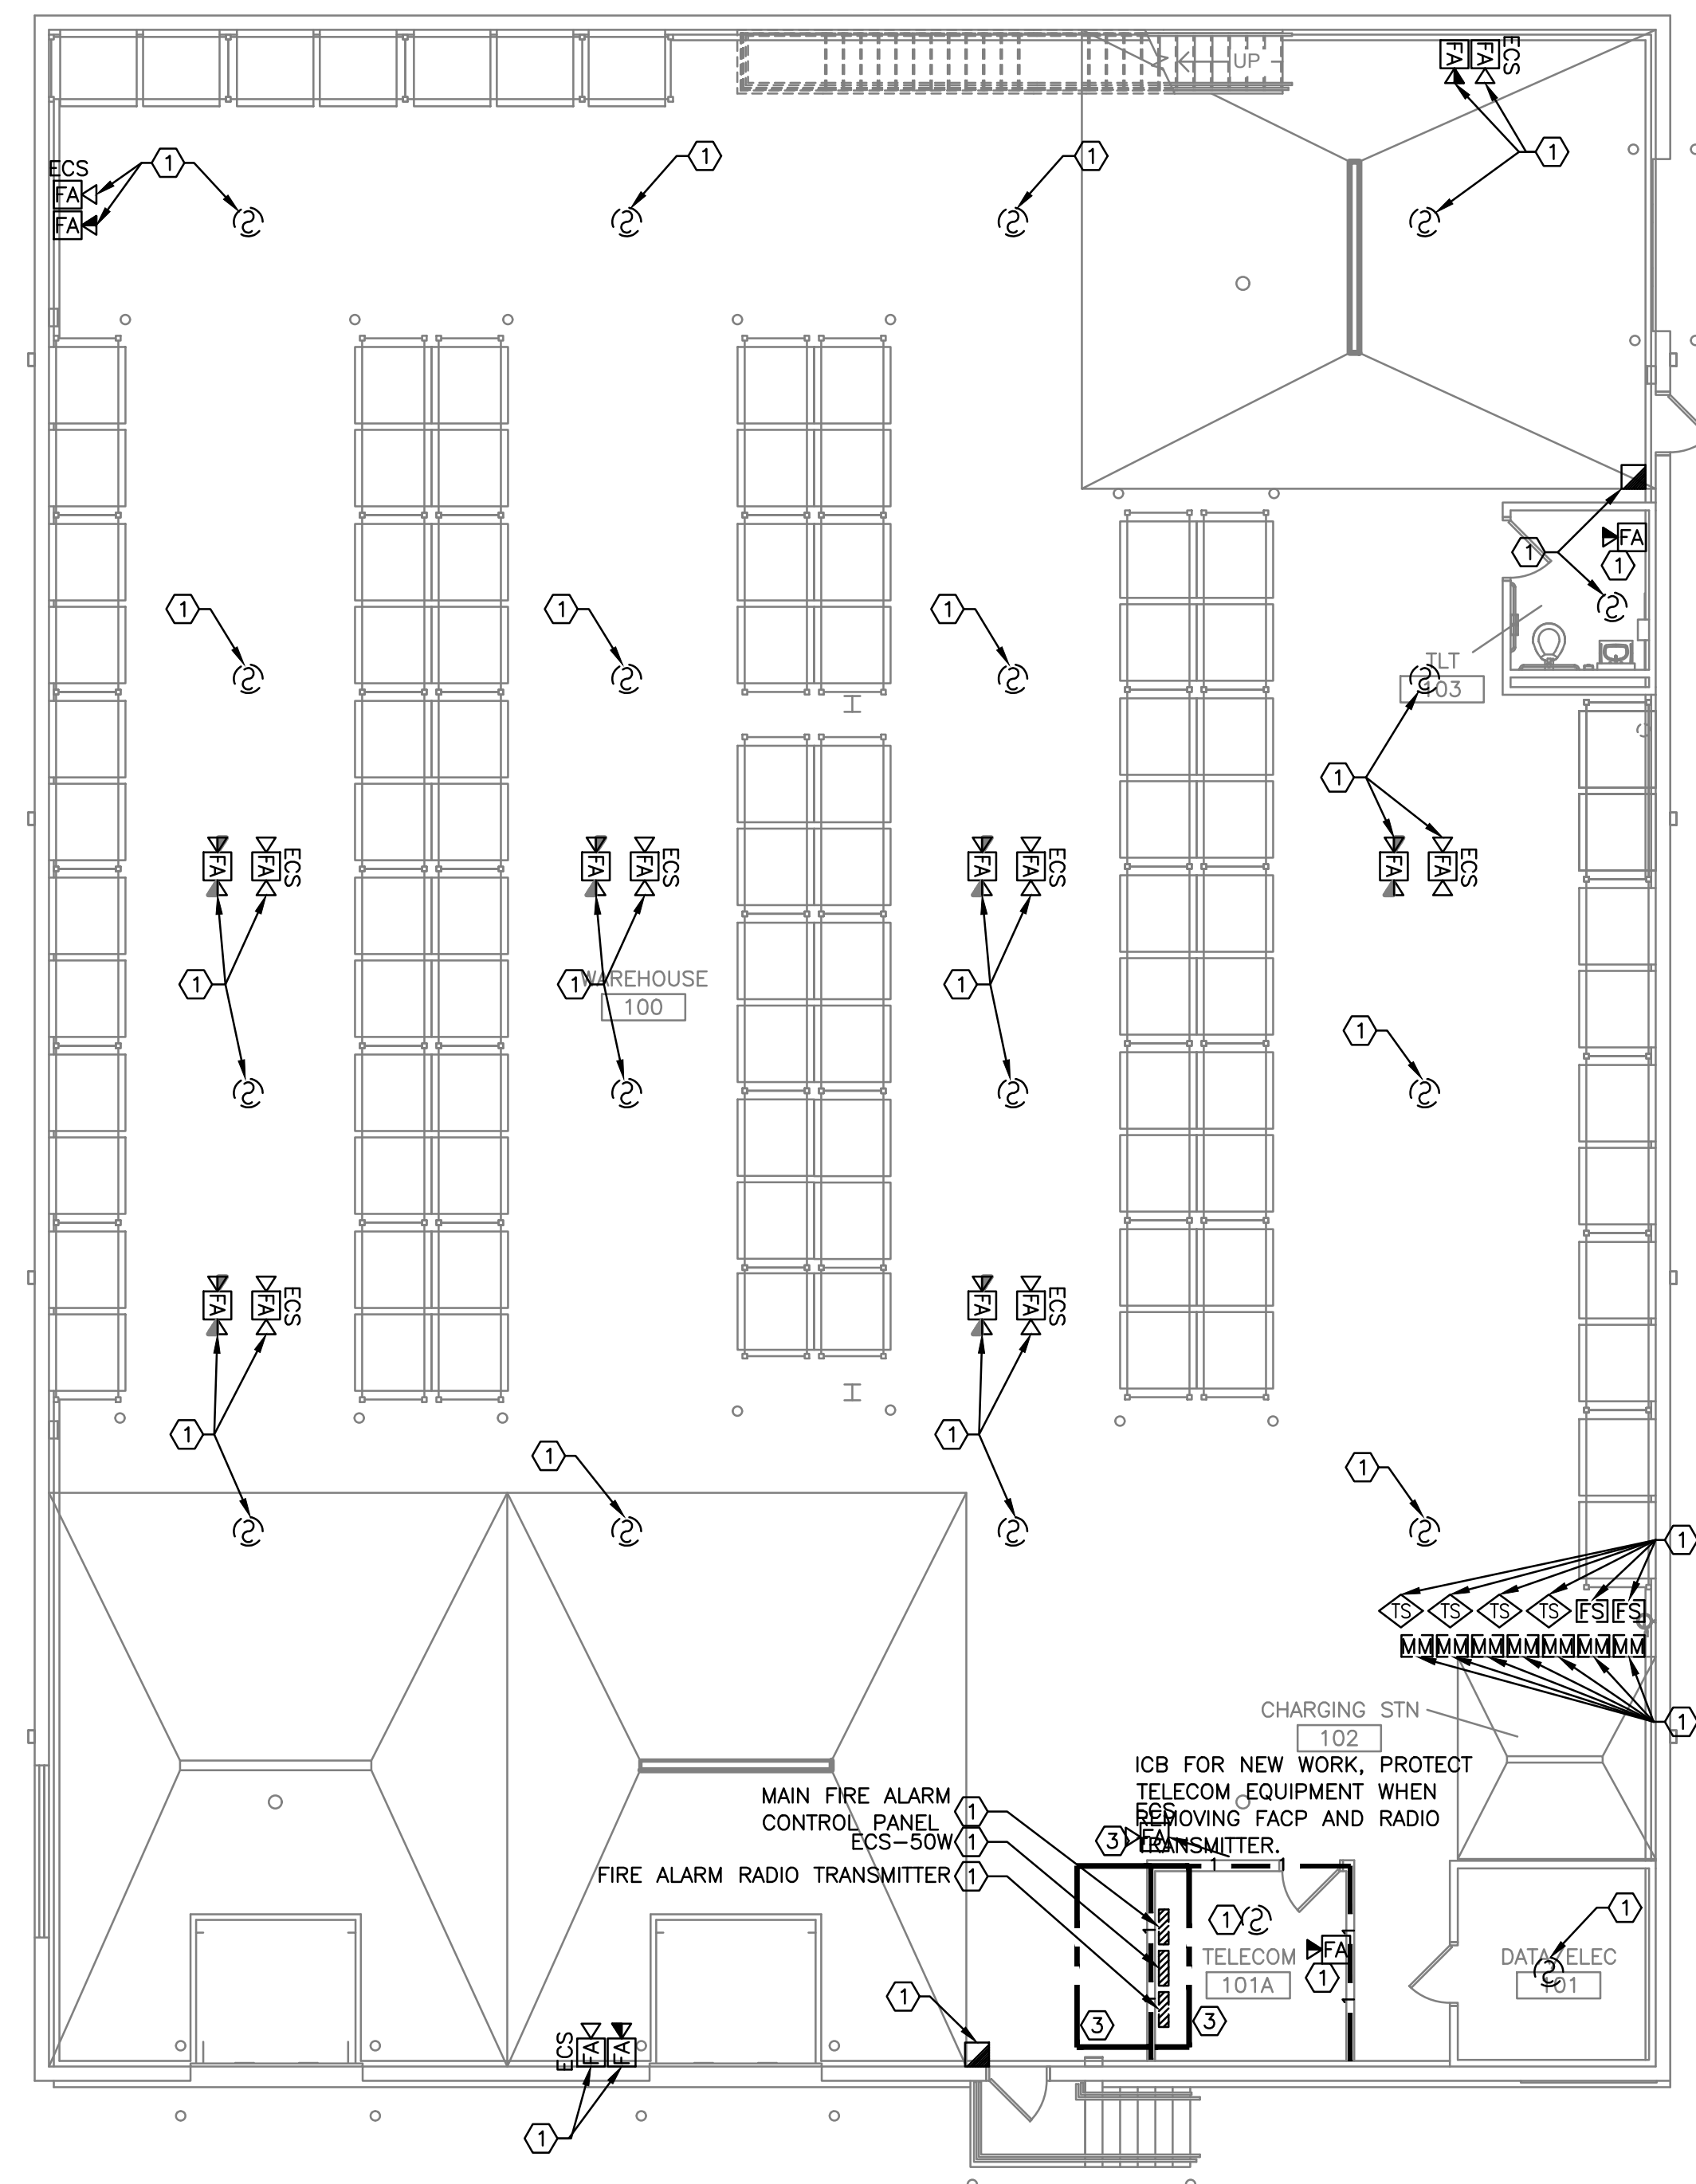

1 B52 - GROUND FLOOR PLAN
1/8" = 1'-0"

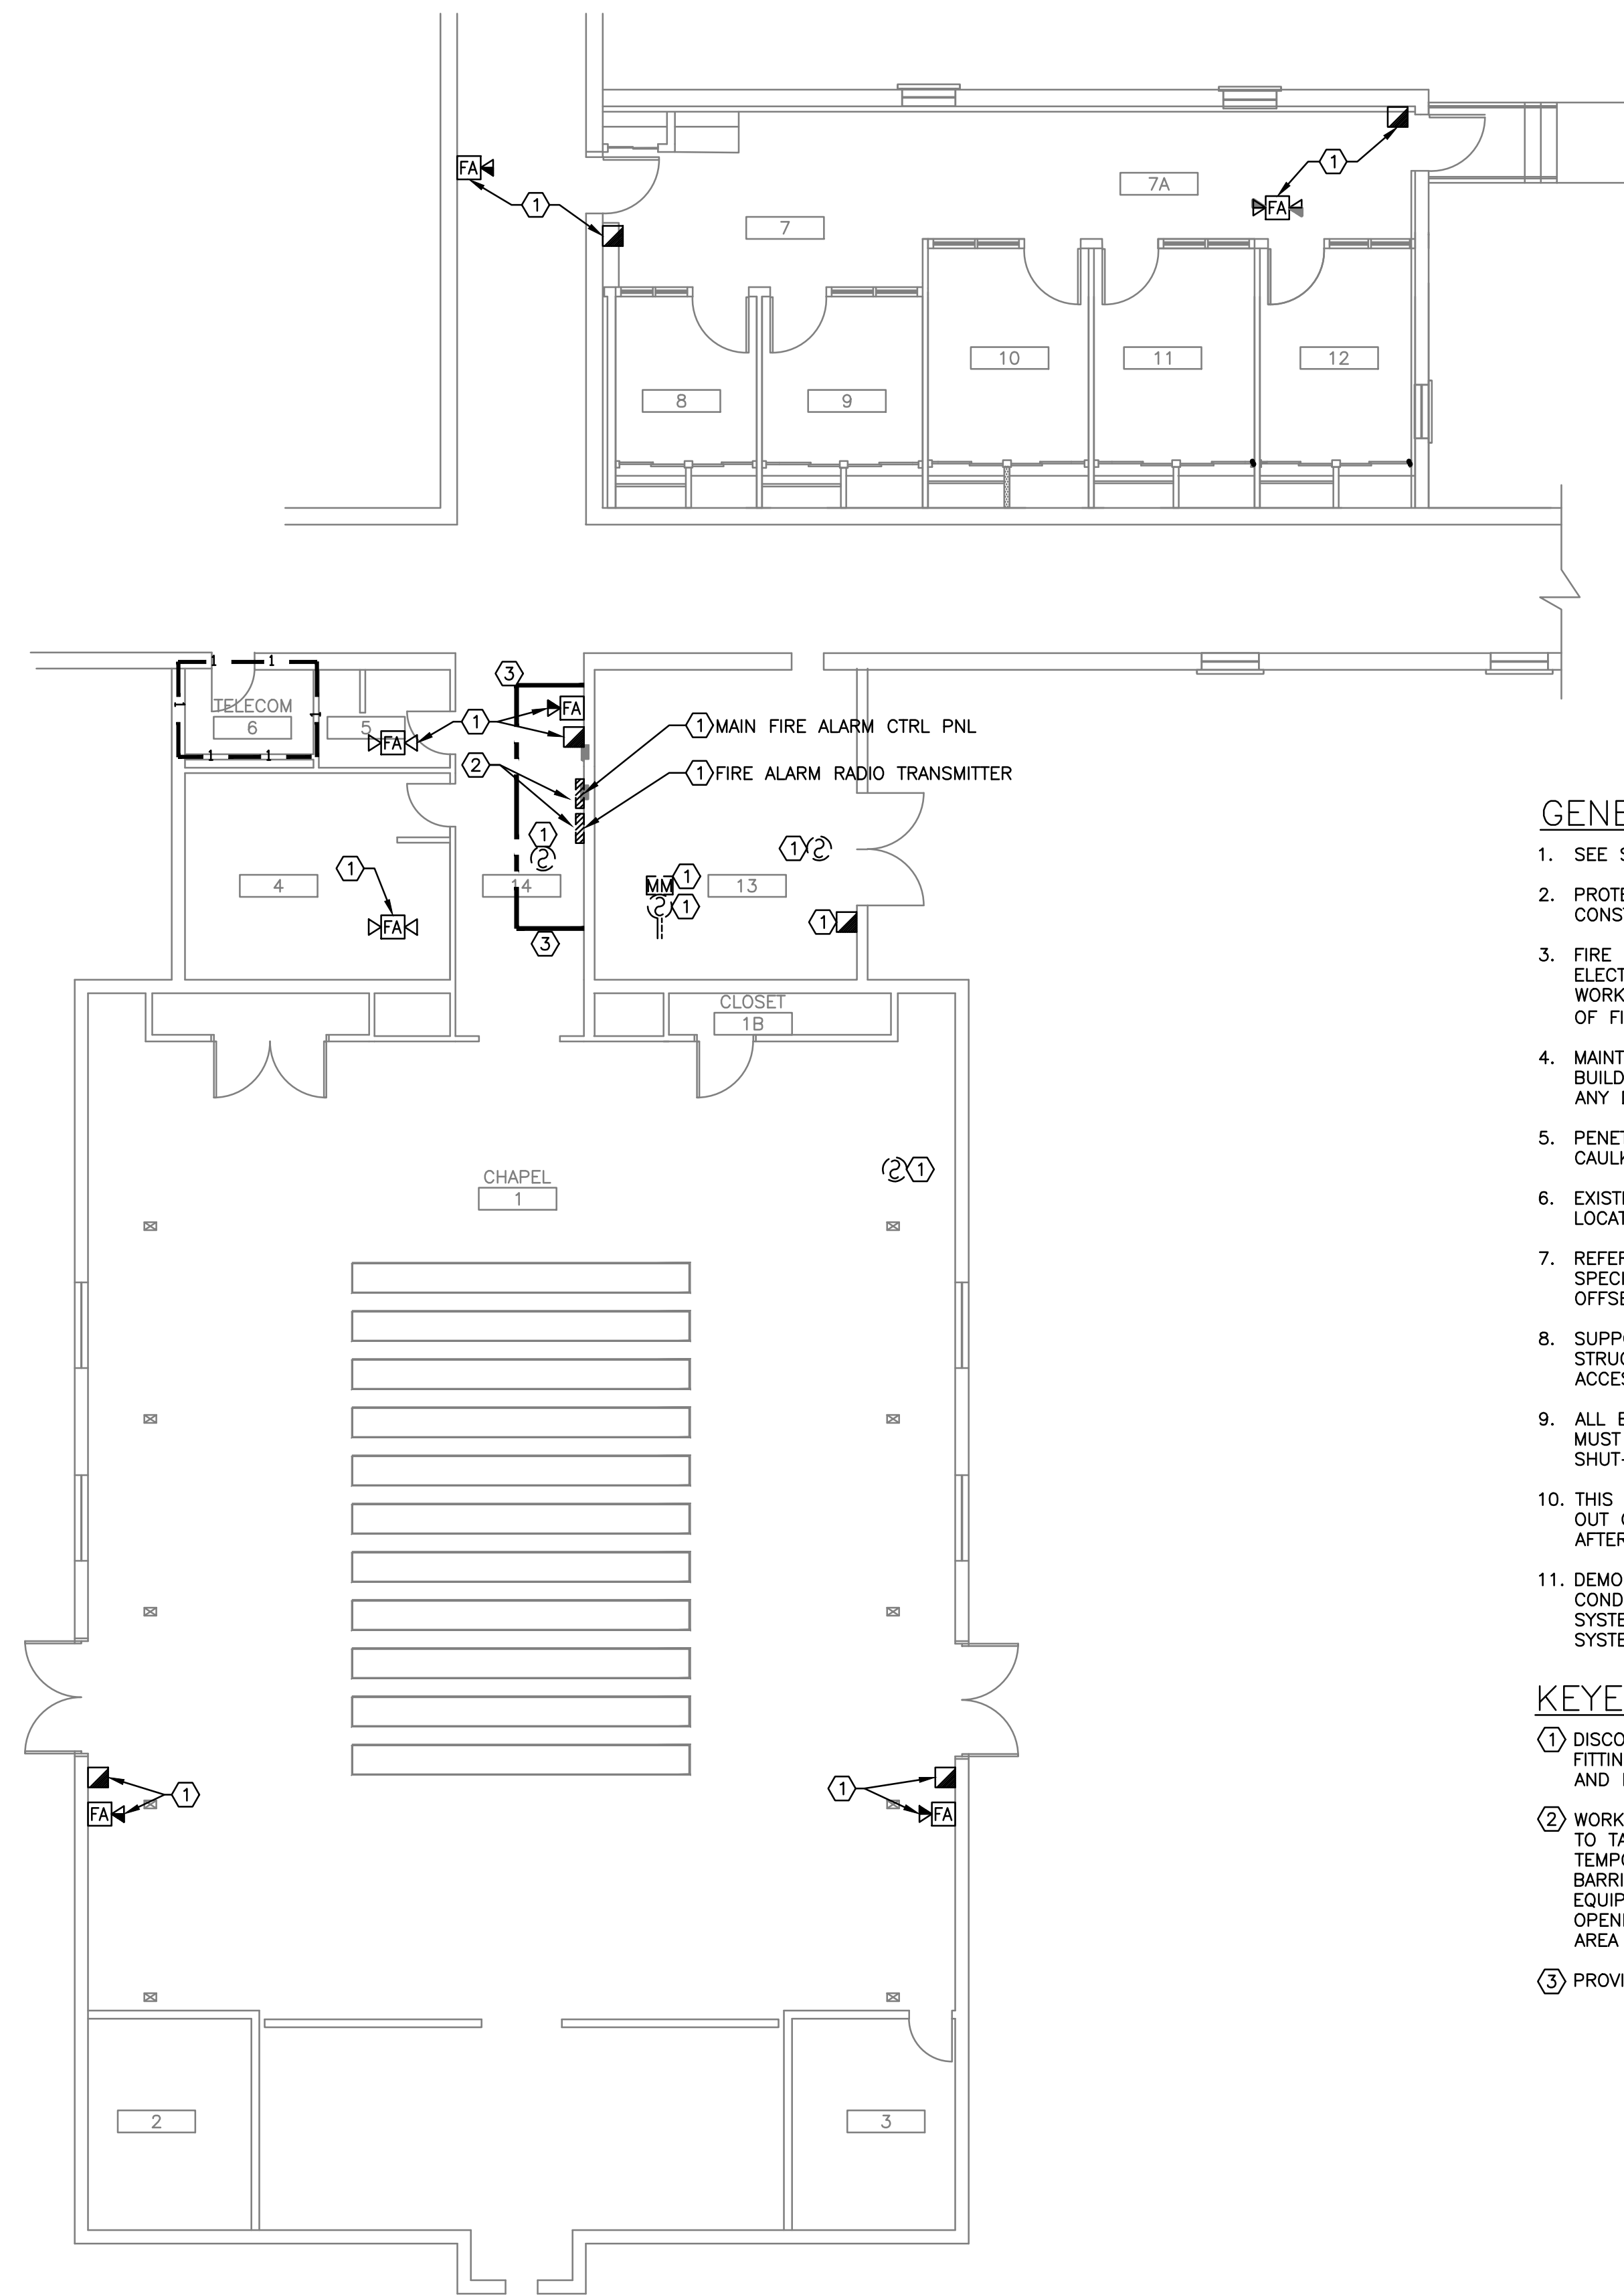

2 B425 - GROUND FLOOR PLAN
1/8" = 1'-0"



- GENERAL NOTES:

1. SEE SHEET F001 FOR LEGENDS, NOTES AND ABBREVIATIONS.
2. PROTECT ALL DEVICES AND EQUIPMENT TO REMAIN DURING CONSTRUCTION.
3. FIRE PROTECTION CONTRACTOR TO REVIEW ARCHITECTURAL AND ELECTRICAL PLANS FOR ADDITIONAL INFORMATION AND REQUIRED WORK NECESSARY TO FACILITATE A COMPLETE SYSTEM AND IS PART OF FIRE PROTECTION CONTRACTOR'S SCOPE OF WORK.
4. MAINTAIN CONTINUOUS UTILITY SERVICE TO ALL SPACES IN THE BUILDING NOT AFFECTED BY THIS WORK. COORDINATE WITH VA COR ANY DISRUPTION IN SERVICES REQUIRED TO PERFORM WORK.
5. PENETRATIONS THROUGH EXISTING WALLS AND FLOORS REQUIRE FIRE CAULKING BY THIS CONTRACTOR.
6. EXISTING SYSTEM LAYOUT IS BASED ON FIELD SURVEY. EXACT LOCATIONS AND ELEVATIONS MAY VARY.
7. REFER TO ALL OTHER PLANS, DIAGRAMS, DETAILS AND SPECIFICATIONS TO PROVIDE A FULLY FUNCTIONAL SYSTEM. PROVIDE OFFSETS NOT SHOWN ON DIAGRAMS TO AVOID OBSTRUCTIONS.
8. SUPPORT EQUIPMENT, PANELS, DEVICES, CABLES AND WIRING FROM STRUCTURE, WALLS OR FLOORS SO THAT ALL ITEMS ARE ACCESSIBLE FOR MAINTENANCE.
9. ALL BUILDINGS WILL BE CONTINUOUSLY OCCUPIED. ALL SYSTEMS MUST BE AVAILABLE BY 7:00 AM AFTER A NIGHT OR ANY SHUT-DOWN.
10. THIS CONTRACTOR IS RESPONSIBLE TO MOVE EXISTING FURNITURE OUT OF THE WAY OF THE REQUIRED WORK AND MOVE IT BACK AFTER THE WORK IS COMPLETED.
11. DEMOLITION AND REMOVAL OF EXISTING FIRE ALARM DEVICES, CONDUIT, AND ALL OTHER COMPONENTS OF EXISTING FIRE ALARM SYSTEM TO TAKE PLACE AFTER INSTALLATION OF NEW FIRE ALARM SYSTEM IS COMPLETE. SEE DETAILS ON SHEET F501.

- KEYED NOTES:

- ① DISCONNECT AND REMOVE EXISTING FA DEVICE. REMOVE WIRING, FITTINGS, SUPPORTS, SYSTEM JUNCTION BOXES, RADIO TRANSMITTERS AND RECEIVERS. WIRING TO BE REMOVED TO THE SOURCE.
- ② WORK TO INSTALL NEW FIRE ALARM PANELS AND REMOVE EXISTING TO TAKE PLACE DURING NORMAL WORKING HOURS. SET UP TEMPORARY ICB-1 BARRIER AT START OF WORK. REMOVE ICB-1 BARRIER TO COMPLETE WORK. CLEAN AND TEST ALL TOOLS AND EQUIPMENT DAILY. PROTECT WORK IN PROGRESS SO THAT ANY OPENINGS IN WALLS OR CEILINGS ARE COVERED, SWEEP UP DUST IN AREA AND DAMP MOP FLOOR FOR DAILY CLEAN-UP.
- ③ PROVIDE ICB, SEE DETAIL 2 ON GC101 FOR REQUIREMENTS.

NOTE: ACCESS PANELS MUST BE INSTALLED BEFORE ANY DEMOLITION WORK CAN BEGIN. SEE DRAWING FA146 FOR ACCESS PANEL LOCATIONS.

[illegible]

CONSULTANTS:

PROJECT LEADER:



Drawing Title	FIRE ALARM B52 AND B425 GROUND FLOOR PLANS - DEMOLITION
---------------	---

Approved: Project Director

Project Title	UPGRADE FIRE ALARM SYSTEM DESIGN
---------------	-------------------------------------

Location	Tomah, Wisconsin
----------	------------------

Date
APRIL 21, 2026

Checked By:	HFB
-------------	-----

Drawn By:
JMD

FINAL BID DOCUMENTS


Project Number	676-22-110
Building Number	B52/B425

	Drawing Number
	FD146

Office of
Facilities
Management




A
three inches = one foot
one and one half inches = one foot
2
one inch = one foot
three quarters inch = one foot
2
one half inch = one foot
4
three eighths inch = one foot
6
one quarter inch = one foot
8
one eighth inch = one foot

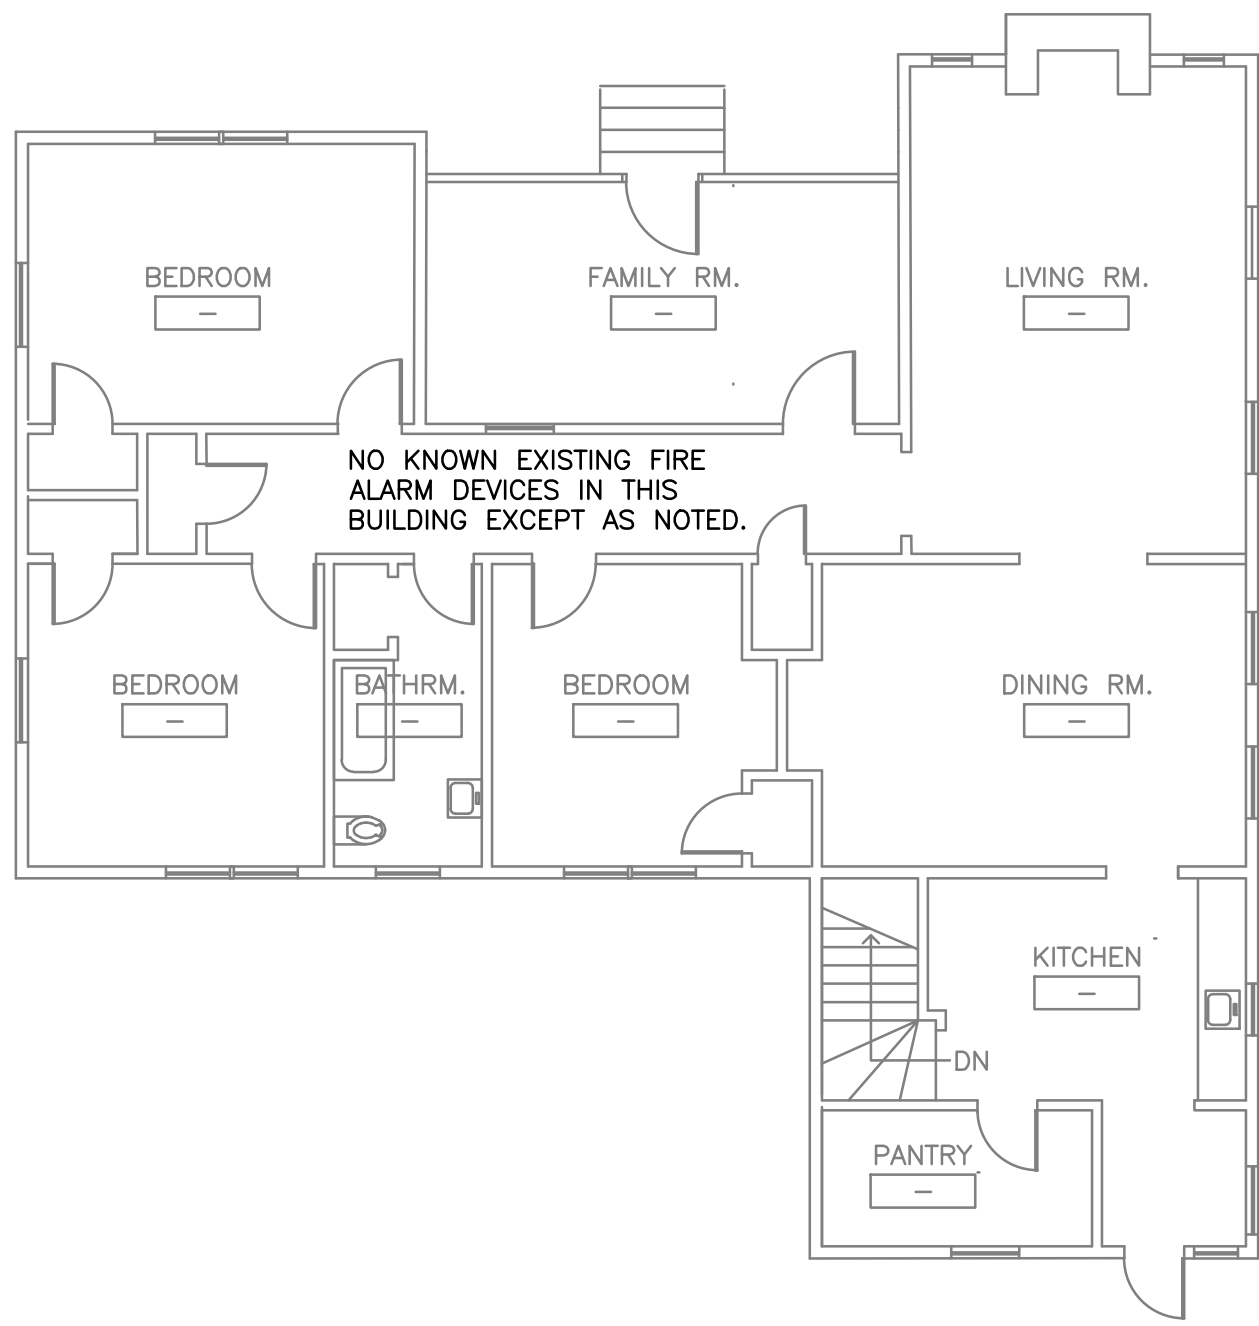


NO KNOWN EXISTING FIRE ALARM DEVICES IN THIS BUILDING EXCEPT AS NOTED.

1 B1 - GROUND FLOOR PLAN
1/8" = 1'-0"

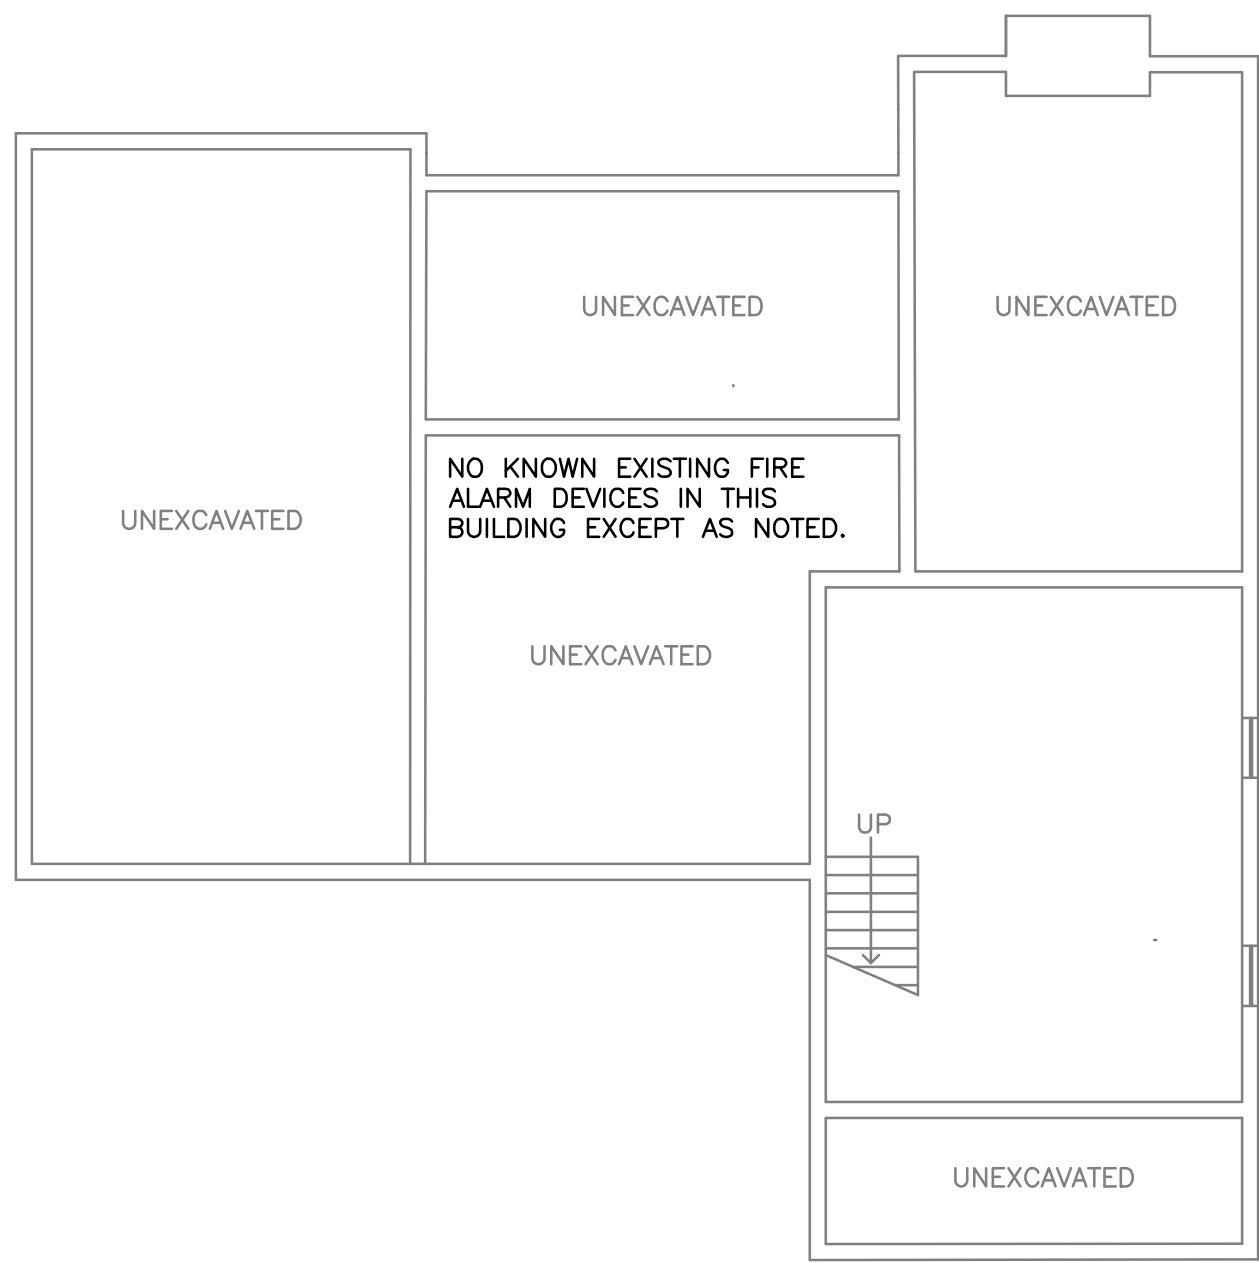


2 B1 - BASEMENT FLOOR PLAN
1/8" = 1'-0"

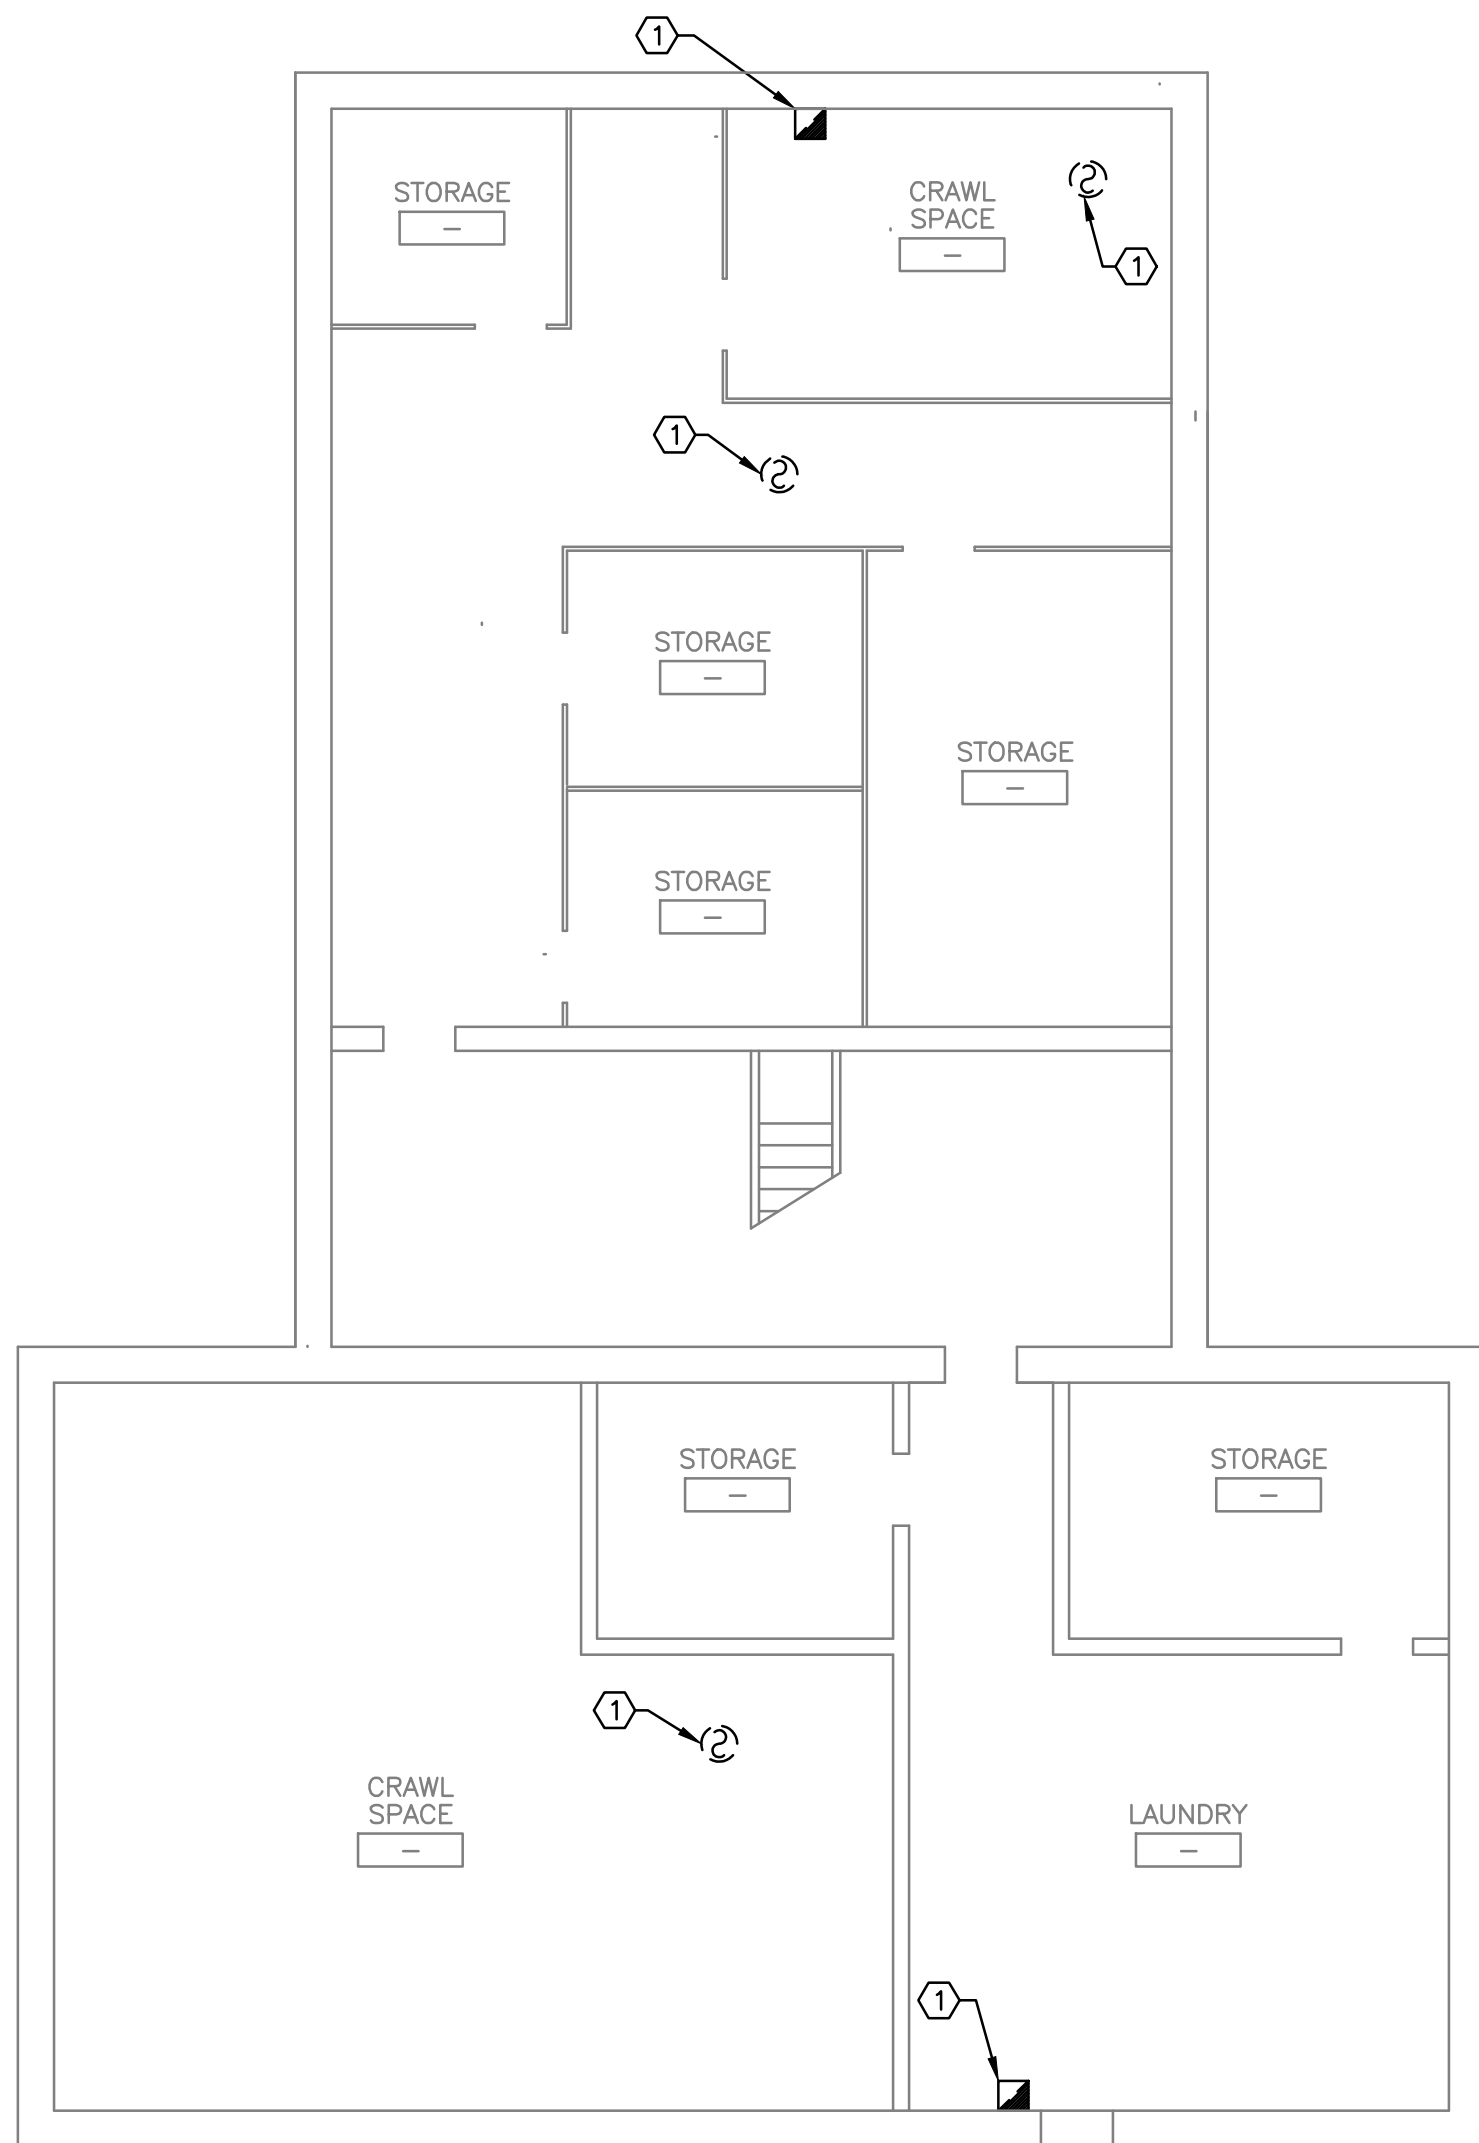


2 NOTE: BUILDING 3 IS FED FROM BUILDING 10 FACP. WORK IN BUILDING 3 MUST HAPPEN WITH WORK IN BUILDING 10.

3 B3 - BASEMENT FLOOR PLAN
1/8" = 1'-0"

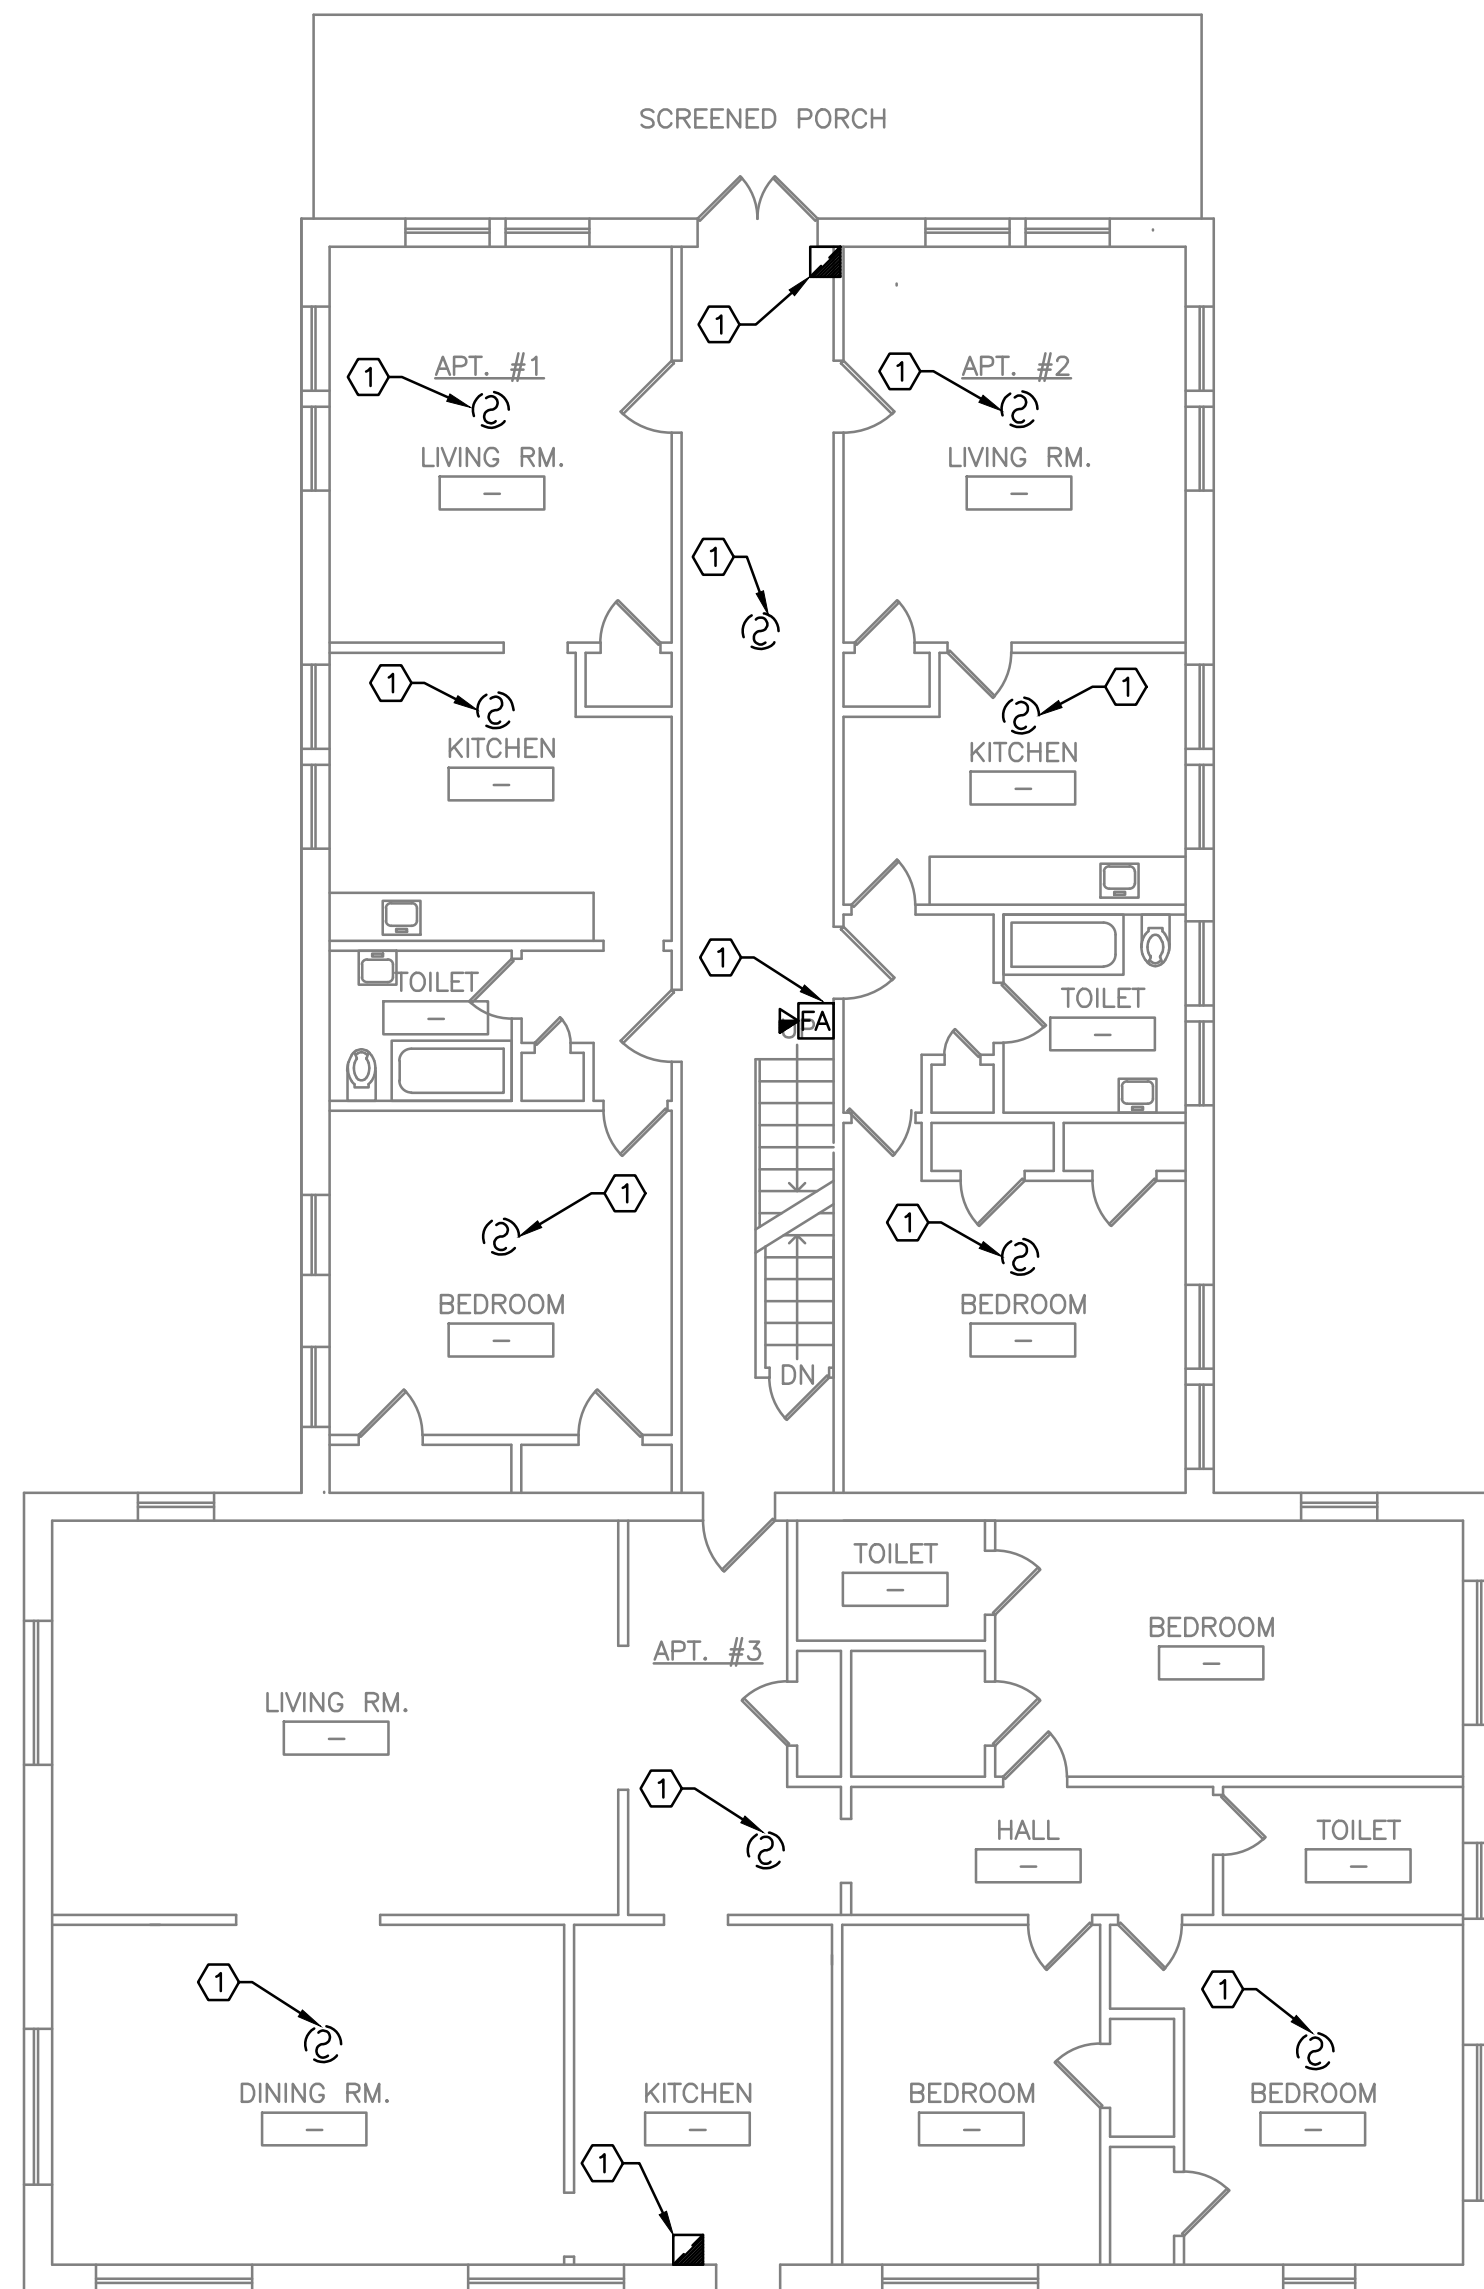

2 NOTE: BUILDING 3 IS FED FROM BUILDING 10 FACP. WORK IN BUILDING 3 MUST HAPPEN WITH WORK IN BUILDING 10.

4 B3 - FIRST FLOOR PLAN
1/8" = 1'-0"

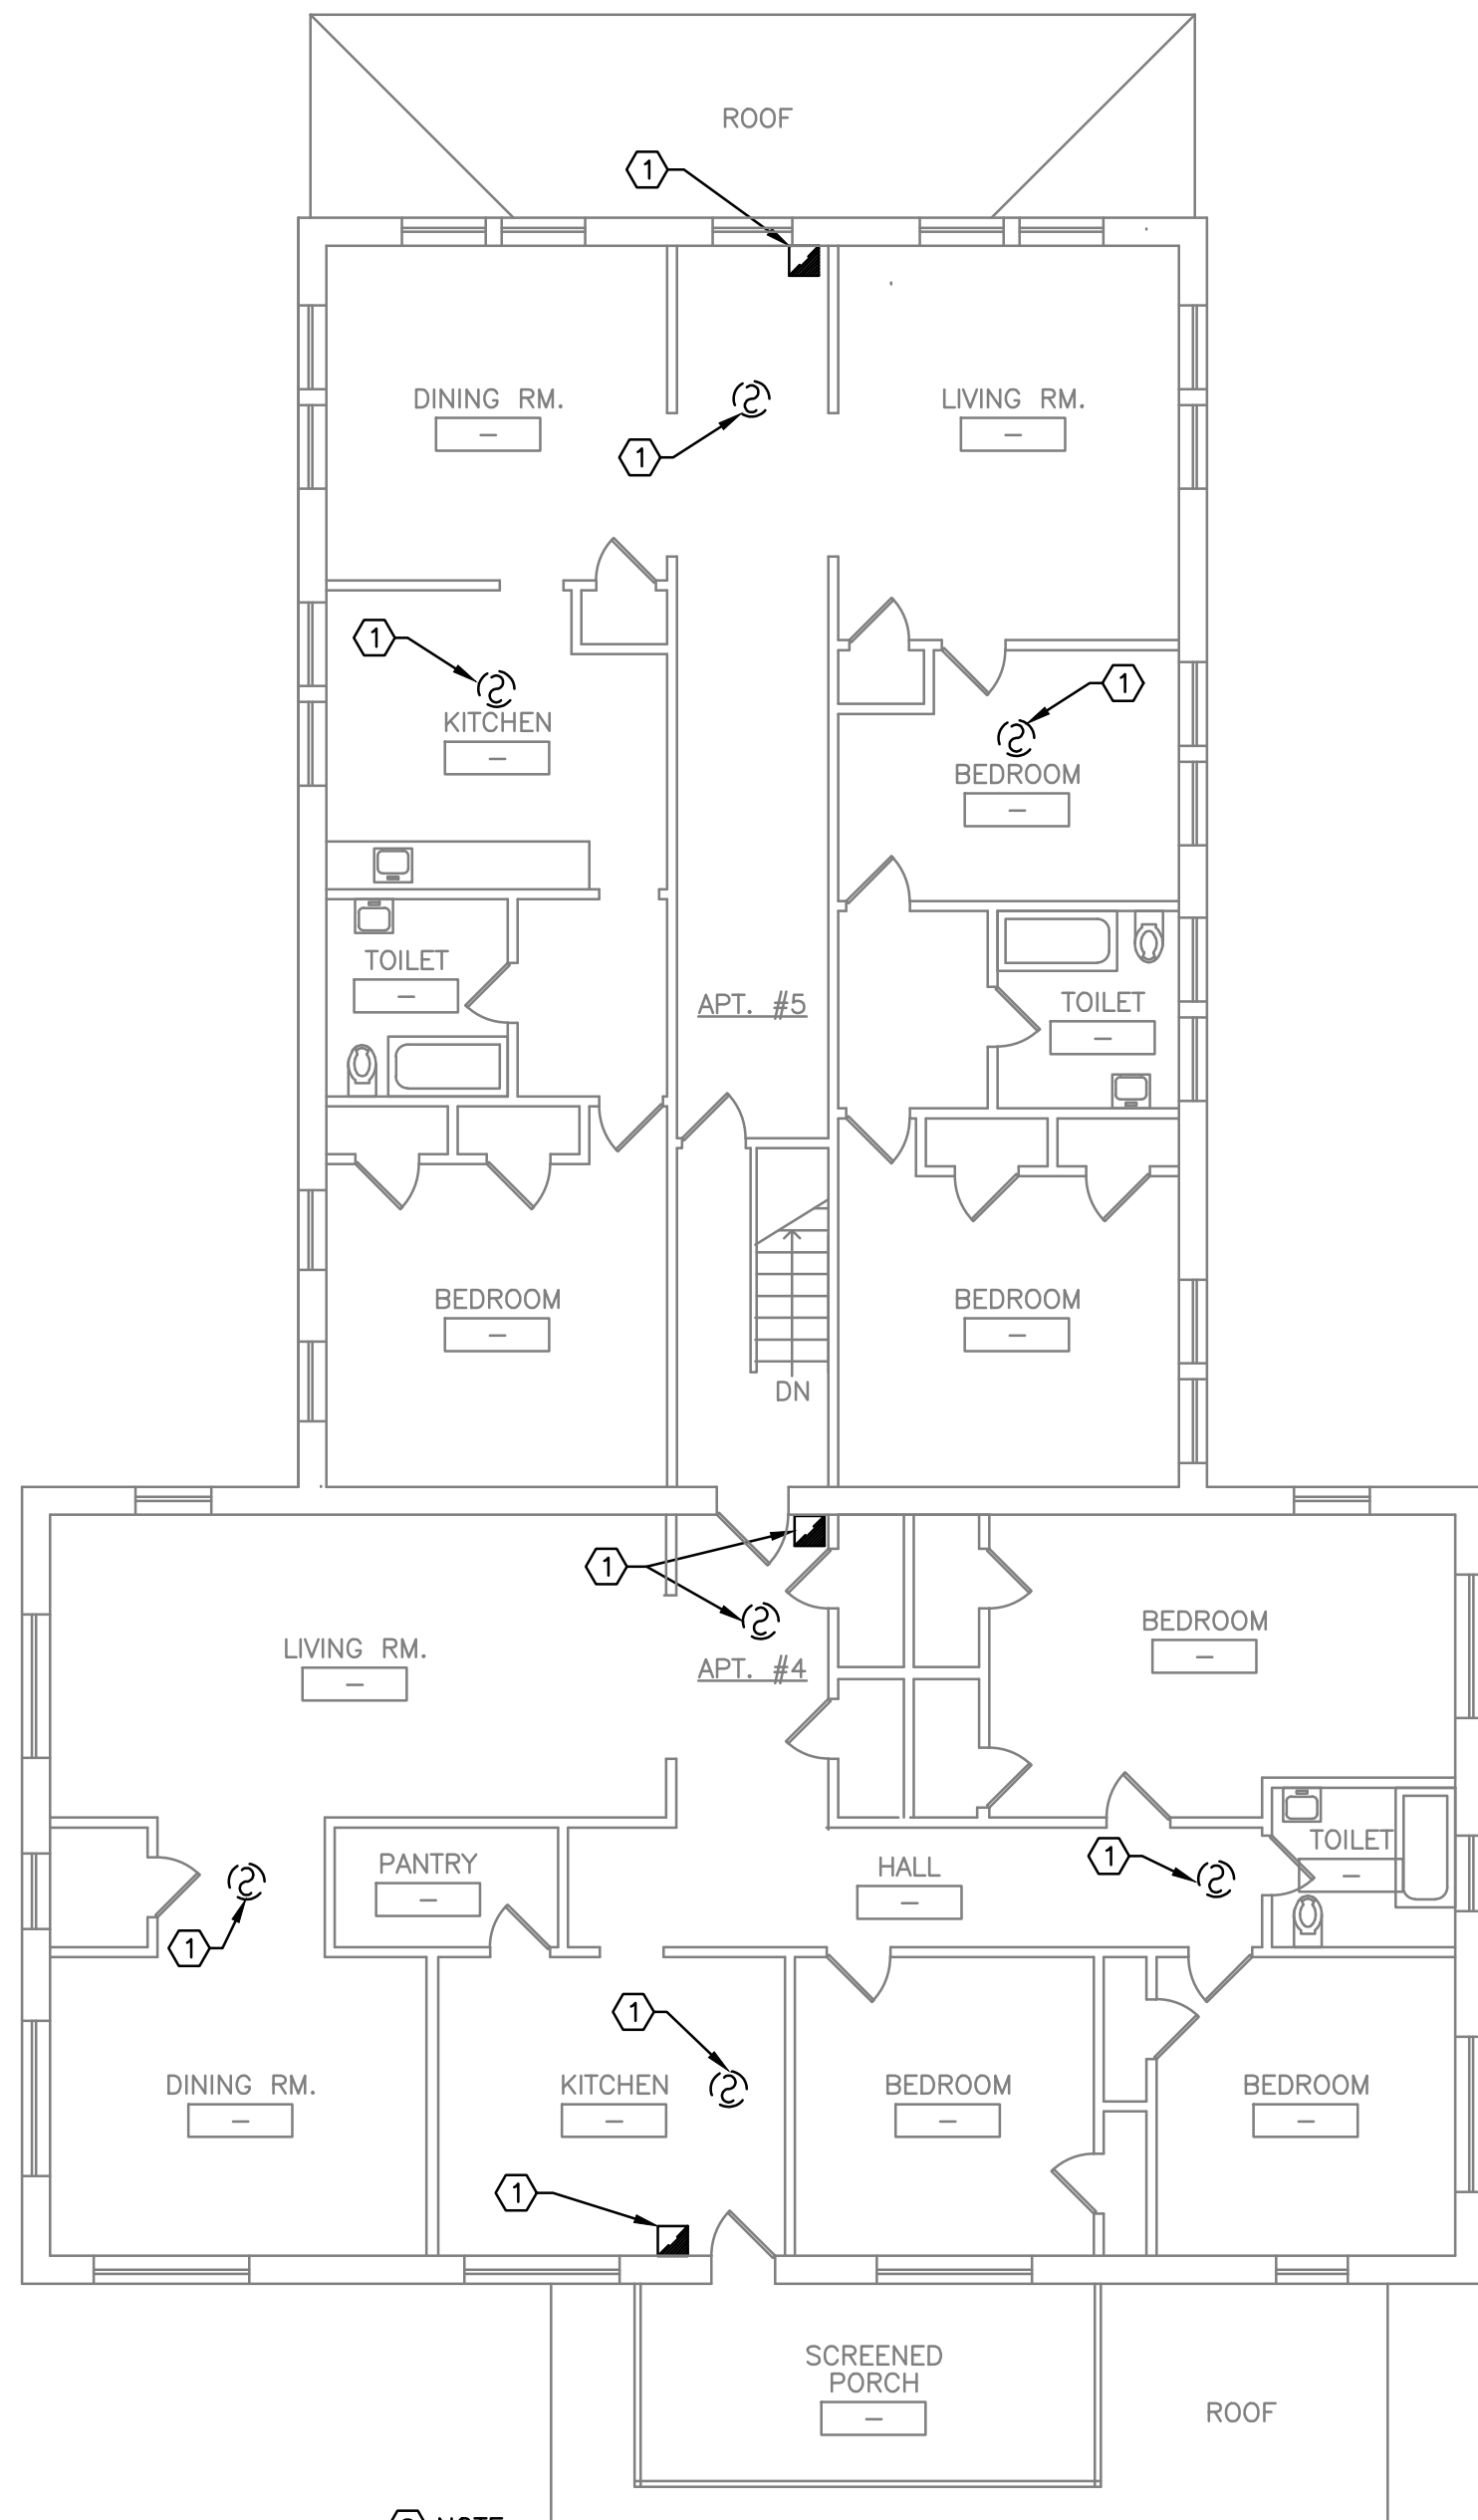

2 NOTE: BUILDING 3 IS FED FROM BUILDING 10 FACP. WORK IN BUILDING 3 MUST HAPPEN WITH WORK IN BUILDING 10.

4 B3 - SECOND FLOOR PLAN
1/8" = 1'-0"



KEYED NOTES:

1. DISCONNECT AND REMOVE EXISTING FA DEVICE. REMOVE WIRING, FITTINGS, SUPPORTS, SYSTEM JUNCTION BOXES, RADIO TRANSMITTERS AND RECEIVERS. WIRING TO BE REMOVED TO THE SOURCE.
2. WORK TO INSTALL NEW FIRE ALARM PANEL AND REMOVE EXISTING FIRE ALARM PANEL TO TAKE PLACE DURING NORMAL WORKING HOURS. SET UP THE ICB-1 BARRIER AT THE START OF WORK. REMOVE ICB-1 BARRIER AT END OF WORK. REMOVE ALL TOOLS AND EQUIPMENT DAILY. PROTECT WORK IN PROGRESS SO THAT ANY OPENINGS IN WALLS OR CEILINGS ARE COVERED. SWEEP UP DUST IN AREA AND DAMP MOP FLOOR FOR DAILY CLEAN-UP.

GENERAL NOTES:

1. SEE SHEET F001 FOR LEGENDS, NOTES AND ABBREVIATIONS.
2. PROTECT ALL DEVICES AND EQUIPMENT TO REMAIN DURING CONSTRUCTION.
3. FIRE PROTECTION CONTRACTOR TO REVIEW ARCHITECTURAL AND ELECTRICAL PLANS FOR ADDITIONAL INFORMATION AND REQUIRED WORK NECESSARY TO FACILITATE A COMPLETE SYSTEM AND IS PART OF FIRE PROTECTION CONTRACTOR'S SCOPE OF WORK.
4. MAINTAIN CONTINUOUS UTILITY SERVICE TO ALL SPACES IN THE BUILDING NOT AFFECTED BY THIS WORK. COORDINATE WITH VA COR ANY DISRUPTION IN SERVICES REQUIRED TO PERFORM WORK.
5. PENETRATIONS THROUGH EXISTING WALLS AND FLOORS REQUIRE FIRE CAULKING BY THIS CONTRACTOR.
6. EXISTING SYSTEM LAYOUT IS BASED ON FIELD SURVEY. EXACT LOCATIONS AND ELEVATIONS MAY VARY.
7. REFER TO ALL OTHER PLANS, DIAGRAMS, DETAILS AND SPECIFICATIONS TO PROVIDE A FULLY FUNCTIONAL SYSTEM. PROVIDE OFFSETS NOT SHOWN ON DIAGRAMS TO AVOID OBSTRUCTIONS.
8. SUPPORT EQUIPMENT, PANELS, DEVICES, CABLES AND WIRING FROM STRUCTURE, WALLS AND FLOOR SO THAT ALL ITEMS ARE ACCESSIBLE FOR MAINTENANCE.
9. ALL BUILDINGS WILL BE CONTINUOUSLY OCCUPIED. ALL SYSTEMS MUST BE AVAILABLE BY 7:00 AM AFTER A NIGHT OR ANY SHUT-DOWN.
10. THIS CONTRACTOR IS RESPONSIBLE TO MOVE EXISTING FURNITURE OUT OF THE WAY OF THE REQUIRED WORK AND MOVE IT BACK AFTER THE WORK IS COMPLETED.
11. DEMOLITION AND REMOVAL OF EXISTING FIRE ALARM DEVICES, CONDUIT, AND ALL OTHER COMPONENTS OF EXISTING FIRE ALARM SYSTEM TO TAKE PLACE AFTER INSTALLATION OF NEW FIRE ALARM SYSTEM IS COMPLETE. SEE DETAILS ON SHEET F501.

Revisions:	Date



VETERANS AFFAIRS
MEDICAL CENTER
500 E VETERANS ST
TOMAH, WI 54660



CONSULTANTS:

PROJECT LEADER:



Drawing Title
FIRE ALARM - B1/B3 BASEMENT,
GROUND, AND SECOND FLOOR
PLANS - DEMOLITION

Approved: Project Director

Project Title
UPGRADE FIRE ALARM
SYSTEM DESIGN

Location
Tomah, Wisconsin

Date
APRIL 21, 2026

Checked By:
HFB

Drawn By:
JMD

FINAL BID DOCUMENTS

Project Number
676-22-110
Building Number
B1/B3

Drawing Number
FD147

Office of
Facilities
Management





- ① DISCONNECT AND REMOVE EXISTING FA DEVICE. REMOVE WIRING, FITTINGS, SUPPORTS, SYSTEM JUNCTION BOXES, RADIO TRANSMITTERS AND RECEIVERS. WIRING TO BE REMOVED TO THE SOURCE.
- ② WORK TO INSTALL NEW FIRE ALARM PANEL AND REMOVE EXISTING FIRE ALARM PANEL TO TAKE PLACE OF NORMAL WORKING HOURS. SET UP THE ICB-1 BARRIER AT THE START OF WORK. REMOVE ICB-1 BARRIER AT END OF WORK. REMOVE ALL TOOLS AND EQUIPMENT DAILY. MAKE SURE ALL OPENINGS SO THAT ANY OPENINGS IN WALLS OR CEILINGS ARE COVERED. SWEEP UP DUST IN AREA AND DAMP MOP FLOOR FOR DAILY CLEAN-UP.
- ③ PROVIDE ICB, SEE DETAIL 2 ON DRAWING GC101 FOR REQUIREMENTS.

1. SEE SHEET F001 FOR LEGENDS, NOTES AND ABBREVIATIONS.
2. PROTECT ALL DEVICES AND EQUIPMENT TO REMAIN DURING CONSTRUCTION.
3. FIRE PROTECTION CONTRACTOR TO REVIEW ARCHITECTURAL AND ELECTRICAL PLANS FOR ADDITIONAL INFORMATION AND REQUIRED WORK NECESSARY TO FACILITATE A COMPLETE SYSTEM AND IS PART OF FIRE PROTECTION CONTRACTOR'S SCOPE OF WORK.
4. MAINTAIN CONTINUOUS UTILITY SERVICE TO ALL SPACES IN THE BUILDING NOT AFFECTED BY THIS WORK; COORDINATE WITH VA COR ANY DISRUPTION IN SERVICES REQUIRED TO PERFORM WORK.
5. PENETRATIONS THROUGH EXISTING WALLS AND FLOORS REQUIRE FIRE CAULKING BY THIS CONTRACTOR.
6. EXISTING SYSTEM LAYOUT IS BASED ON FIELD SURVEY. EXACT LOCATIONS AND ELEVATIONS MAY VARY.
7. REFER TO ALL OTHER PLANS, DIAGRAMS, DETAILS AND SPECIFICATIONS TO PROVIDE A FULLY FUNCTIONAL SYSTEM. PROVIDE OFFSETS NOT SHOWN ON DIAGRAMS TO AVOID OBSTRUCTIONS.
8. SUPPORT EQUIPMENT, PANELS, DEVICES, CABLES AND WIRING FROM STRUCTURE, WALLS AND FLOOR SO THAT ALL ITEMS ARE ACCESSIBLE FOR MAINTENANCE.
9. ALL BUILDINGS WILL BE CONTINUOUSLY OCCUPIED. ALL SYSTEMS MUST BE AVAILABLE BY 7:00 AM AFTER A NIGHT OR ANY SHUT-DOWN.
10. THIS CONTRACTOR IS RESPONSIBLE TO MOVE EXISTING FURNITURE OUT OF THE WAY OF THE REQUIRED WORK AND MOVE IT BACK AFTER THE WORK IS COMPLETED.
11. DEMOLITION AND REMOVAL OF EXISTING FIRE ALARM DEVICES, CONDUIT, AND ALL OTHER COMPONENTS OF EXISTING FIRE ALARM SYSTEM TO TAKE PLACE AFTER INSTALLATION OF NEW FIRE ALARM SYSTEM IS COMPLETE. SEE DETAILS ON SHEET F501.



VETERANS AFFAIRS
MEDICAL CENTER
500 E VETERANS ST
TOMAH, WI 54660



PROJECT LEADER:



Drawing Title	FIRE ALARM - B12 AND B15 BASEMENT, FIRST, & SECOND FLOOR PLANS - DEMOLITION
---------------	---

Approved: Project Director

Project Title	UPGRADE FIRE ALARM SYSTEM DESIGN
---------------	-------------------------------------

Location	Tomah, Wisconsin
----------	------------------

Checked By: HFB	Drawn By: JMD
--------------------	------------------

FINAL BID DOCUMENTS


Project Number	676-22-110
Building Number	B12/B15/B33

	Drawing Number

FD149

Office of
Facilities
Management



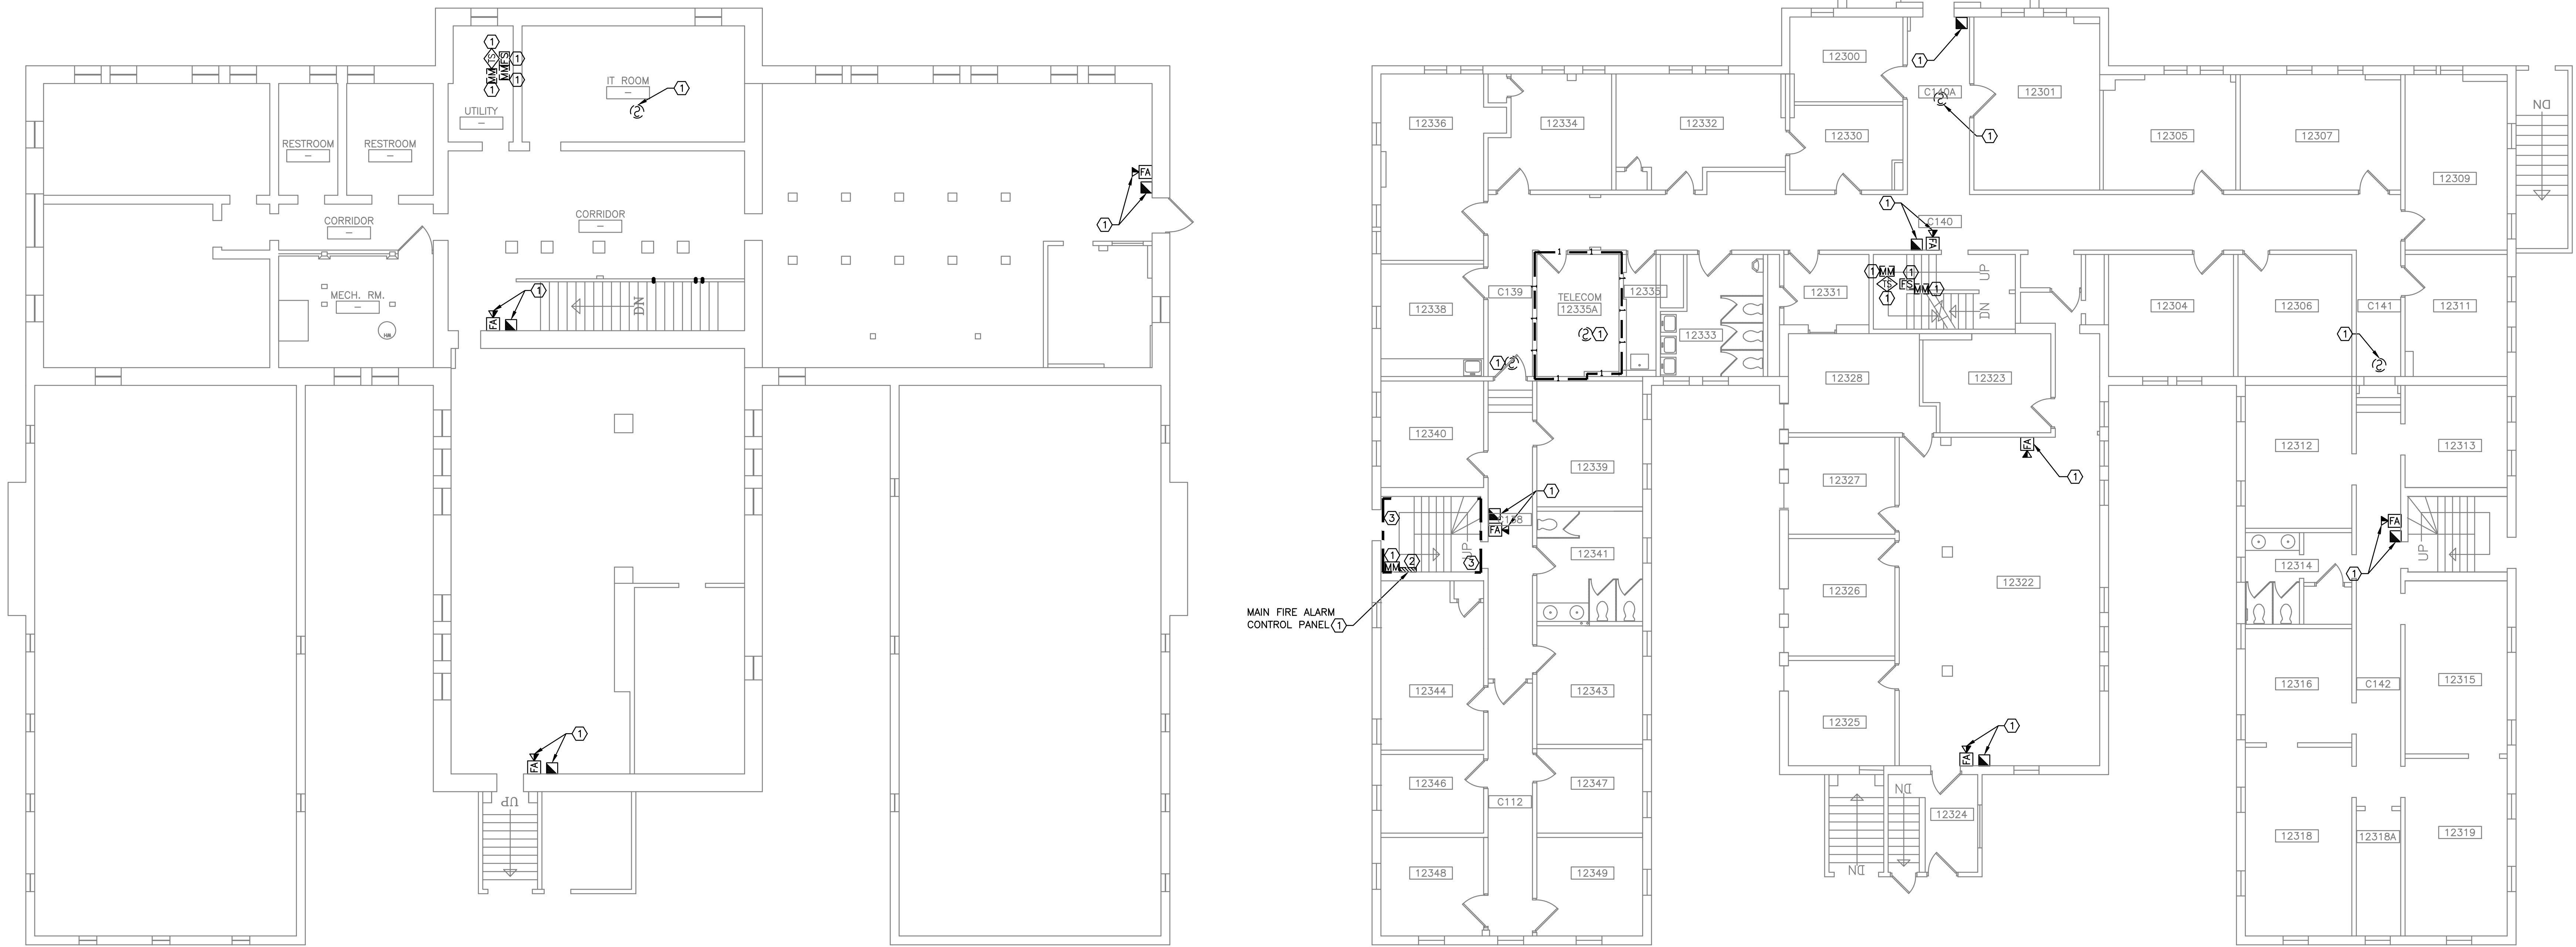

1 B23 - BASEMENT FLOOR PLAN
1/8" = 1'-0"

KEYED NOTES:

- 1 DISCONNECT AND REMOVE EXISTING FA DEVICE. REMOVE WIRING, FITTINGS, SUPPORTS, SYSTEM JUNCTION BOXES, RADIO TRANSMITTERS AND RECEIVERS. WIRING TO BE REMOVED TO THE SOURCE.
- 2 WORK TO INSTALL NEW FIRE ALARM PANEL AND REMOVE EXISTING FIRE ALARM PANEL TO TAKE PLACE DURING NORMAL WORKING HOURS. SET UP THE ICB-1 BARRIER AT THE START OF WORK. REMOVE ICB-1 BARRIER AT END OF WORK. REMOVE ALL TOOLS AND EQUIPMENT DAILY. PROTECT WORK IN PROGRESS SO THAT ANY OPENINGS IN WALLS OR CEILINGS ARE COVERED. SWEEP UP DUST IN AREA AND DAMP MOP FLOOR FOR DAILY CLEAN-UP.
- 3 PROVIDE ICB, SEE DETAIL 2 ON DRAWING GC101 FOR REQUIREMENTS.

GENERAL NOTES:

1. SEE SHEET F001 FOR LEGENDS, NOTES AND ABBREVIATIONS.
2. PROTECT ALL DEVICES AND EQUIPMENT TO REMAIN DURING CONSTRUCTION.
3. FIRE PROTECTION CONTRACTOR TO REVIEW ARCHITECTURAL AND ELECTRICAL PLANS FOR ADDITIONAL INFORMATION AND REQUIRED WORK NECESSARY TO FACILITATE A COMPLETE SYSTEM AND IS PART OF FIRE PROTECTION CONTRACTOR'S SCOPE OF WORK.
4. MAINTAIN CONTINUOUS UTILITY SERVICE TO ALL SPACES IN THE BUILDING NOT AFFECTED BY THIS WORK. COORDINATE WITH VA COR ANY DISRUPTION IN SERVICES REQUIRED TO PERFORM WORK.
5. PENETRATIONS THROUGH EXISTING WALLS AND FLOORS REQUIRE FIRE CAULKING BY THIS CONTRACTOR.
6. EXISTING SYSTEM LAYOUT IS BASED ON FIELD SURVEY. EXACT LOCATIONS AND ELEVATIONS MAY VARY.
7. REFER TO ALL OTHER PLANS, DIAGRAMS, DETAILS AND SPECIFICATIONS TO PROVIDE A FULLY FUNCTIONAL SYSTEM. PROVIDE OFFSETS NOT SHOWN ON DIAGRAMS TO AVOID OBSTRUCTIONS.
8. SUPPORT EQUIPMENT, PANELS, DEVICES, CABLES AND WIRING FROM STRUCTURE, WALLS AND FLOOR SO THAT ALL ITEMS ARE ACCESSIBLE FOR MAINTENANCE.
9. ALL BUILDINGS WILL BE CONTINUOUSLY OCCUPIED. ALL SYSTEMS MUST BE AVAILABLE BY 7:00 AM AFTER A NIGHT OR ANY SHUT-DOWN.
10. THIS CONTRACTOR IS RESPONSIBLE TO MOVE EXISTING FURNITURE OUT OF THE WAY OF THE REQUIRED WORK AND MOVE IT BACK AFTER THE WORK IS COMPLETED.
11. DEMOLITION AND REMOVAL OF EXISTING FIRE ALARM DEVICES, CONDUIT, AND ALL OTHER COMPONENTS OF EXISTING FIRE ALARM SYSTEM TO TAKE PLACE AFTER INSTALLATION OF NEW FIRE ALARM SYSTEM IS COMPLETE. SEE DETAILS ON SHEET F501.

2 B23 - FIRST FLOOR PLAN
1/8" = 1'-0"

Revisions: Date		VETERANS AFFAIRS MEDICAL CENTER 500 E VETERANS ST TOMAH, WI 54660		CONSULTANTS:	PROJECT LEADER:  DESIGN / BUILD SERVICES 1021 N. Superior Ave., Unit 11 Tomah, Wisconsin 54660	Drawing Title FIRE ALARM - B23 BASEMENT AND FIRST FLOOR PLANS - DEMOLITION Approved: Project Director	Project Title UPGRADE FIRE ALARM SYSTEM DESIGN Location Tomah, Wisconsin Date APRIL 21, 2026 Checked By: HFB Drawn By: JMD	FINAL BID DOCUMENTS Project Number 676-22-110 Building Number B23 Drawing Number FD151 Office of Facilities Management Department of Veterans Affairs
---------------------------------------	--	---	---	-------------------------	---	--	--	---

A

B


C

D


E

F


three inches = one foot
one and one half inches = one foot
one inch = one foot
three quarters inch = one foot
one half inch = one foot
three eighths inch = one foot
one quarter inch = one foot
one eighth inch = one foot

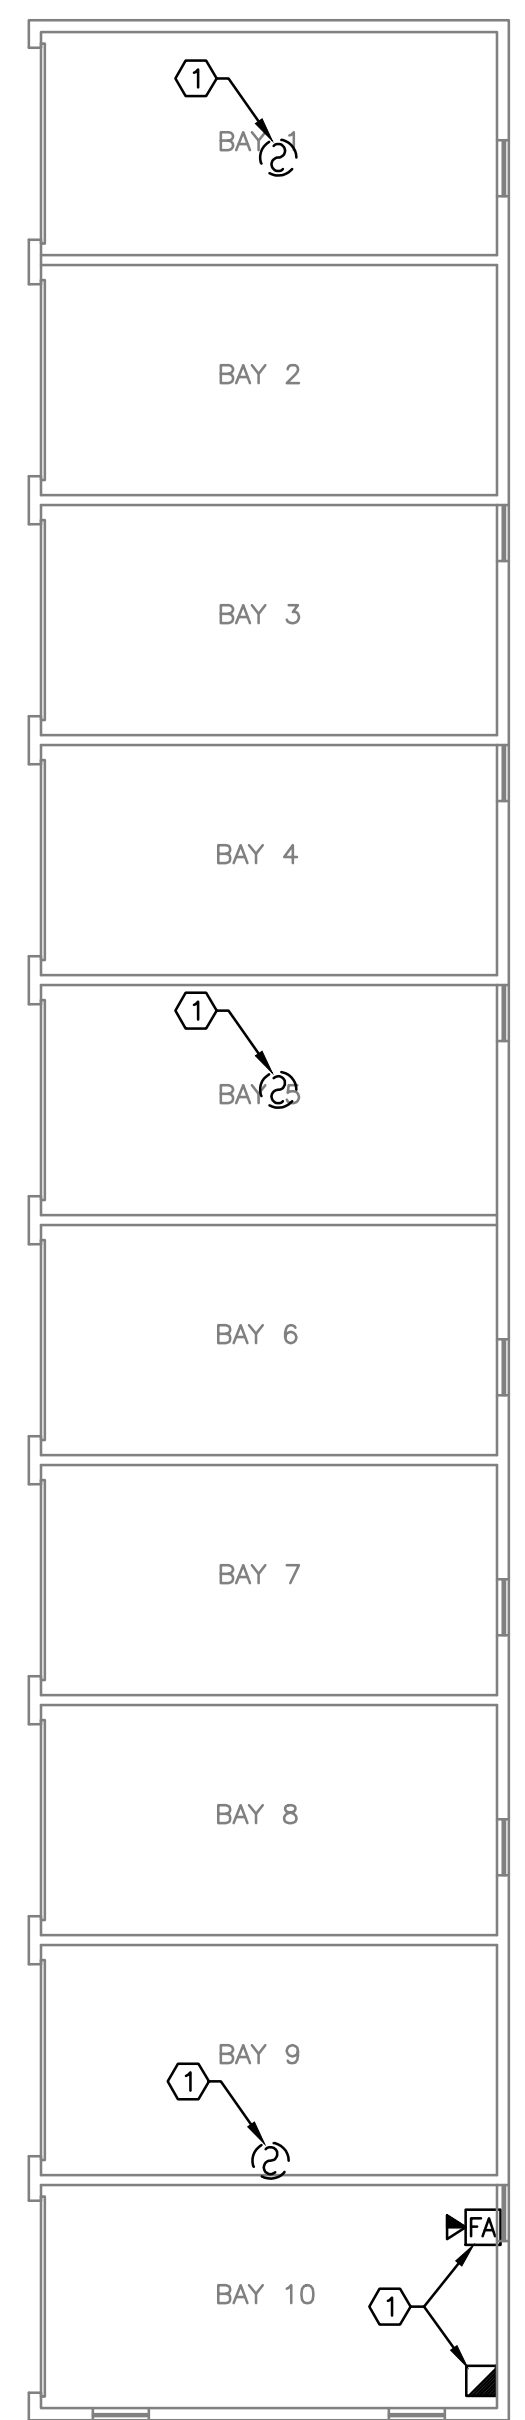


1 B212 - GROUND FLOOR PLAN
1/8" = 1'-0" NORTH

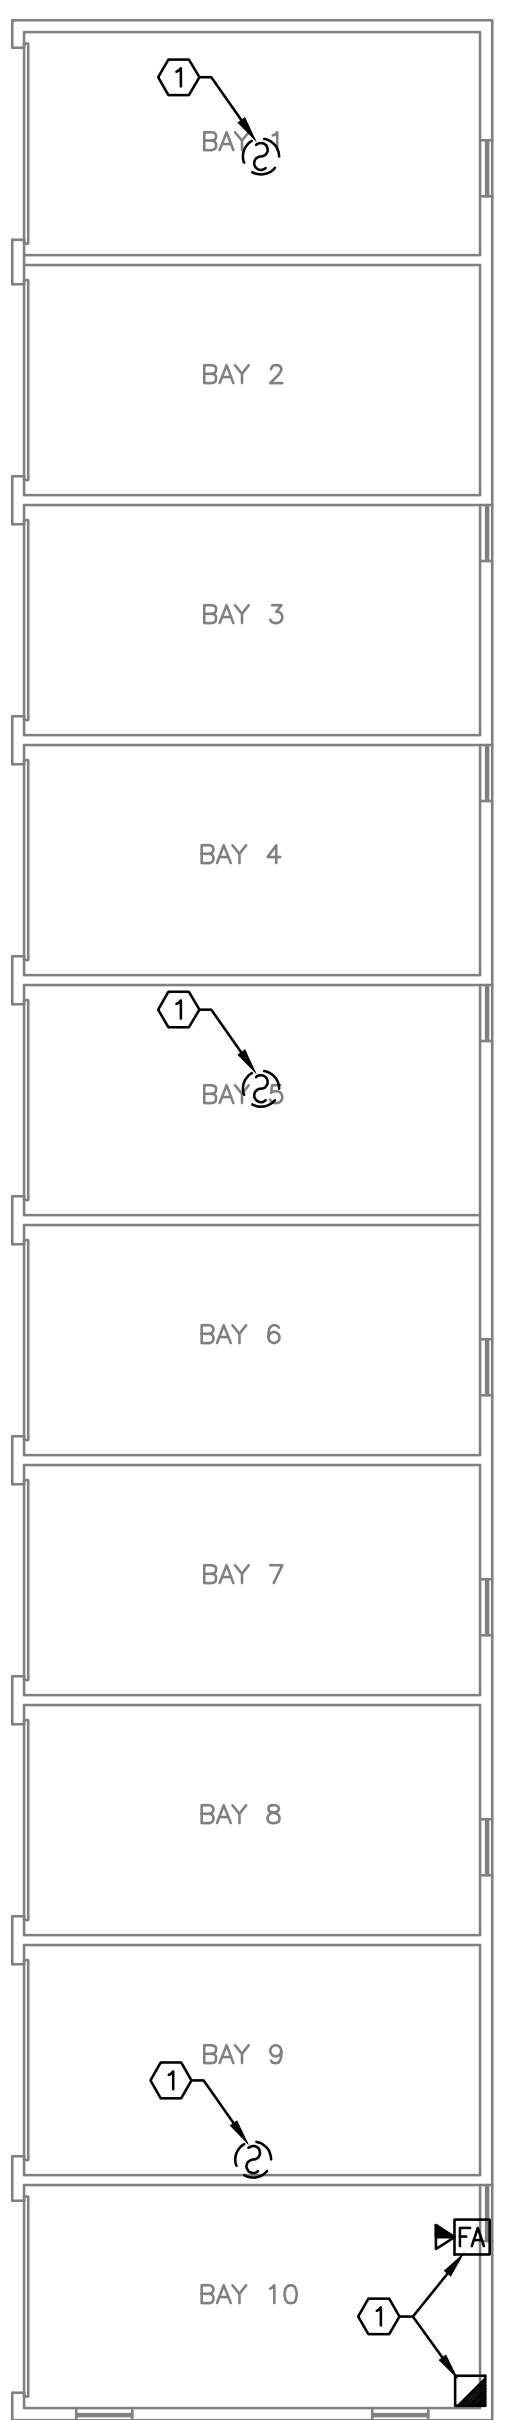


2 B223 - GROUND FLOOR PLAN
1/8" = 1'-0" NORTH

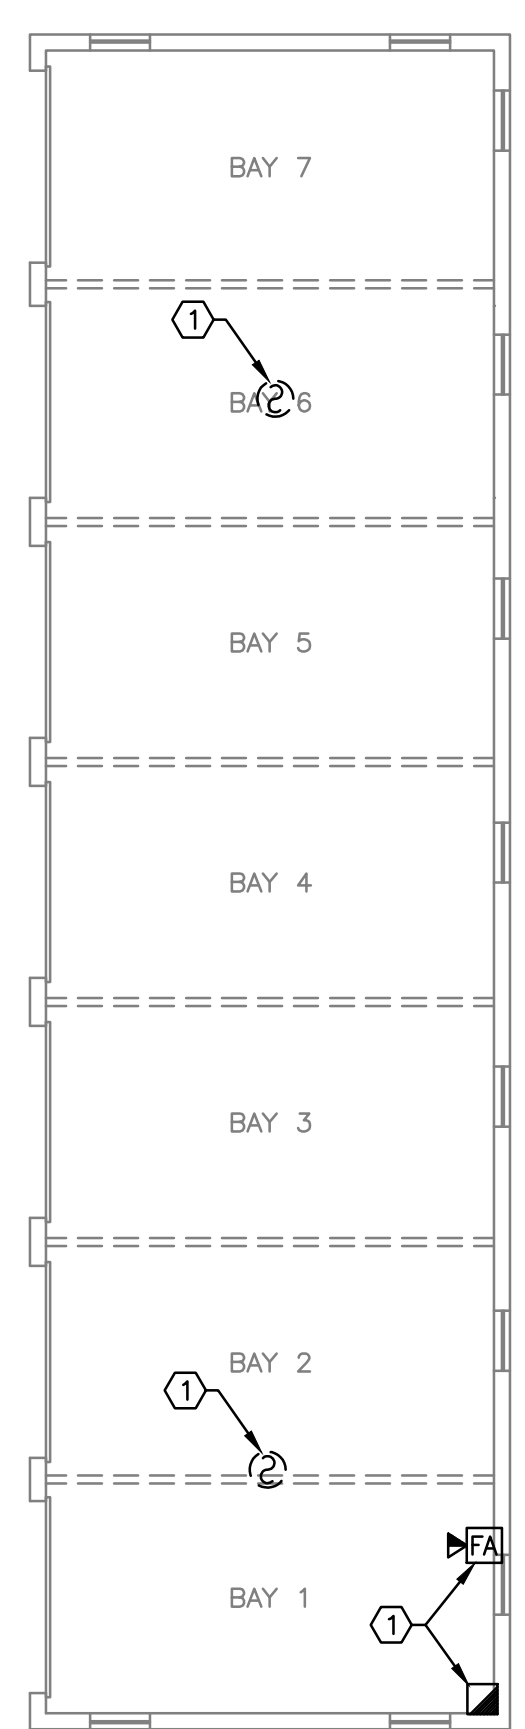

3 B240 - GROUND FLOOR PLAN
1/8" = 1'-0" NORTH

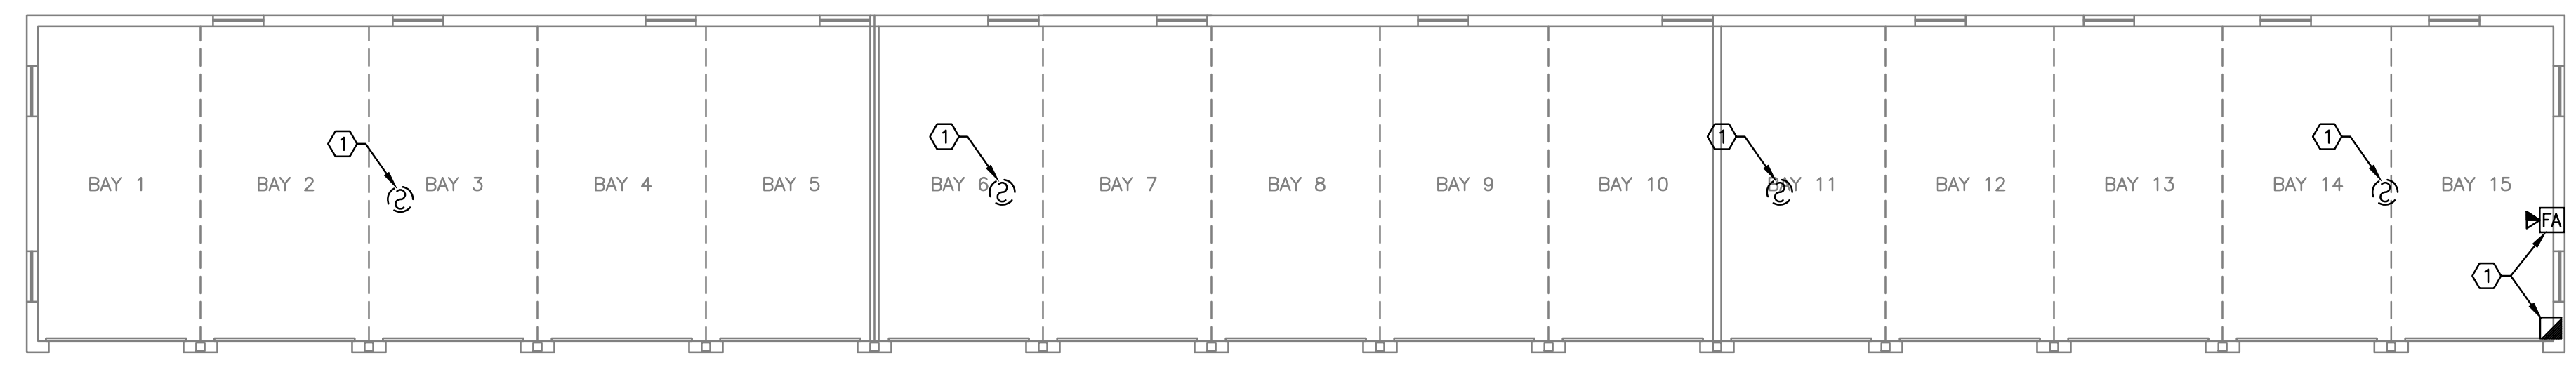

5 B270 - GROUND FLOOR PLAN
1/8" = 1'-0" NORTH

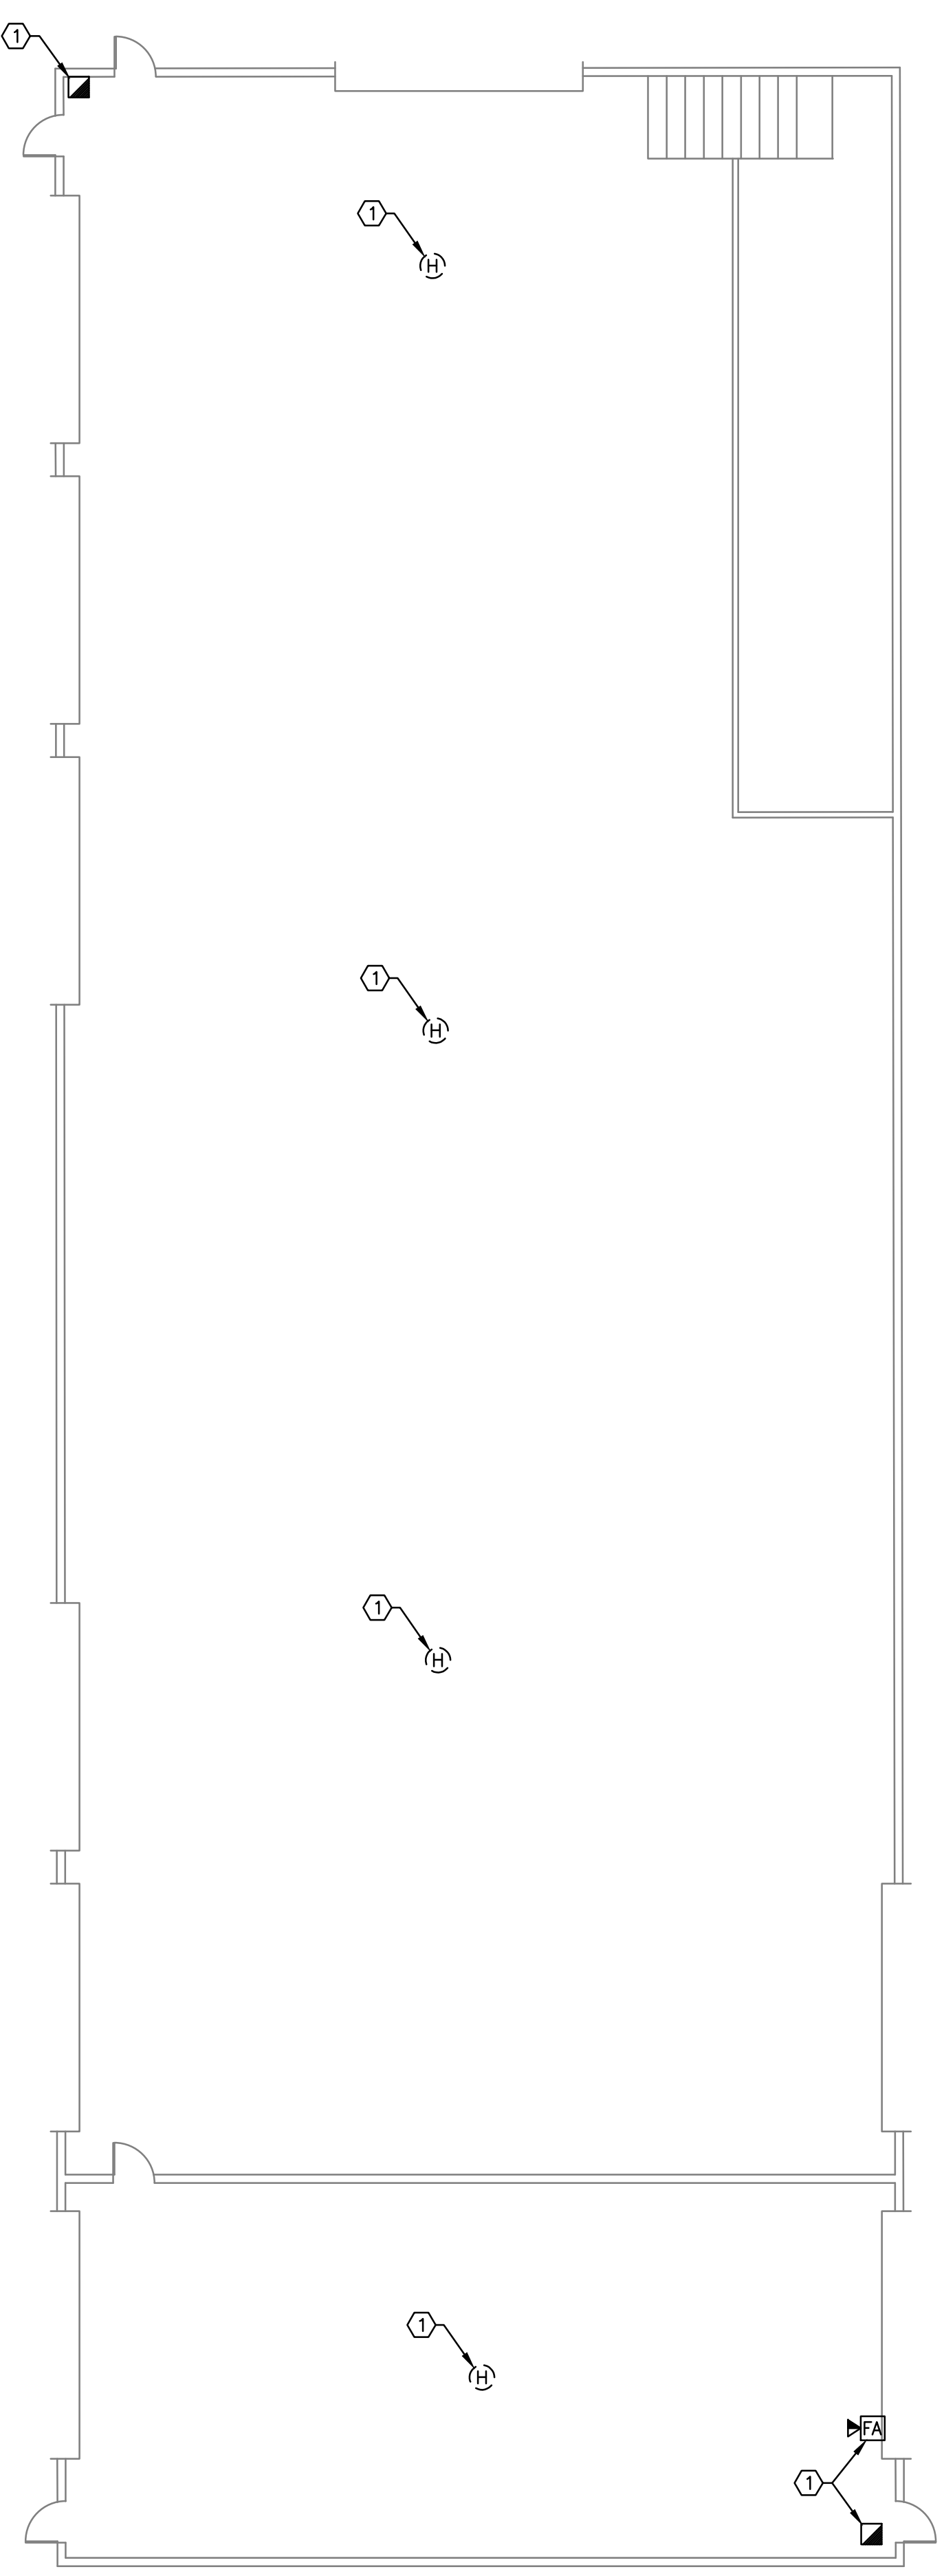

4 B260 - GROUND FLOOR PLAN
1/8" = 1'-0" NORTH


GENERAL NOTES:

- SEE SHEET F001 FOR LEGENDS, NOTES AND ABBREVIATIONS.
- PROTECT ALL DEVICES AND EQUIPMENT TO REMAIN DURING CONSTRUCTION.
- FIRE PROTECTION CONTRACTOR TO REVIEW ARCHITECTURAL AND ELECTRICAL PLANS FOR ADDITIONAL INFORMATION AND REQUIRED WORK NECESSARY TO FACILITATE A COMPLETE SYSTEM AND IS PART OF FIRE PROTECTION CONTRACTOR'S SCOPE OF WORK.
- MAINTAIN CONTINUOUS UTILITY SERVICE TO ALL SPACES IN THE BUILDING NOT AFFECTED BY THIS WORK. COORDINATE WITH VA COR ANY DISRUPTION IN SERVICES REQUIRED TO PERFORM WORK.
- PENETRATIONS THROUGH EXISTING WALLS AND FLOORS REQUIRE FIRE CAULKING BY THIS CONTRACTOR.
- EXISTING SYSTEM LAYOUT IS BASED ON FIELD SURVEY. EXACT LOCATIONS AND ELEVATIONS MAY VARY.
- REFER TO ALL OTHER PLANS, DIAGRAMS, DETAILS AND SPECIFICATIONS TO PROVIDE A FULLY FUNCTIONAL SYSTEM. PROVIDE OFFSETS NOT SHOWN ON DIAGRAMS TO AVOID OBSTRUCTIONS.
- SUPPORT EQUIPMENT, PANELS, DEVICES, CABLES AND WIRING FROM STRUCTURE, WALLS AND FLOOR SO THAT ALL ITEMS ARE ACCESSIBLE FOR MAINTENANCE.
- ALL BUILDINGS WILL BE CONTINUOUSLY OCCUPIED. ALL SYSTEMS MUST BE AVAILABLE BY 7:00 AM AFTER A NIGHT OR ANY SHUT-DOWN.
- THIS CONTRACTOR IS RESPONSIBLE TO MOVE EXISTING FURNITURE OUT OF THE WAY OF THE REQUIRED WORK AND MOVE IT BACK AFTER THE WORK IS COMPLETED.
- DEMOLITION AND REMOVAL OF EXISTING FIRE ALARM DEVICES, CONDUIT, AND ALL OTHER COMPONENTS OF EXISTING FIRE ALARM SYSTEM TO TAKE PLACE AFTER INSTALLATION OF NEW FIRE ALARM SYSTEM IS COMPLETE. SEE DETAILS ON SHEET F501.

KEYED NOTES:

- ① DISCONNECT AND REMOVE EXISTING FA DEVICE. REMOVE WIRING, FITTINGS, SUPPORTS, AND SYSTEM JUNCTION BOXES. WIRING TO BE REMOVED TO THE SOURCE.

Revisions: Date	VETERANS AFFAIRS MEDICAL CENTER 500 E VETERANS ST TOMAH, WI 54660		CONSULTANTS:	PROJECT LEADER: PCG DESIGN / BUILD SERVICES 1021 N. Superior Ave, Unit 11 Tomah, Wisconsin 54660	Drawing Title FIRE ALARM - B212, B223, B240, B260, AND B270 GROUND FLOOR PLANS - DEMOLITION	Project Title UPGRADE FIRE ALARM SYSTEM DESIGN	FINAL BID DOCUMENTS	
					Approved: Project Director	Location Tomah, Wisconsin	Date APRIL 21, 2026	Checked By: HFB

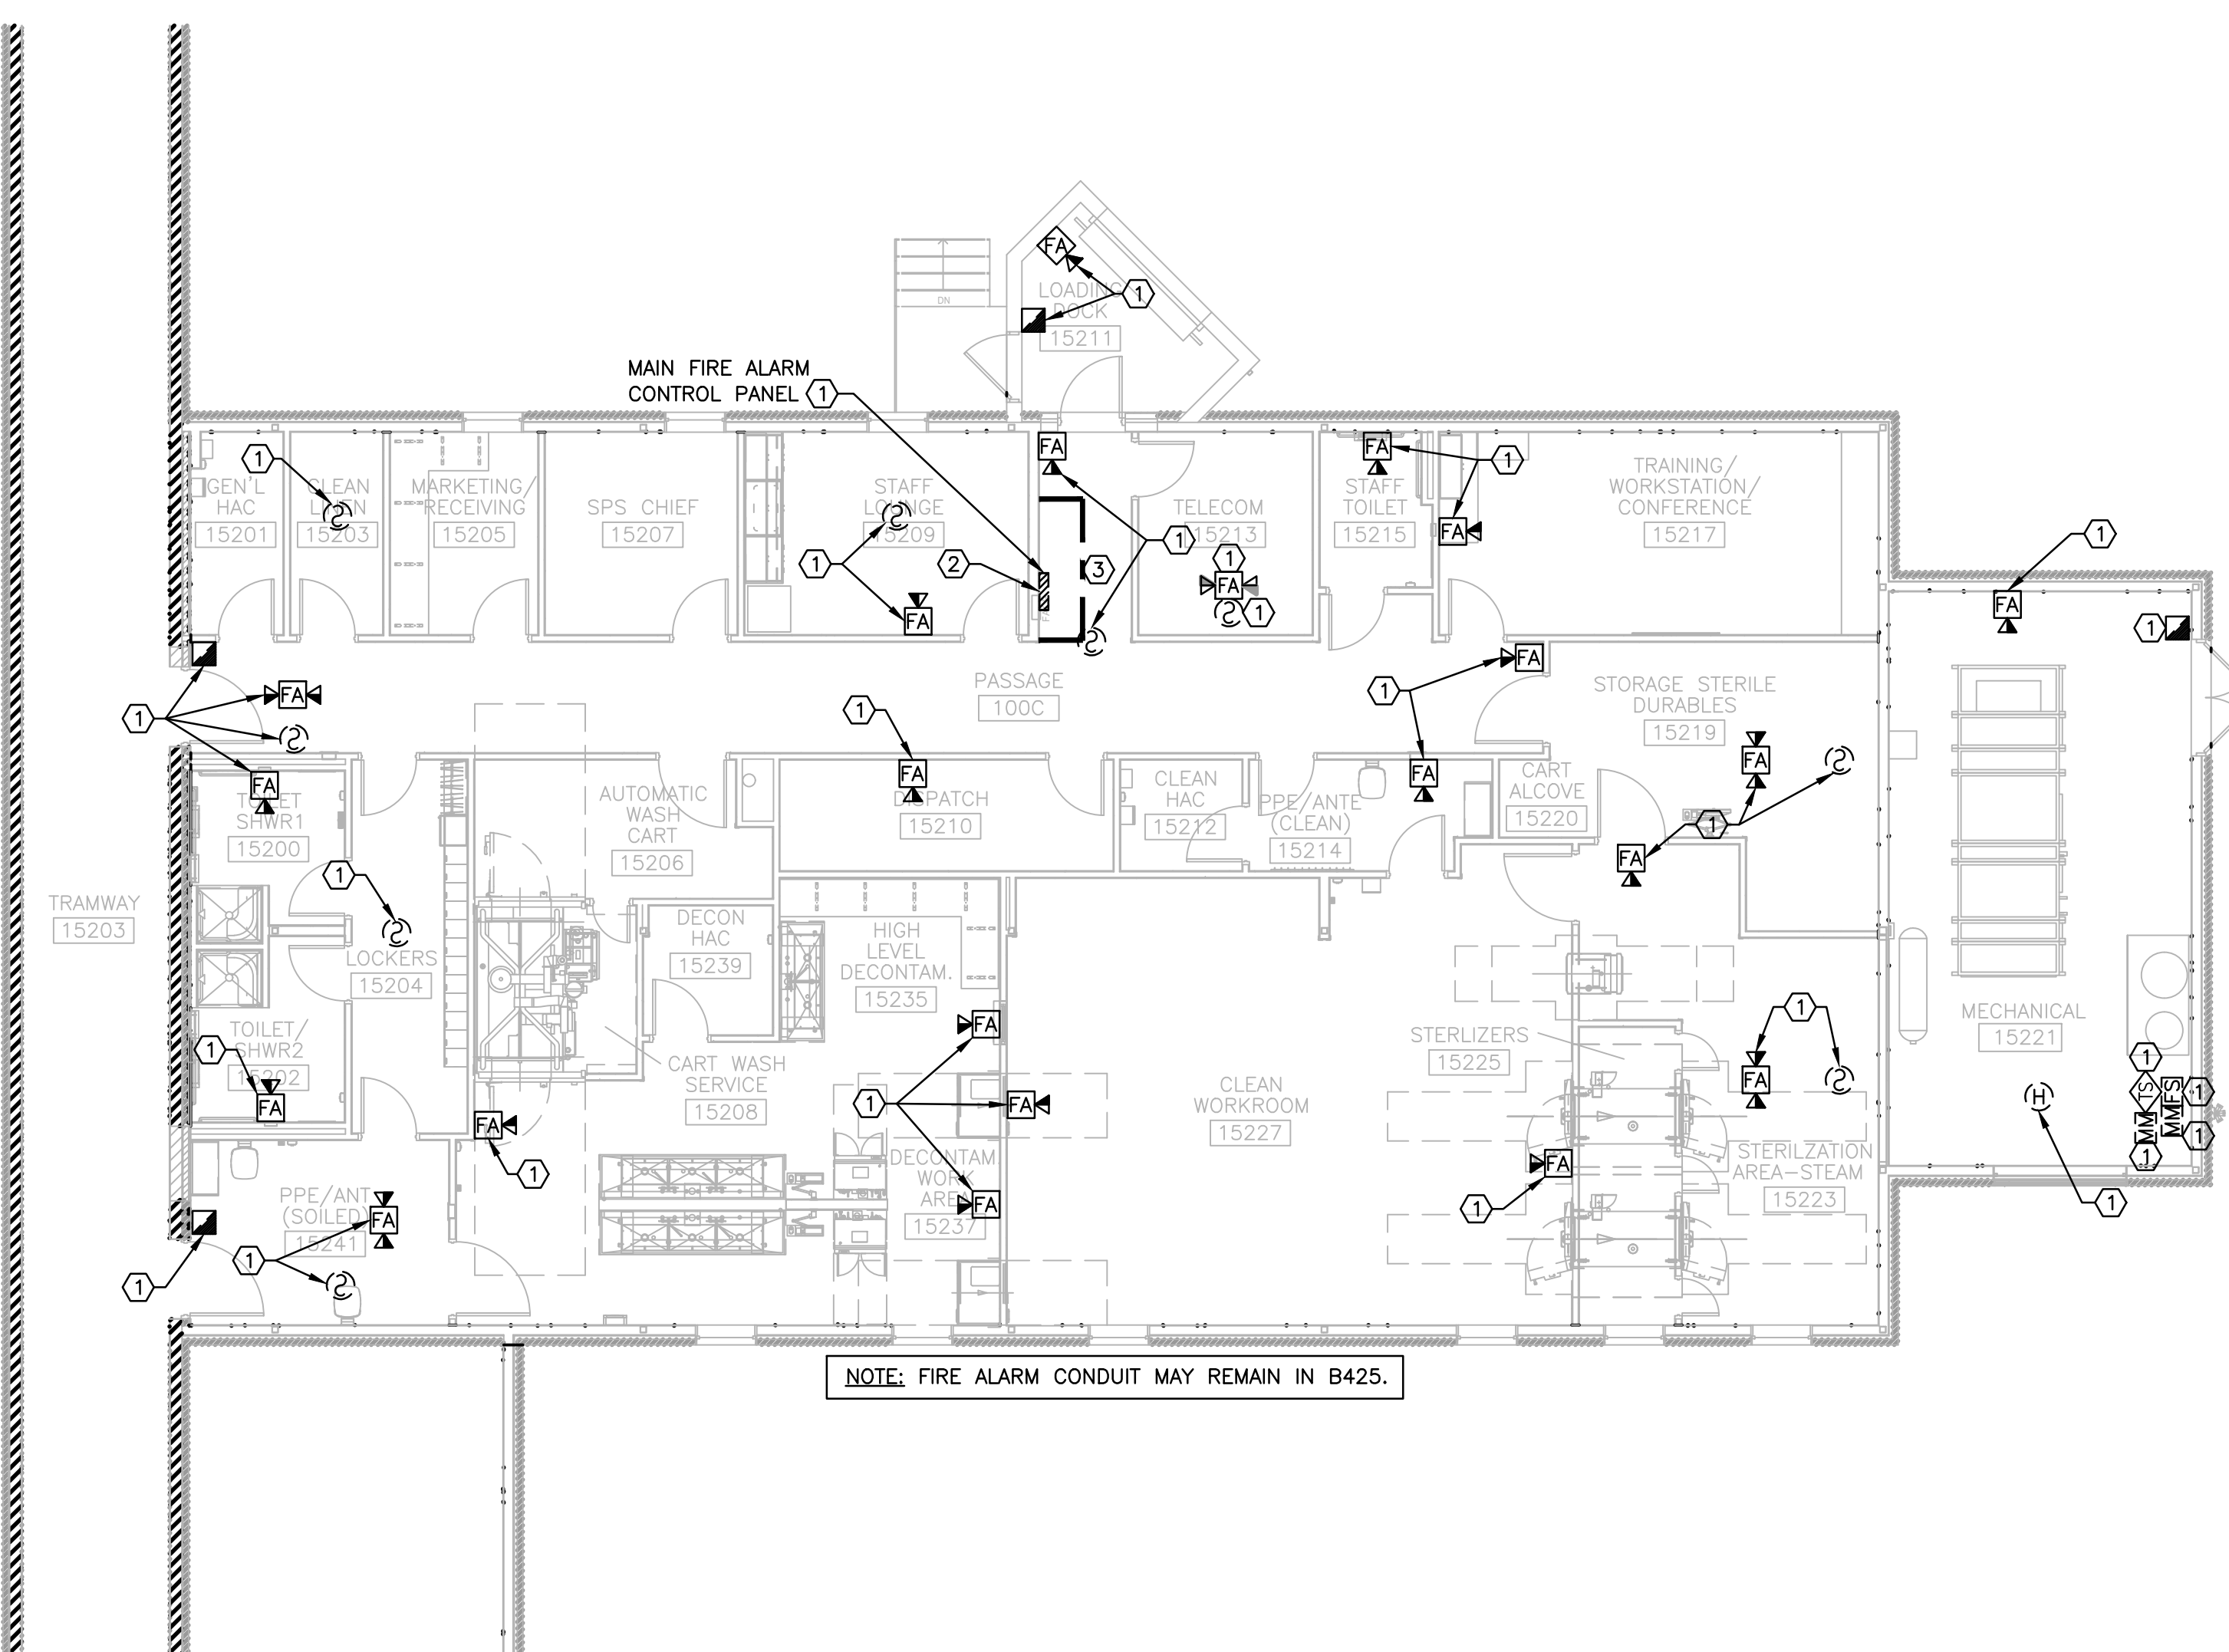

1 FIRST FLOOR
1/8" = 1'-0"



- GENERAL NOTES:

1. SEE SHEET F001 FOR LEGENDS, NOTES AND ABBREVIATIONS.
2. PROTECT ALL DEVICES AND EQUIPMENT TO REMAIN DURING CONSTRUCTION.
3. FIRE PROTECTION CONTRACTOR TO REVIEW ARCHITECTURAL AND ELECTRICAL PLANS FOR ADDITIONAL INFORMATION AND REQUIRED WORK NECESSARY TO FACILITATE A COMPLETE SYSTEM AND IS PART OF FIRE PROTECTION CONTRACTOR'S SCOPE OF WORK.
4. MAINTAIN CONTINUOUS UTILITY SERVICE TO ALL SPACES IN THE BUILDING NOT AFFECTED BY THIS WORK. COORDINATE WITH VA COR ANY DISRUPTION IN SERVICES REQUIRED TO PERFORM WORK.
5. PENETRATIONS THROUGH EXISTING WALLS AND FLOORS REQUIRE FIRE CAULKING BY THIS CONTRACTOR.
6. EXISTING SYSTEM LAYOUT IS BASED ON FIELD SURVEY. EXACT LOCATIONS AND ELEVATIONS MAY VARY.
7. REFER TO ALL OTHER PLANS, DIAGRAMS, DETAILS AND SPECIFICATIONS TO PROVIDE A FULLY FUNCTIONAL SYSTEM. PROVIDE OFFSETS NOT SHOWN ON DIAGRAMS TO AVOID OBSTRUCTIONS.
8. SUPPORT EQUIPMENT, PANELS, DEVICES, CABLES AND WIRING FROM STRUCTURE, WALLS AND FLOOR SO THAT ALL ITEMS ARE ACCESSIBLE FOR MAINTENANCE.
9. ALL BUILDINGS WILL BE CONTINUOUSLY OCCUPIED. ALL SYSTEMS MUST BE AVAILABLE BY 7:00 AM AFTER A NIGHT OR ANY SHUT-DOWN.
10. THIS CONTRACTOR IS RESPONSIBLE TO MOVE EXISTING FURNITURE OUT OF THE WAY OF THE REQUIRED WORK AND MOVE IT BACK AFTER THE WORK IS COMPLETED.
11. DEMOLITION AND REMOVAL OF EXISTING FIRE ALARM DEVICES, CONDUIT, AND ALL OTHER COMPONENTS OF EXISTING FIRE ALARM SYSTEM TAKE PLACE AFTER THE INSTALLATION OF NEW FIRE ALARM SYSTEM IS COMPLETE. SEE DETAIL ON SHEET F501.

KEYED NOTES:

- ① DISCONNECT AND REMOVE EXISTING FA DEVICE. REMOVE WIRING, FITTINGS, SUPPORTS, SYSTEM JUNCTION BOXES, RADIO TRANSMITTERS AND RECEIVERS. WIRING TO BE REMOVED TO THE SOURCE.
- ② WORK TO INSTALL NEW FIRE ALARM PANEL AND REMOVE EXISTING FIRE ALARM PANEL TO TAKE PLACE DURING NORMAL WORKING HOURS. SET UP THE ICB-1 BARRIER AT THE START OF WORK. REMOVE ICB-1 BARRIER AT END OF WORK. REMOVE ALL TOOLS AND EQUIPMENT DAILY. PROTECT ALL PROGRESS SO THAT ANY DRAWINGS IN WALLS OR CEILINGS ARE COVERED. SWEEP UP DUST IN AREA AND DAMP MOP FLOOR FOR DAILY CLEAN-UP.
- ③ PROVIDE ICB, SEE DETAIL 2. ON DRAWING GC101 FOR REQUIREMENTS.

NOTE: ACCESS PANELS MUST BE INSTALLED BEFORE ANY DEMOLITION WORK CAN BEGIN. SEE DRAWING FA155 FOR ACCESS PANEL LOCATIONS.

[illegible]

VETERANS AFFAIRS
MEDICAL CENTER
500 E VETERANS ST
TOMAH, WI 54660



CONSULTANTS:

PROJECT LEADER:



1021 N. Superior Ave, Unit 11
Tomah, Wisconsin 54660

Drawing Title	FIRE ALARM B452 FIRST FLOOR PLAN - DEMOLITION
---------------	---

Approved: Project Director

Project Title	UPGRADE FIRE ALARM SYSTEM DESIGN
---------------	-------------------------------------

	Location Tomah, Wisconsin

Date
APRIL 21, 2026

Checked By:	HFB
-------------	-----

Drawn By:
JMD

FINAL BID DOCUMENTS

Project Number	676-22-110
Building Number	B452

Drawing Number	FD155
----------------	-------

Office of
Facilities
Management

