

THIS DRAWING, INCLUDING ANY PATENTED OR UNPATENTED INFORMATION, IS THE PROPERTY OF LIND TECHNICAL SERVICES, LCC AND ITS USE IS CONDITIONED UPON THE USER'S AGREEMENT NOT TO REPRODUCE, COPIY, OR TRANSMIT THIS PART, NOR THE MATERIAL DESCRIBED THEREON, NOR TO USE THE DRAWING FOR ANY PURPOSE OTHER THAN THAT SPECIFICALLY AUTHORIZED IN WRITING BY THE LIND TECHNICAL SERVICE, LCC.



LIND TECHNICAL SERVICES, LCC
Address: 9337 Katy Fwy, STE B-51
Houston, TX 77024
+1 888-609-9837

PROFESSIONAL SEALS

Client: Department of Veterans Affairs

Address:
Phone:
Fax:
Email:

Consultant:
Address:
Phone:
Fax:
Email:

STAGES DESIGN	
ISSUED FOR APPROVAL	IFA
ISSUED FOR INFORMATION	IFI
ISSUED FOR BID	IFB
ISSUED FOR CONSTRUCTION	IFC
ISSUED FOR AS-BUILT	IFAB
ISSUED FOR RECORD	IFR

REVISIONS	
REV	DESCRIPTION
A	IFA
B	IFA
-	-
-	-
-	-
-	-

SIERRA NEVADA HEALTH CARE SYSTEM


ADJ0001

DRAWING TITLE
SINGLE LINE DIAGRAM
MEDIUM VOLTAGE

SYSTEM:
ELECTRICAL

Drawing by:	Ham Tran
Design by:	Long Tran
Rechecked by:	Deepak Maragal
Approved:	

DRAWING NUMBER:	REV:
MEDIUM VOLTAGE	B

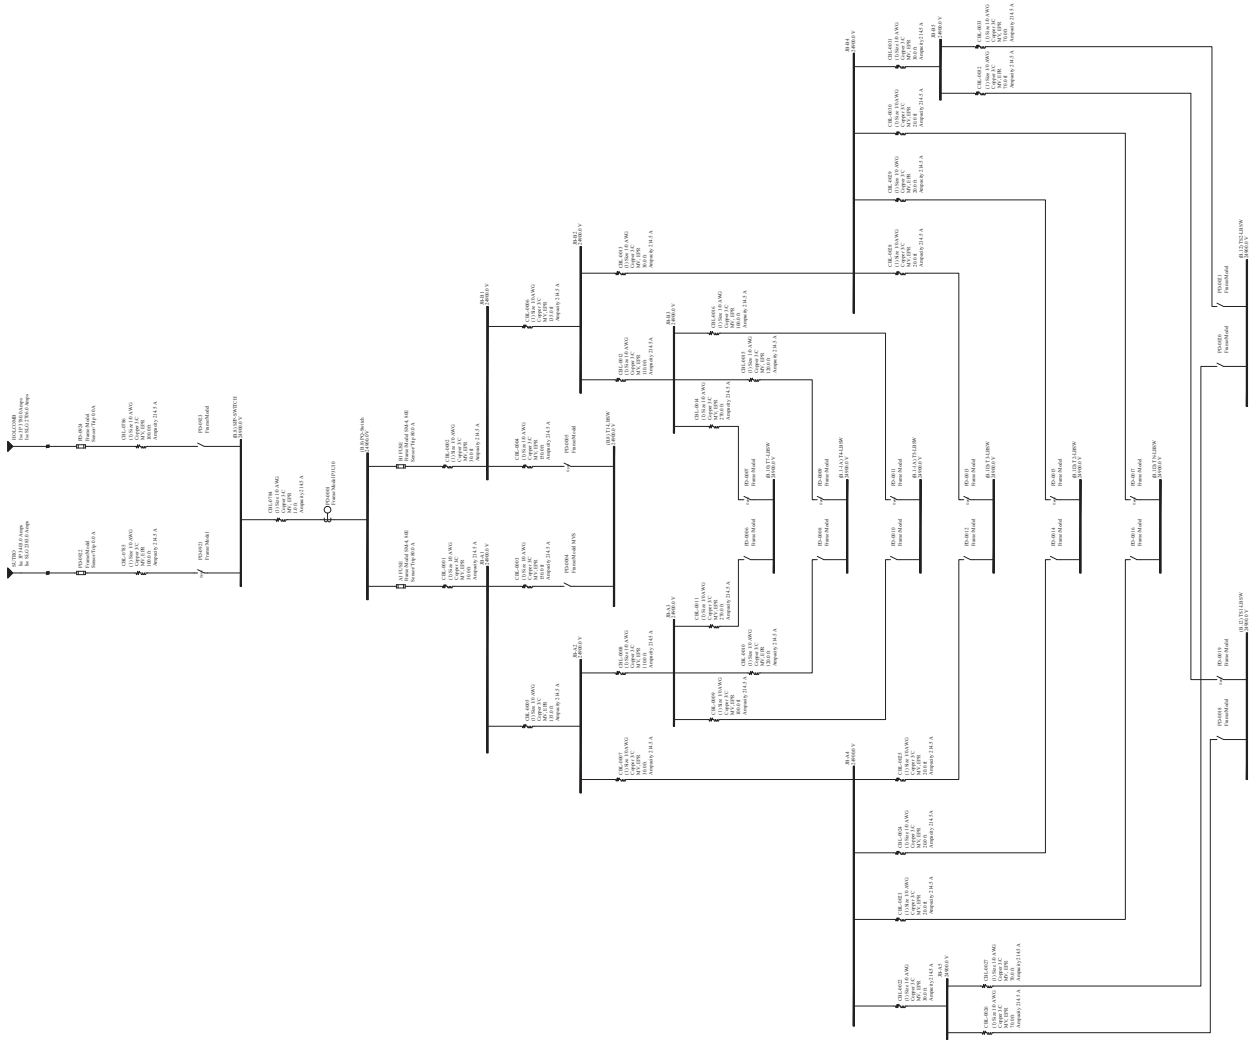

THE DRAWING INCLUDING ANY PATENTED OR UNPATENTED INFORMATION IS THE PROPERTY OF LIND TECHNICAL SERVICES, LLC AND ITS USE IS CONFIDENTIAL INFORMATION OF THE LIND TECHNICAL SERVICE, LLC AND ITS USE IS CONDITIONED UPON THE USER'S AGREEMENT NOT TO REPRODUCE, COPIY, OR TRANSMIT IN ANY PART, NOR THE MATERIAL DESCRIBED THEREON, NOR TO USE THE DRAWING FOR ANY PURPOSE OTHER THAN THAT SPECIFICALLY INTENDED IN WRITING BY THE LIND TECHNICAL SERVICE, LLC.



LIND TECHNICAL SERVICES, LLC
Address: 9337 Katy Fwy, STE B-51
Houston, TX 77024
+1 888-697-9837

PROFESSIONAL SEALS

Client: Department of Veterans Affairs
Address:
Phone:
Fax:
Email:

Consultant:
Address:
Phone:
Fax:
Email:

STAGES DESIGN			
ISSUED FOR APPROVAL	IFA		
ISSUED FOR INFORMATION	IFI		
ISSUED FOR BID	IFB		
ISSUED FOR CONSTRUCTION	IFC		
ISSUED FOR AS-BUILT	IFAB		
ISSUED FOR RECORD	IFR		

REV		DESCRIPTION	DATE
A	IFA		07/18/2024
B	IFA		08/04/2024
-	-	-	-
-	-	-	-
-	-	-	-

SIERRA NEVADA HEALTH CARE SYSTEM


ADJ:REV:

DRAWING TITLE
SINGLE LINE DIAGRAM
BLDG ID-4-1

SYSTEM:
ELECTRICAL

DRAWING BY:	Rev: 1.00
DRAWING BY:	Rev: 1.00
DESIGNED BY:	Long, David
REVIEWED BY:	David, David
DESIGNED BY:	David, David
DESIGNED BY:	David, David

DRAWING NUMBER:	REV:
BLDG ID-4-1	B

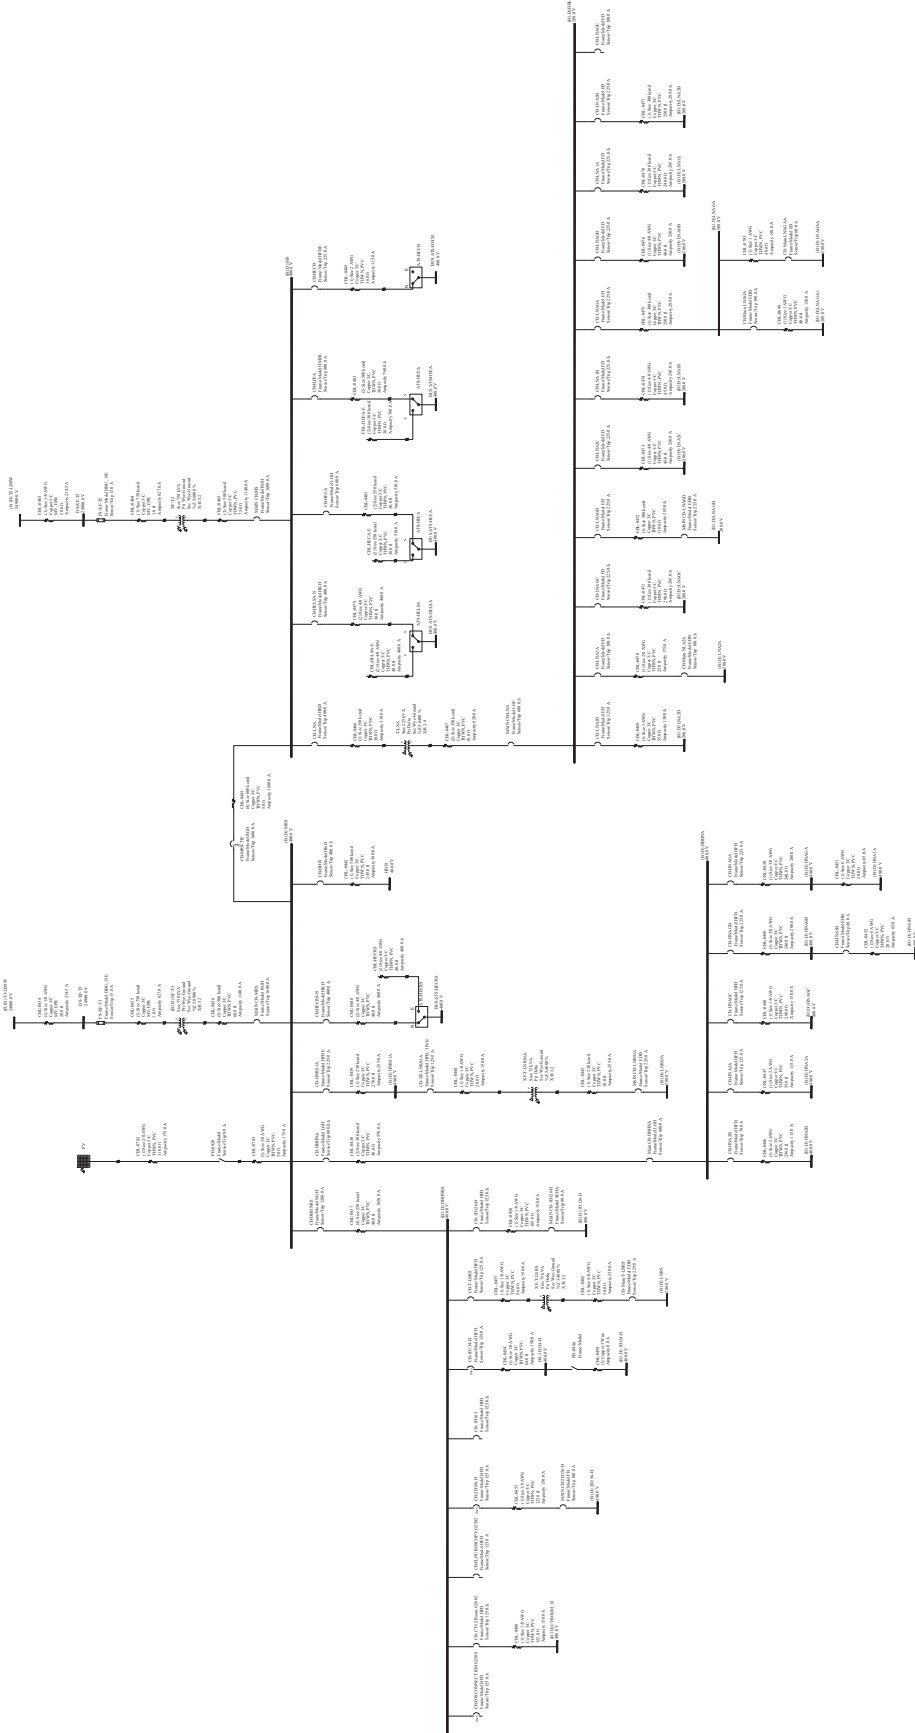

THE DRAWING, INCLUDING ANY PATENTED OR UNPATENTED INFORMATION, IS THE PROPERTY OF LIND TECHNICAL SERVICES, LCC AND ITS USE IS CONDITIONED UPON THE USER'S AGREEMENT NOT TO REPRODUCE, COPIY, OR TRANSMIT IN ANY FORM OR BY ANY MEANS, ELECTRONIC OR MECHANICAL, INCLUDING PHOTOCOPYING, RECORDING, OR BY ANY INFORMATION STORAGE AND RETRIEVAL SYSTEM, WITHOUT THE WRITTEN PERMISSION OF LIND TECHNICAL SERVICES, LCC. TO USE THE DRAWING FOR ANY PURPOSE OTHER THAN THAT SPECIFICALLY AUTHORIZED IN WRITING BY THE LIND TECHNICAL SERVICES, LCC.



LIND TECHNICAL SERVICES, LLC
Address: 9337 Katy Fwy, STE B-51
Houston, TX 77024
+1 888-609-9837

PROFESSIONAL SEALS

Client: Department of Veterans Affairs

Address:
Phone:
Fax:
Email:

Consultant:
Address:
Phone:
Fax:
Email:

STAGES DESIGN	
ISSUED FOR APPROVAL	IFA
ISSUED FOR INFORMATION	IFI
ISSUED FOR BID	IFB
ISSUED FOR CONSTRUCTION	IFC
ISSUED FOR AS-BUILT	IFAB
ISSUED FOR RECORD	IFR


DESCRIPTION	
REV	DATE
A	IFA
B	IFA
-	-
-	-
-	-

SIERRA NEVADA HEALTH CARE SYSTEM

ADJ0001

DRAWING TITLE
SINGLE LINE DIAGRAM
BLDG ID-4-2

SYSTEM:	
ELECTRICAL	
Drawn by:	Shawn Pines
Design by:	Long Tran
Reviewed by:	David B. Thompson
Approved:	
DRAWING NUMBER:	REV: B

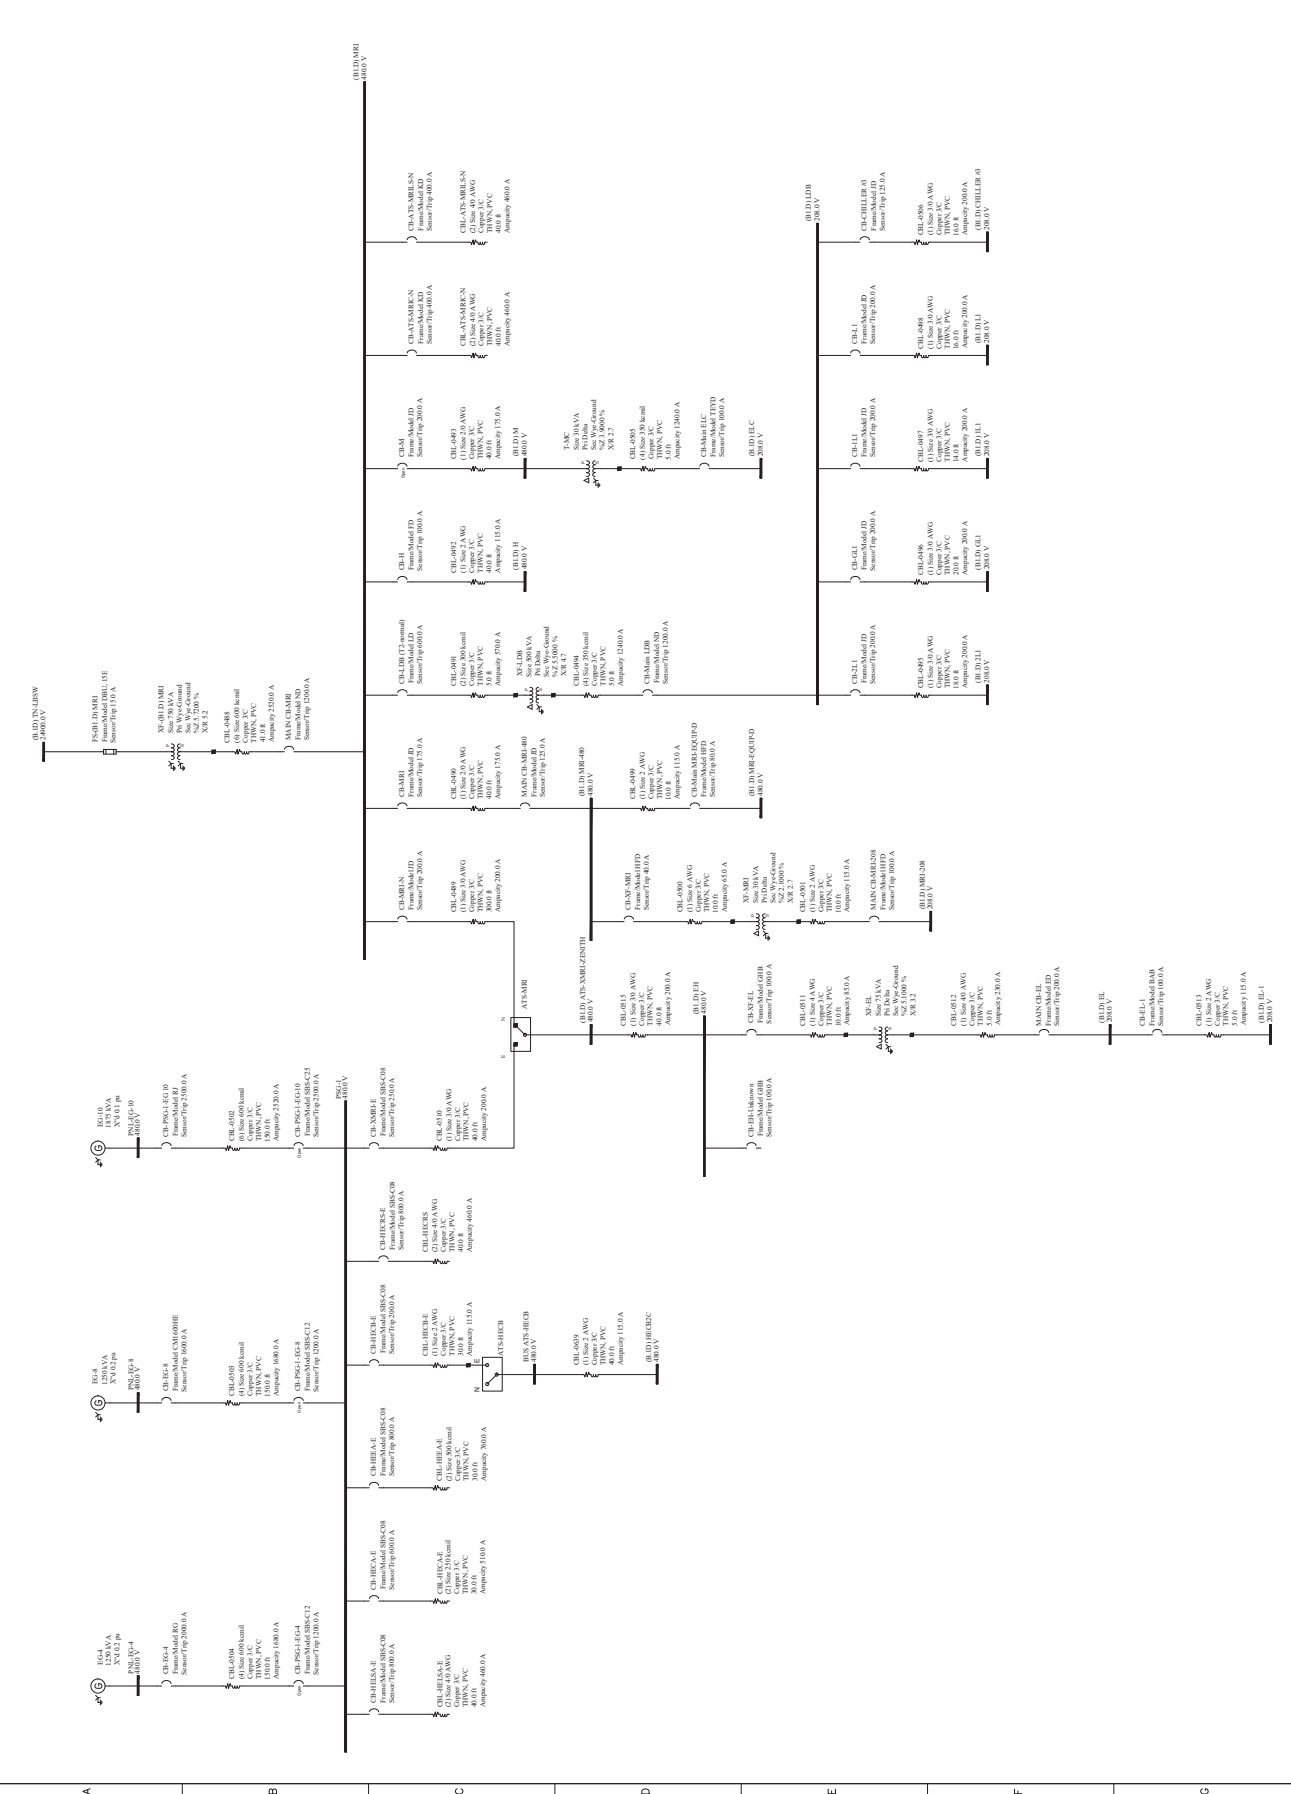

THIS DRAWING, INCLUDING ANY PATENTED OR UNPATENTED INFORMATION, IS THE PROPERTY OF LIND TECHNICAL SERVICES, LCC AND ITS USE IS CONDITIONED UPON THE USER'S AGREEMENT NOT TO REPRODUCE, COPIY, OR TRANSMIT IN ANY FORM OR BY ANY MEANS, ELECTRONIC OR MECHANICAL, INCLUDING PHOTOCOPYING, RECORDING, OR BY ANY INFORMATION STORAGE AND RETRIEVAL SYSTEM, WITHOUT THE WRITTEN PERMISSION OF LIND TECHNICAL SERVICES, LCC. NO PART OF THIS DRAWING IS TO BE USED FOR ANY PURPOSE OTHER THAN THAT SPECIFICALLY INTENDED IN WRITING BY THE LIND TECHNICAL SERVICES, LCC.



LIND TECHNICAL SERVICES, LCC
Address: 9337 Katy Fwy, STE B-51
Houston, TX 77024
+1 888-697-9837

PROFESSIONAL SEALS

Client: Department of Veterans Affairs
Address:
Phone:
Fax:
Email:

Consultant:
Address:
Phone:
Fax:
Email:

STAGES DESIGN			
ISSUED FOR APPROVAL	IFA		
ISSUED FOR INFORMATION	IFI		
ISSUED FOR BID	IFB		
ISSUED FOR CONSTRUCTION	IFC		
ISSUED FOR AS-BUILT	IFAB		
ISSUED FOR RECORD	IFR		
REV	DESCRIPTION	DATE	
A	IFA	07/16/2024	
B	IFA	08/04/2024	
-	-	-	
-	-	-	
-	-	-	


SIERRA NEVADA
HEALTH CARE SYSTEM

ADDRESS:

DRAWING TITLE
SINGLE LINE DIAGRAM
BLDG ID-4-3

SYSTEM:			
ELECTRICAL			
DRAWING BY:	NAME	DATE	
DESIGNED BY:	NAME	DATE	
CHECKED BY:	NAME	DATE	
APPROVED BY:	NAME	DATE	

DRAWING NUMBER:	REV:
BLDG ID-4-3	B

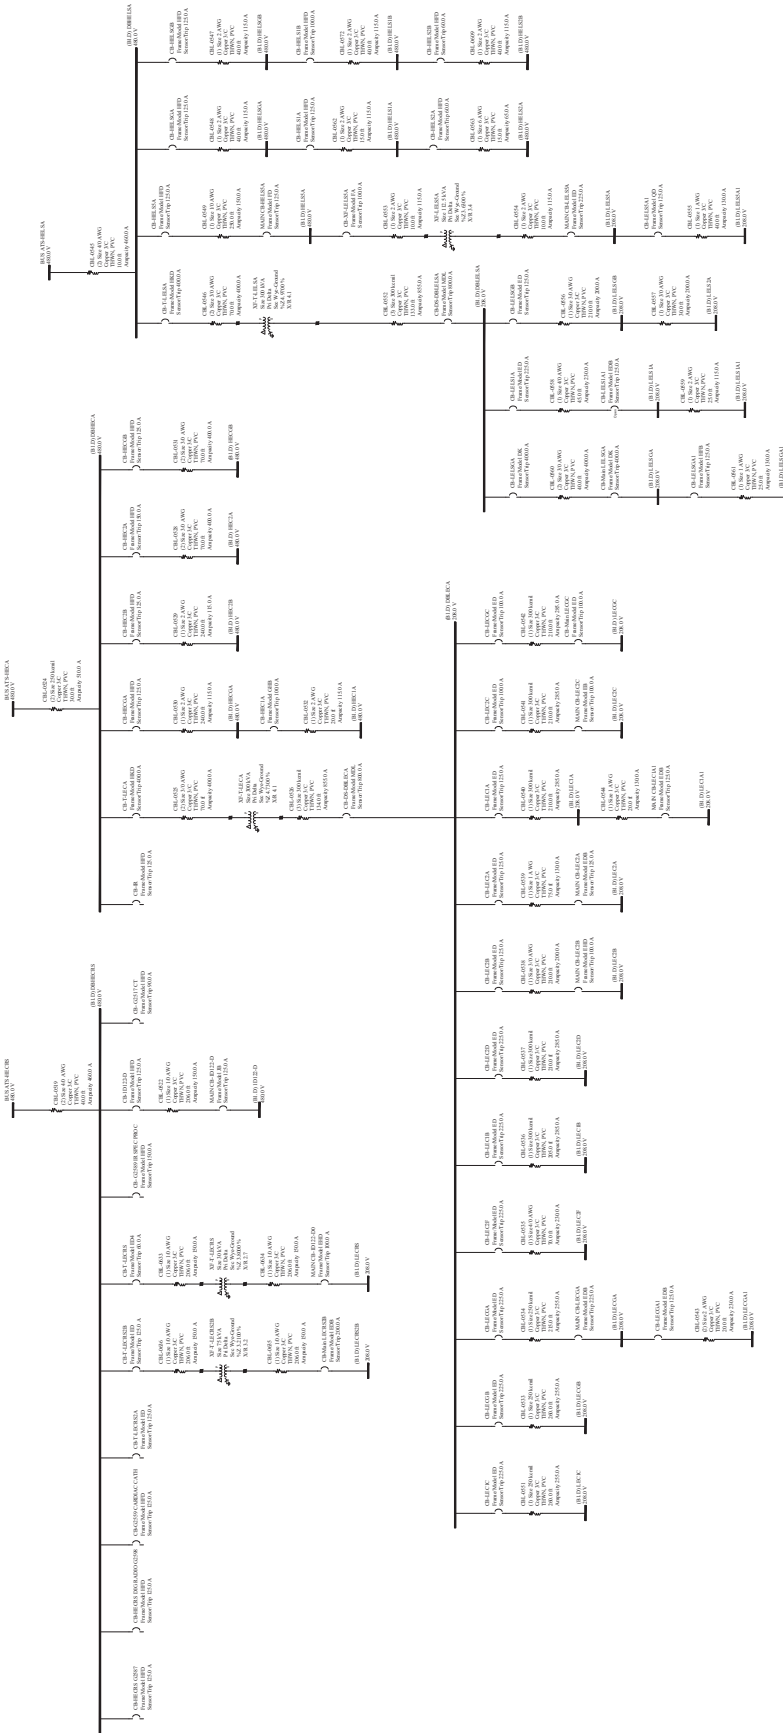

THIS DRAWING, INCLUDING ANY PATENTED OR UNPATENTED INVENTIONS, IS THE PROPERTY OF LIND TECHNICAL SERVICES, L.L.C. AND ITS USE IS CONDITIONED UPON THE USER'S AGREEMENT NOT TO REPRODUCE, COPIY, OR TRANSMIT IN ANY FORM OR BY ANY MEANS, ELECTRONIC OR MECHANICAL, INCLUDING PHOTOCOPYING, RECORDING, OR BY ANY INFORMATION STORAGE AND RETRIEVAL SYSTEM, WITHOUT THE WRITTEN PERMISSION OF LIND TECHNICAL SERVICES, L.L.C. TO USE THE DRAWING FOR ANY PURPOSE OTHER THAN THAT SPECIFICALLY INTENDED IN WRITING BY THE LIND TECHNICAL SERVICES, L.L.C.



LIND TECHNICAL SERVICES, L.L.C.
Address: 9337 Katy Fwy, STE B-51
Houston, TX 77024
+1 888-697-9837

PROFESSIONAL SEALS

Client: Department of Veterans Affairs
Address:
Phone:
Fax:
Email:

Consultant:
Address:
Phone:
Fax:
Email:

STAGES DESIGN			
☒	ISSUED FOR APPROVAL	IFA	
☐	ISSUED FOR INFORMATION	IFI	
☐	ISSUED FOR BID	IFB	
☐	ISSUED FOR CONSTRUCTION	IFC	
☐	ISSUED FOR AS-BUILT	IFAB	
☐	ISSUED FOR RECORD	IFR	

REV	DESCRIPTION	DATE
A	IFA	07/18/2024
B	IFA	08/04/2024
-	-	-
-	-	-
-	-	-

SIERRA NEVADA HEALTH CARE SYSTEM

ADDRESS:

DRAWING TITLE
SINGLE LINE DIAGRAM
BLDG-1A-1

SYSTEM:
ELECTRICAL

Drawing by:	Blm Tran
Design by:	Long Quid
Rechecked by:	David Wang
Approved:	

DRAWING NUMBER:	BDG-1A-1
REV:	B



THE DRAWING INCLUDING ANY PATENTED OR UNPATENTED INFORMATION OR INVENTION IS THE PROPERTY OF LIND TECHNICAL SERVICES, LCC AND ITS USE IS CONDITIONED UPON THE USER'S AGREEMENT NOT TO REPRODUCE, COPIY, OR TRANSMIT IN ANY FORM OR BY ANY MEANS, ELECTRONIC OR MECHANICAL, INCLUDING PHOTOCOPYING, RECORDING, OR BY ANY INFORMATION STORAGE AND RETRIEVAL SYSTEM, WITHOUT PERMISSION IN WRITING BY THE LIND TECHNICAL SERVICE, LCC.



LIND TECHNICAL SERVICES, LCC
Address: 9337 Katy Fwy, STE B-51
Houston, TX 77024
+1 888-609-9837

PROFESSIONAL SEALS

Client: Department of Veterans Affairs

Address:
Phone:
Fax:
Email:

Consultant:
Address:
Phone:
Fax:
Email:

STAGES DESIGN	
☒ ISSUED FOR APPROVAL	IFA
☐ ISSUED FOR INFORMATION	IFI
☐ ISSUED FOR BID	IFB
☐ ISSUED FOR CONSTRUCTION	IFC
☐ ISSUED FOR AS-BUILT	IFAB
☐ ISSUED FOR RECORD	IFR

REVISIONS	
REV	DESCRIPTION
A	IFA
B	IFA
-	-
-	-
-	-
-	-


SIERRA NEVADA HEALTH CARE SYSTEM

ADJ0001

DRAWING TITLE	
SINGLE LINE DIAGRAM BLDG-1A-2	

SYSTEM:	
ELECTRICAL	
Drawing by:	Alan Tran
Design by:	Long Quat
Reviewed by:	DEPAK MARGAL
Approved:	

DRAWING NUMBER:	REV:
BLDG-1A-2	B

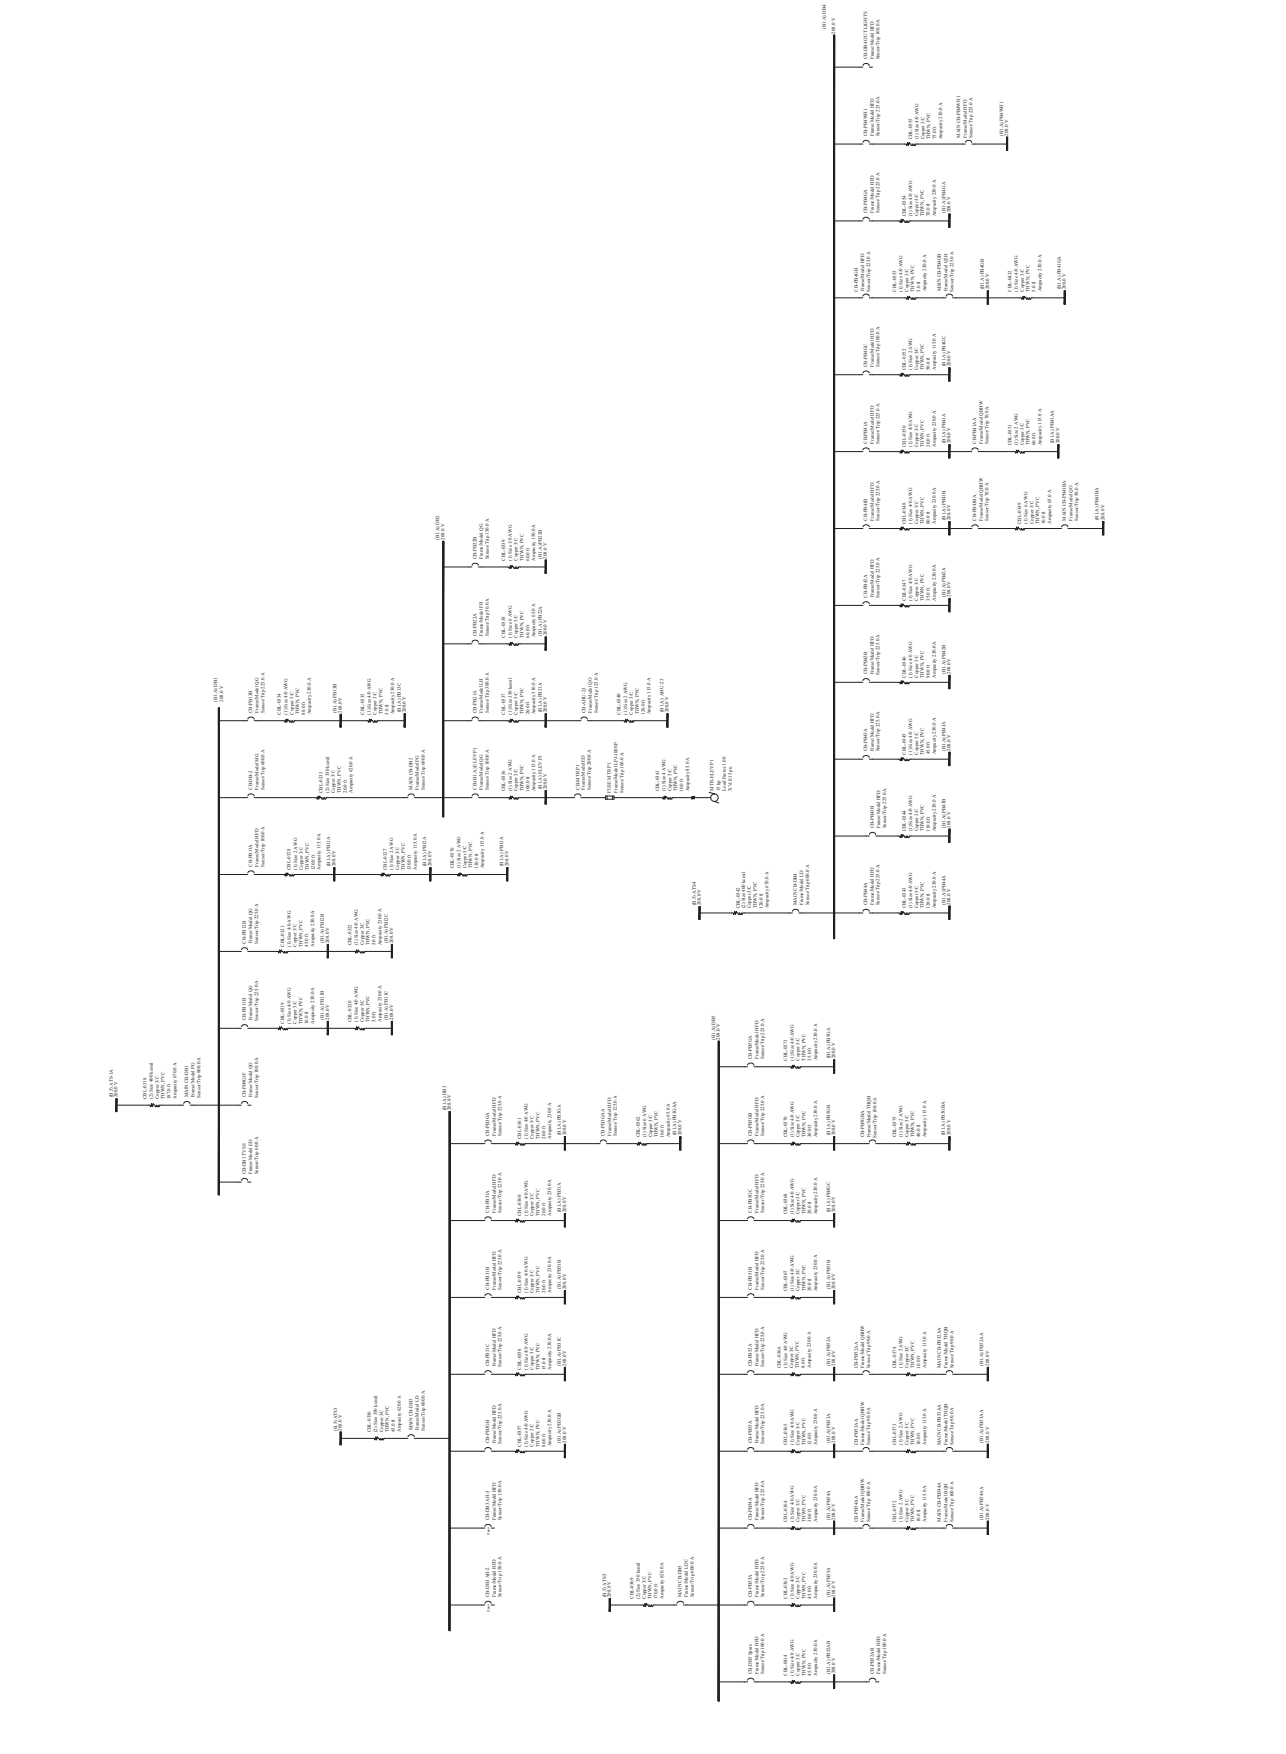

THE DRAWING, INCLUDING ANY PATENTED OR UNPATENTED INFORMATION, IS THE PROPERTY OF LIND TECHNICAL SERVICES, LCC AND ITS USE IS CONDITIONED UPON THE USER'S AGREEMENT NOT TO REPRODUCE, COPIY, OR TRANSMIT IN ANY FORM OR BY ANY MEANS, ELECTRONIC OR MECHANICAL, INCLUDING PHOTOCOPYING, RECORDING, OR BY ANY INFORMATION STORAGE AND RETRIEVAL SYSTEM, WITHOUT THE WRITTEN PERMISSION OF LIND TECHNICAL SERVICES, LCC. NO PART OF THE DRAWING FOR ANY PURPOSE OTHER THAN THAT SPECIFICALLY INTENDED IN WRITING BY THE LIND TECHNICAL SERVICE, LLC.



LIND TECHNICAL SERVICES, LLC
Address: 9337 Katy Pkwy, STE B-51
Houston, TX 77024
+1 888-469-9837

PROFESSIONAL SEALS

Client: Department of Veterans Affairs
Address:
Phone:
Fax:
Email:

Consultant:
Address:
Phone:
Fax:
Email:

STAGES DESIGN			
☒	ISSUED FOR APPROVAL	IFA	
☐	ISSUED FOR INFORMATION	IFI	
☐	ISSUED FOR BID	IFB	
☐	ISSUED FOR CONSTRUCTION	IFC	
☐	ISSUED FOR AS-BUILT	IFAB	
☐	ISSUED FOR RECORD	IFR	

REV		DATE	
A	IFA	07/16/2024	
B	IFA	08/04/2024	
-	-	-	-
-	-	-	-
-	-	-	-


SIERRA NEVADA HEALTH CARE SYSTEM

ADDRESS:

DRAWING TITLE	
SINGLE LINE DIAGRAM BLDG-1A-3	

SYSTEM:	
ELECTRICAL	
Drawing by:	Ham Tran
Design by:	Long Tran
Rechecked by:	Diep Tran
Approved:	Diep Tran

DRAWING NUMBER:	REV:
BLDG-1A-3	B

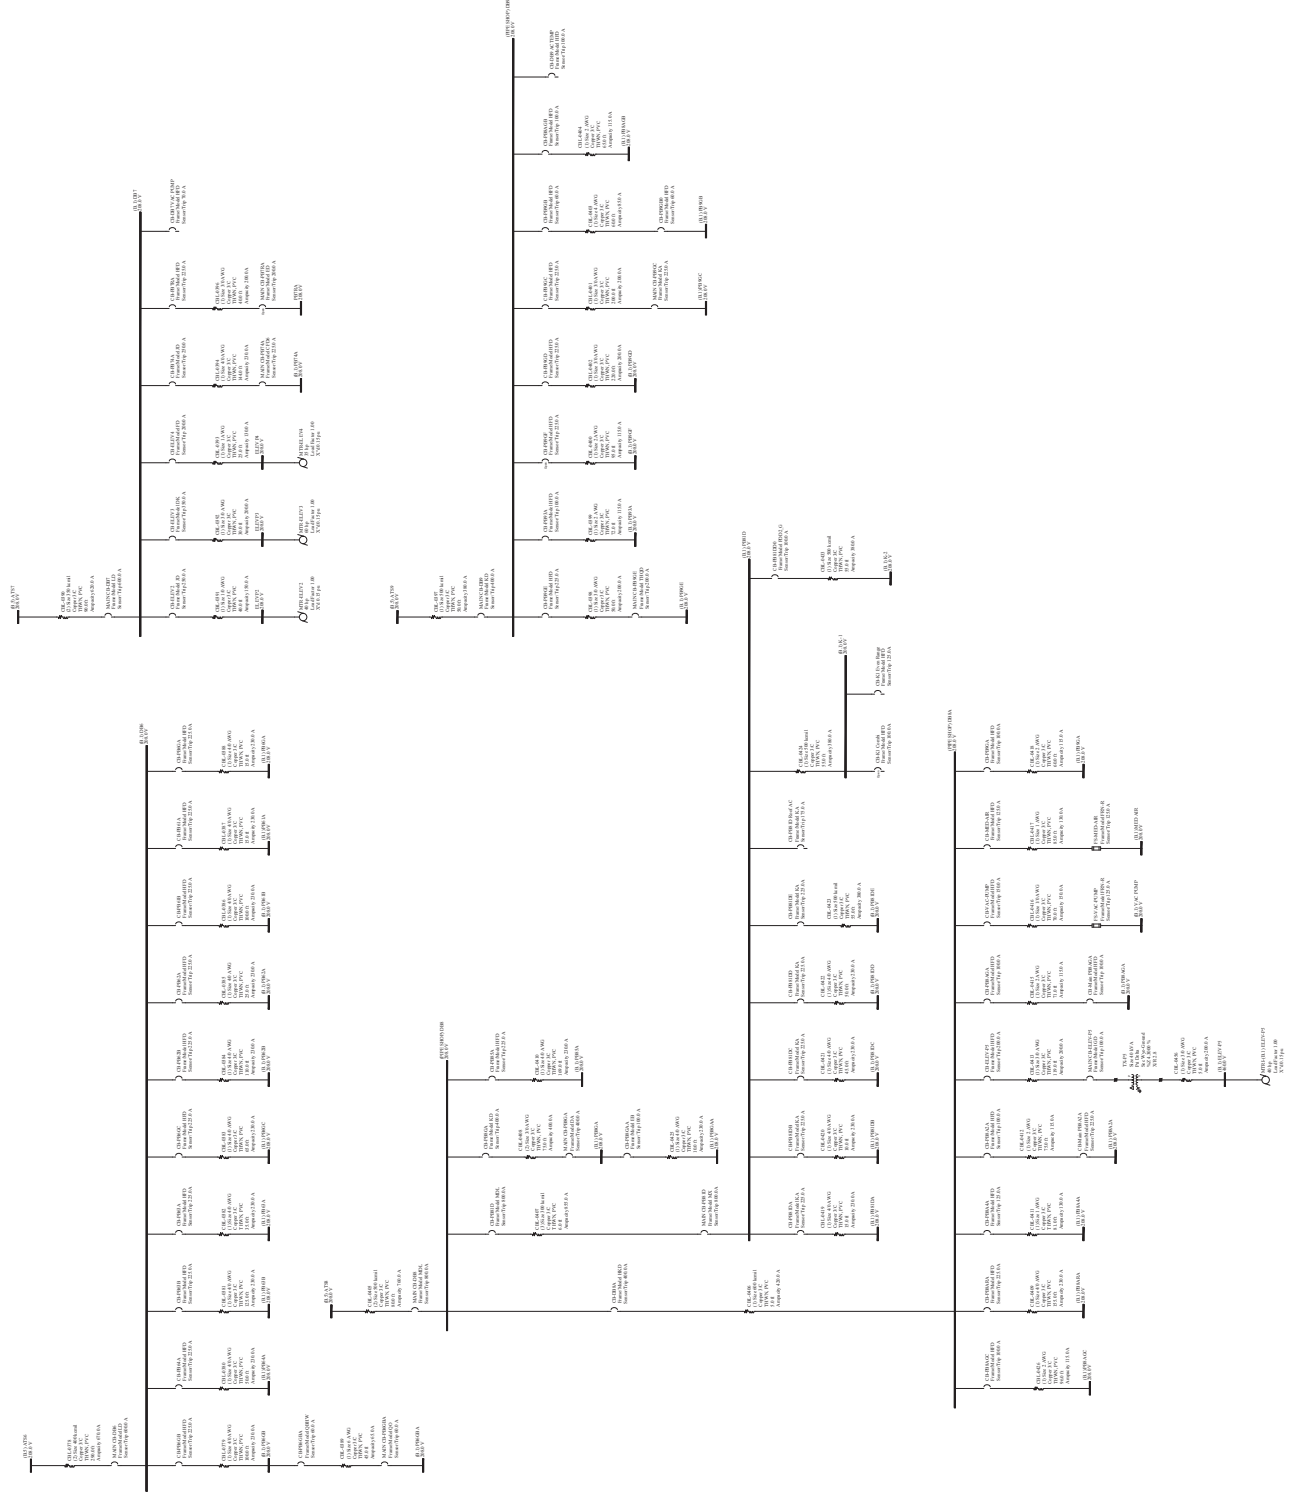

THIS DRAWING, INCLUDING ANY PATENTED OR UNPATENTED INVENTIONS, IS THE PROPERTY OF LIND TECHNICAL SERVICES, LCC AND ITS USE IS CONDITIONED UPON THE USER'S AGREEMENT NOT TO REPRODUCE, COPIY, OR TRANSMIT IN ANY PART, NOR THE MATERIAL DESCRIBED THEREON, NOR TO USE THE DRAWING FOR ANY PURPOSE OTHER THAN THAT SPECIFICALLY INTENDED IN WRITING BY THE LIND TECHNICAL SERVICE, LLC.



LIND TECHNICAL SERVICES, LLC
Address: 9337 Katy Fwy, STE B-51
Houston, TX 77024
+1 888-697-9837

PROFESSIONAL SEALS

Client: Department of Veterans Affairs
Address:
Phone:
Fax:
Email:

Consultant:
Address:
Phone:
Fax:
Email:

STAGES DESIGN			
☒	ISSUED FOR APPROVAL	IFA	
☐	ISSUED FOR INFORMATION	IFI	
☐	ISSUED FOR BID	IFB	
☐	ISSUED FOR CONSTRUCTION	IFC	
☐	ISSUED FOR AS-BUILT	IFAB	
☐	ISSUED FOR RECORD	IFR	

REVISION		DESCRIPTION	DATE
A	IFA		07/16/2024
B	IFA		08/04/2024
-	-	-	-
-	-	-	-
-	-	-	-

SIERRA NEVADA HEALTH CARE SYSTEM

Address:

DRAWING TITLE


SINGLE LINE DIAGRAM
BLDG5

SYSTEM:

ELECTRICAL

Drawing by:	Ham Tran
Design by:	Long Quat
Rechecked by:	DePax MARGAL
Approved:	

DRAWING NUMBER:	REV:
BLDG5	B

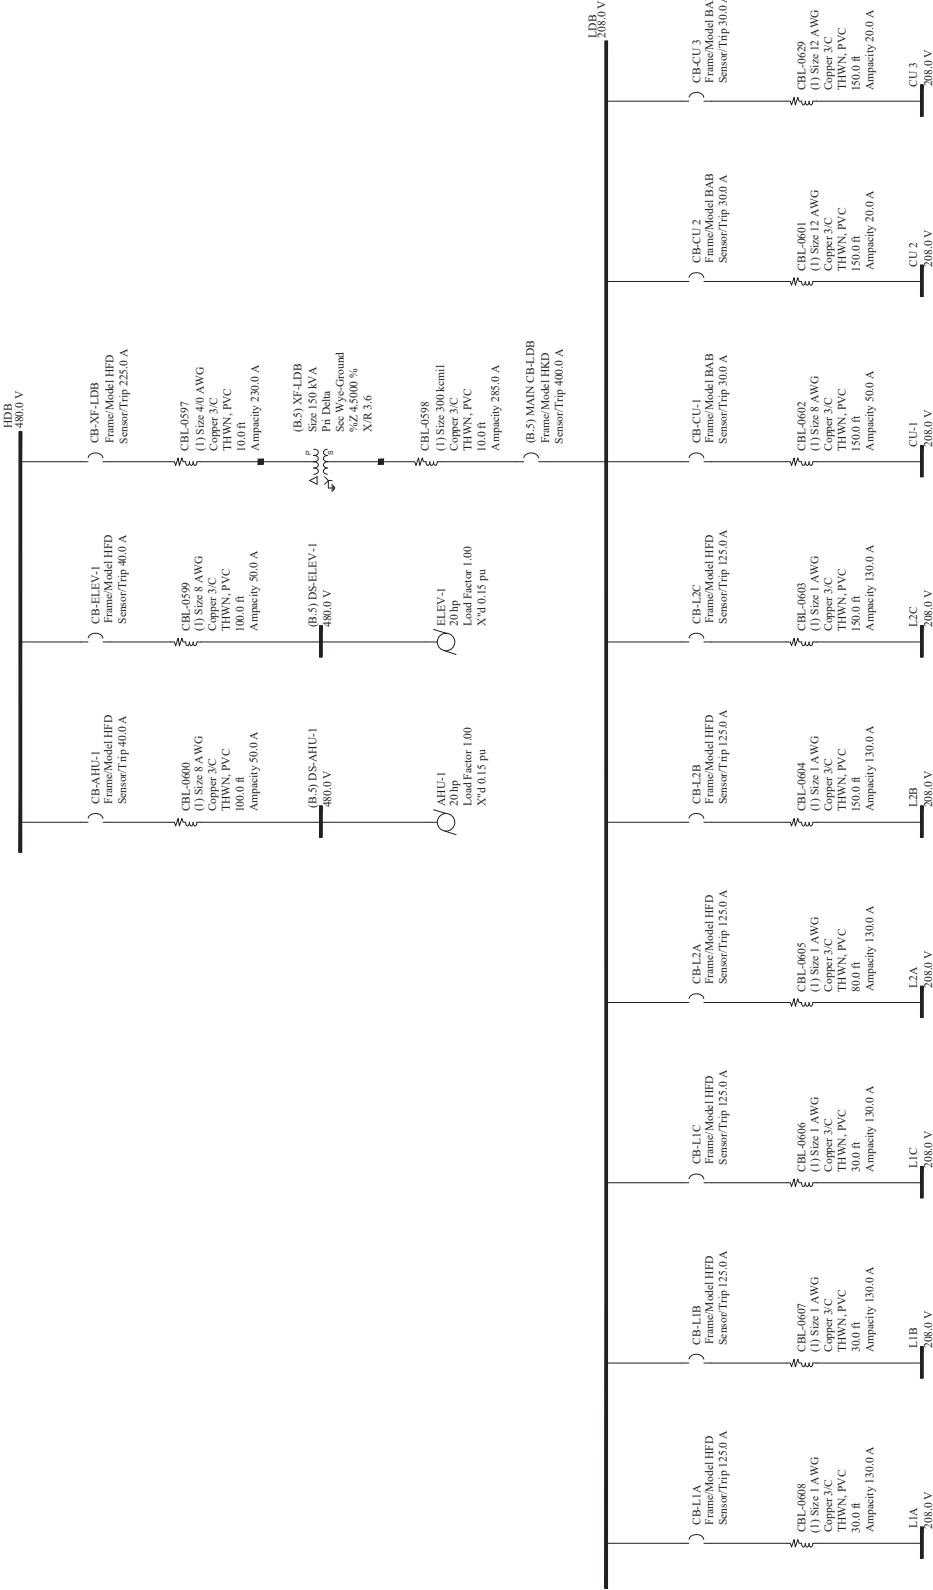

THIS DRAWING, INCLUDING ANY PATENTED OR UNPATENTED DESIGN OR INVENTION, IS THE PROPERTY OF LIND TECHNICAL SERVICES, LLC AND IS TO BE USED ONLY FOR THE PROJECT AND SITE SPECIFICALLY IDENTIFIED HEREON. NO PART OF THIS DRAWING IS TO BE REPRODUCED, COPIED, OR TRANSMITTED IN ANY FORM OR BY ANY MEANS, ELECTRONIC OR MECHANICAL, INCLUDING PHOTOCOPYING, RECORDING, OR BY ANY INFORMATION STORAGE AND RETRIEVAL SYSTEM, WITHOUT THE WRITTEN PERMISSION OF LIND TECHNICAL SERVICES, LLC.



LIND TECHNICAL SERVICES, LLC
Address: 9337 Katy Fwy, STE B-51
Houston, TX 77024
+1 888-697-9837

PROFESSIONAL SEALS

Client: Department of Veterans Affairs
Address:
Phone:
Fax:
Email:

Consultant:
Address:
Phone:
Fax:
Email:

STAGES DESIGN

ISSUED FOR APPROVAL	IFA
ISSUED FOR INFORMATION	IFI
ISSUED FOR BID	IFB
ISSUED FOR CONSTRUCTION	IFC
ISSUED FOR AS-BUILT	IFAB
ISSUED FOR RECORD	IFR

REV	DESCRIPTION	DATE
A	IFA	07/16/2024
B	IFA	08/04/2024
-	-	-
-	-	-
-	-	-

SIERRA NEVADA
HEALTH CARE SYSTEM

ADDRESS:


DRAWING TITLE
SINGLE LINE DIAGRAM
BLDG6

SYSTEM:

ELECTRICAL

DRAWING BY:	HAM TRAN	Rev: None
DESIGNED BY:	LONG TRAN	Long Tran
RECHECKED BY:	DEPAK MARA GAL	Deepak Maragal
APPROVED:		

DRAWING NUMBER:	BLDG6
REV:	B

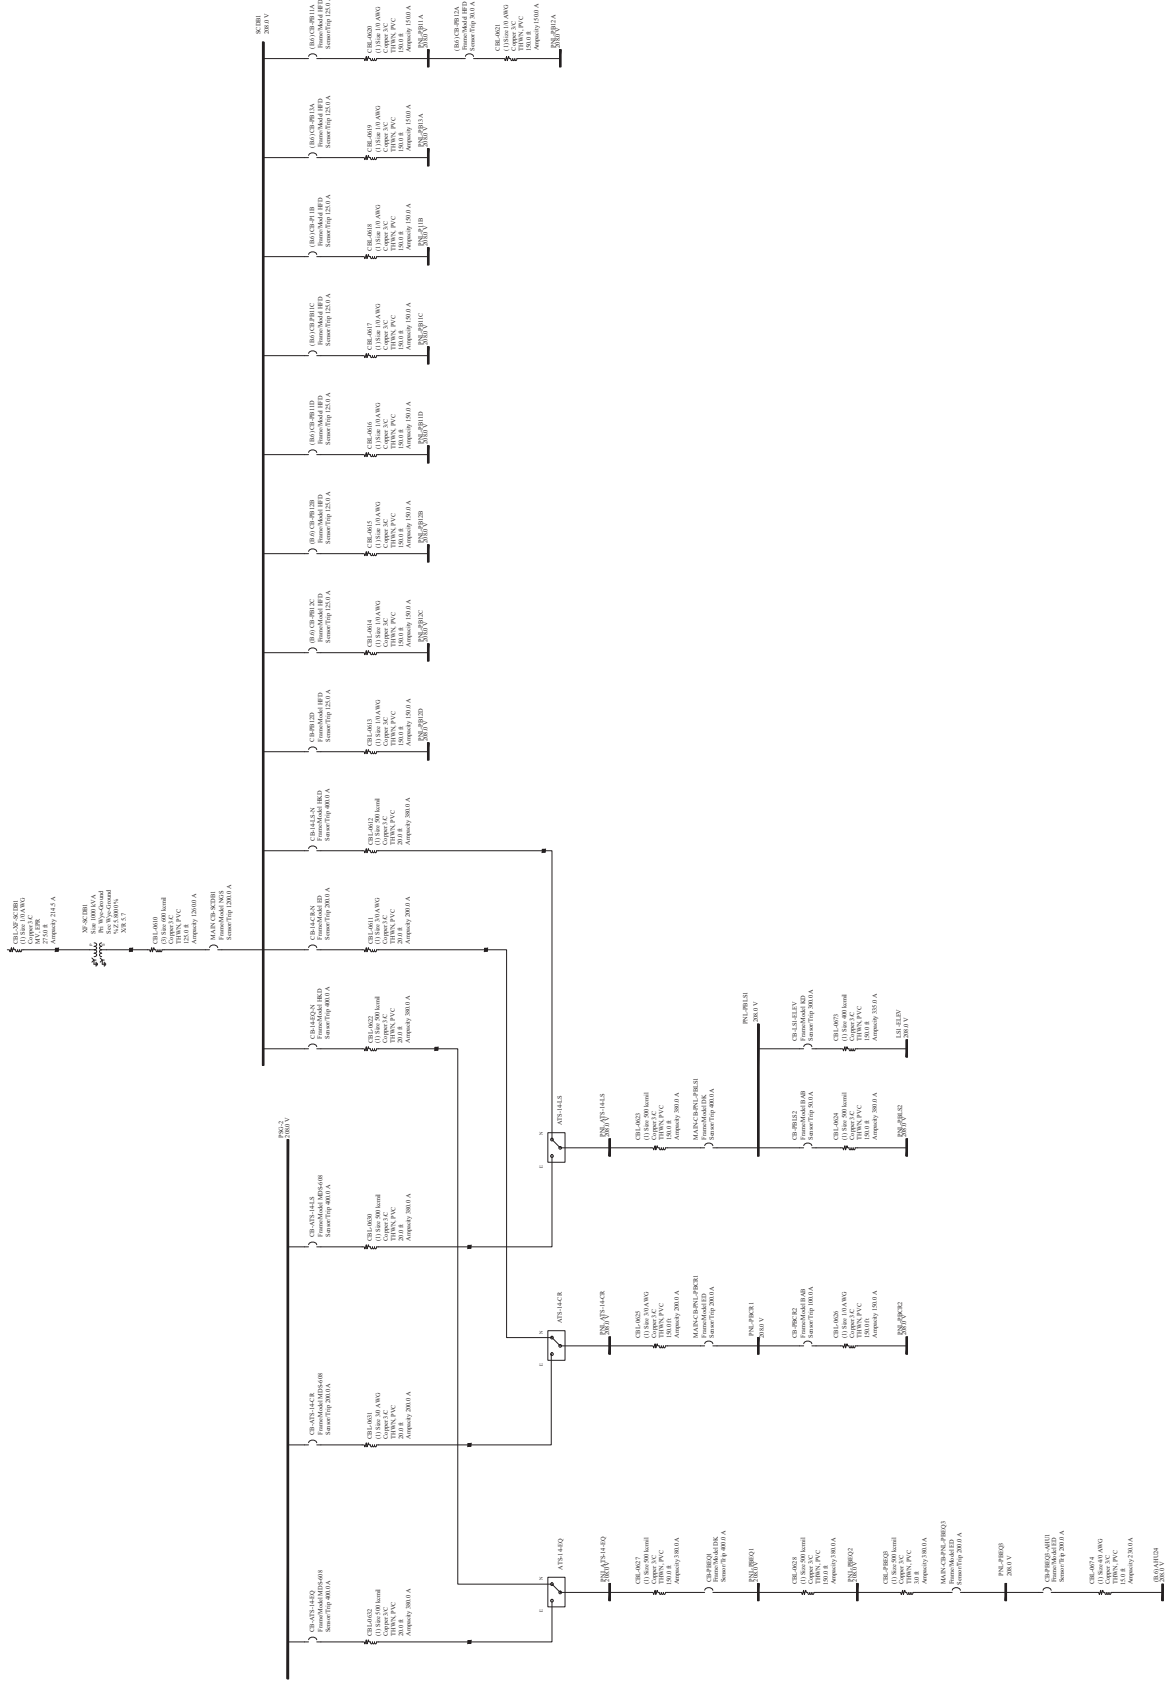

THIS DRAWING, INCLUDING ANY PATENTED OR PATENTABLE FEATURES, EMBODIES CONFIDENTIAL INFORMATION OF THE UNDERTAKING OF THE DRAWING, AND IS A TECHNICAL SERVICE, LCC AND ITS US, CONDITIONED UPON THE USER'S AGREEMENT NOT TO REPRODUCE THE DRAWING IN WHOLE OR IN PART, NOR THE MATERIAL DESCRIBED THEREIN, NOR TO USE THE DRAWING FOR ANY PURPOSE OTHER THAN SPECIFICALLY PERMITTED IN WRITING BY THE UNDERTAKING OF THE DRAWING, LCC AND ITS US, NOR TECHNICAL SERVICE, LLC.



LND TECHNICAL SERVICES, LLC
Address: 9337 Katy Fwy, STE B-51
Houston, TX 77024
+1 858-609-9837

PROFESSIONAL SEALS

Client: Department of Veterans Affairs
Address:
Phone:
Fax:
Email:

Consultant:
Address:

Phone:
Fax:
Email:

STAGES DESIGN		
☒	ISSUED FOR APPROVAL	IFA
☐	ISSUED FOR INFORMATION	IFI
☐	ISSUED FOR BID	IFB
☐	ISSUED FOR CONSTRUCTION	IFC
☐	ISSUED FOR AS-BUILT	IFAB
☐	ISSUED FOR RECORD	IFR

REV	DESCRIPTION	DATE
A	IFA	07/18/2012
B	IFA	09/04/2012
-	-	-
-	-	-
-	-	-

SIERRA NEVADA
HEALTH CARE SYSTEM

Address:


DRAWING TITLE:

SINGLE LINE DIAGRAM
BLDG7-PARKING

SYSTEM:
ELECTRICAL

NAM TRAN	<i>Nam Tran</i>
Design by:	<i>Long Tran</i>
Reviewed:	<i>Tran Manh</i>
Approved:	
DRAWING NUMBER: REV:	

BLDG7-PARKING	B
---------------	---

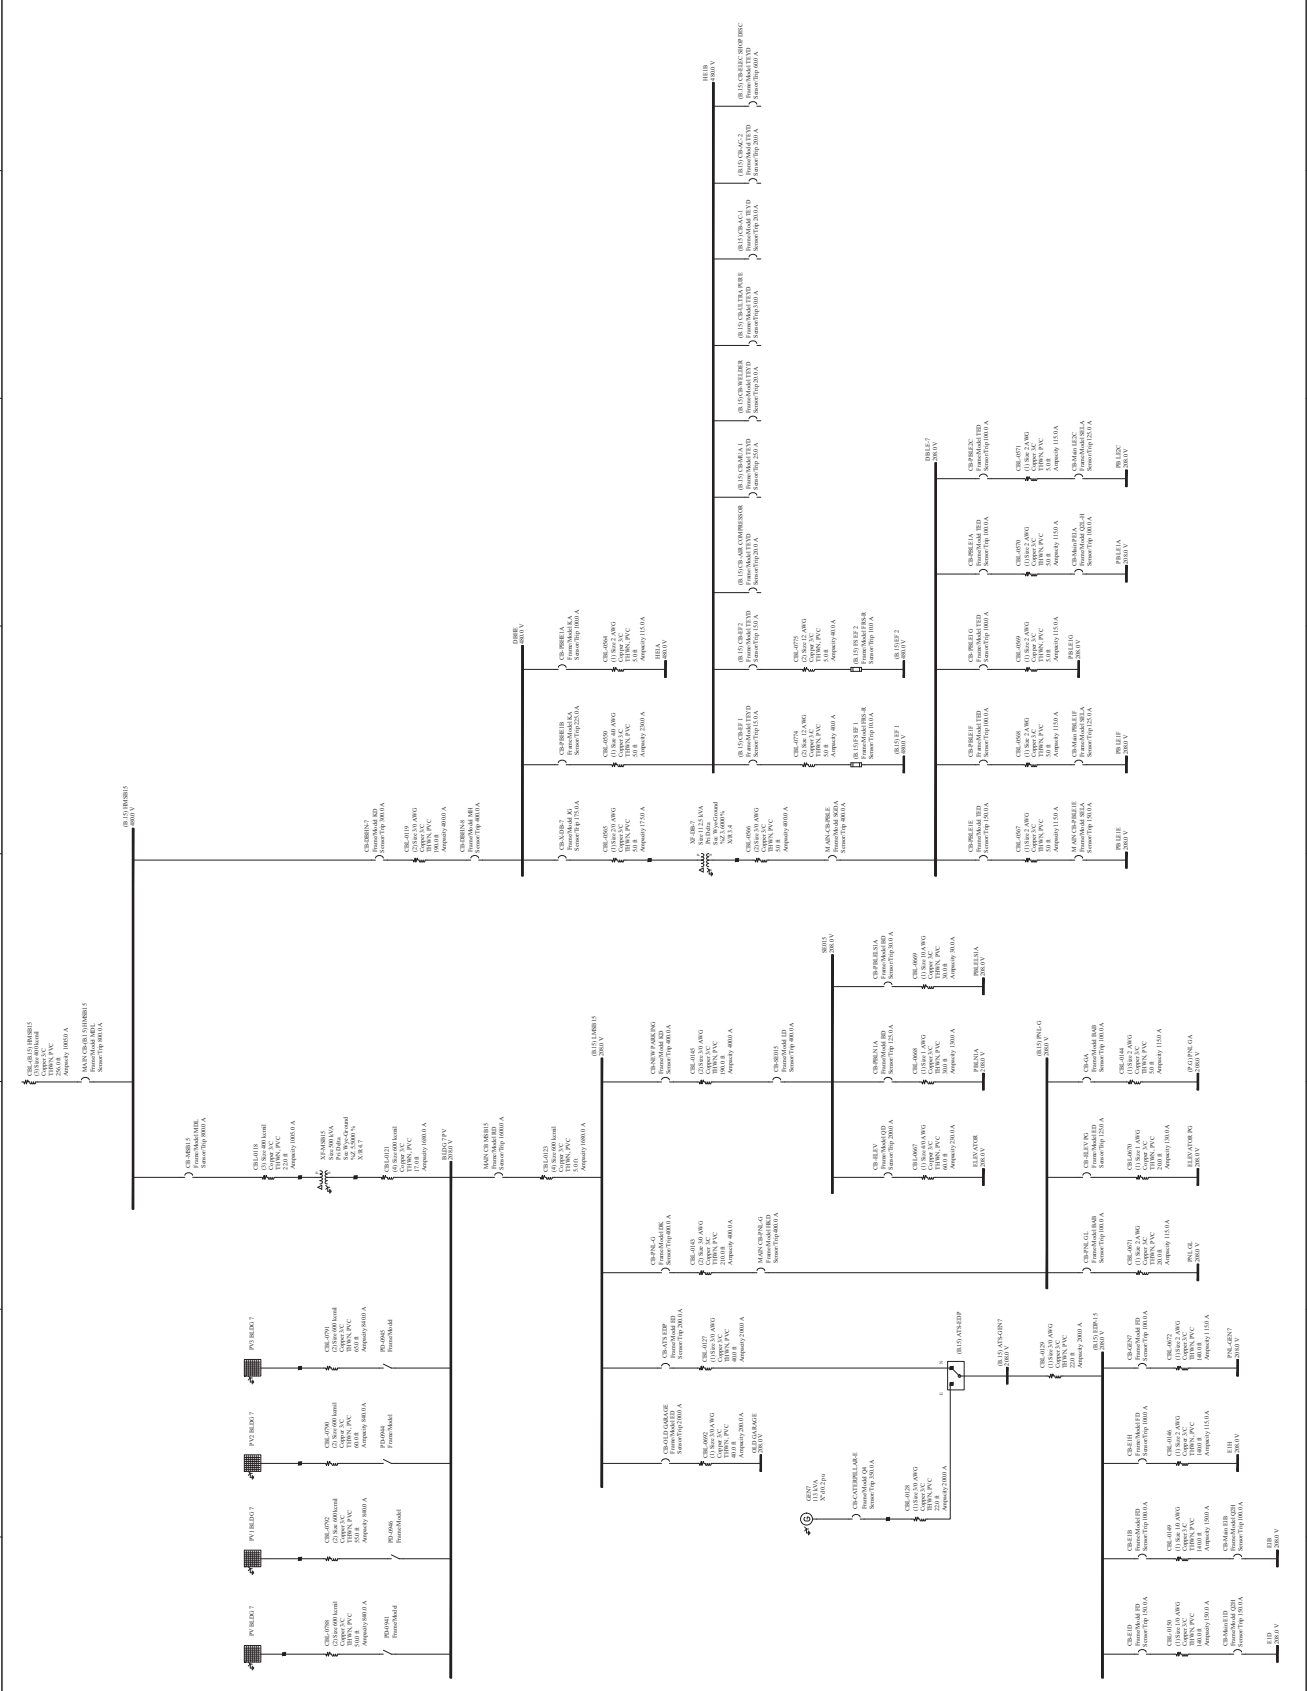

THE DRAWING, INCLUDING ANY PATENTED OR UNPATENTED INFORMATION, IS THE PROPERTY OF LIND TECHNICAL SERVICES, LCC AND ITS USE IS CONDITIONED UPON THE USER'S AGREEMENT NOT TO REPRODUCE, COPIY, OR TRANSMIT IN ANY FORM OR BY ANY MEANS, ELECTRONIC OR MECHANICAL, INCLUDING PHOTOCOPYING, RECORDING, OR BY ANY INFORMATION STORAGE AND RETRIEVAL SYSTEM, WITHOUT THE WRITTEN PERMISSION OF LIND TECHNICAL SERVICES, LCC. NO PART OF THE MATERIAL DESCRIBED HEREON, NOR THE DRAWING FOR ANY PURPOSE OTHER THAN THAT SPECIFICALLY INTENDED IN WRITING BY THE LIND TECHNICAL SERVICE, LCC.



LIND TECHNICAL SERVICES, LCC
Address: 9337 Katy Fwy, STE B-51
Houston, TX 77024
+1 888-699-9837

PROFESSIONAL SEALS

Client: Department of Veterans Affairs
Address:
Phone:
Fax:
Email:

Consultant:
Address:
Phone:
Fax:
Email:

STAGES DESIGN	
ISSUED FOR APPROVAL	IFA
ISSUED FOR INFORMATION	IFI
ISSUED FOR BID	IFB
ISSUED FOR CONSTRUCTION	IFC
ISSUED FOR AS-BUILT	IFAB
ISSUED FOR RECORD	IFR


REV		DESCRIPTION	DATE
A	IFA		07/16/2024
B	IFA		08/04/2024
-	-	-	-
-	-	-	-
-	-	-	-

SIERRA NEVADA
HEALTH CARE SYSTEM

ADDRESS:
DRAWING TITLE
SINGLE LINE DIAGRAM
BLDG8

SYSTEM:	
ELECTRICAL	
Drawn by:	Shane Paine
Design by:	Long Tran
Reviewed by:	Project Manager
Checked by:	
Approved:	

DRAWING NUMBER:	BLDG8
REV:	B

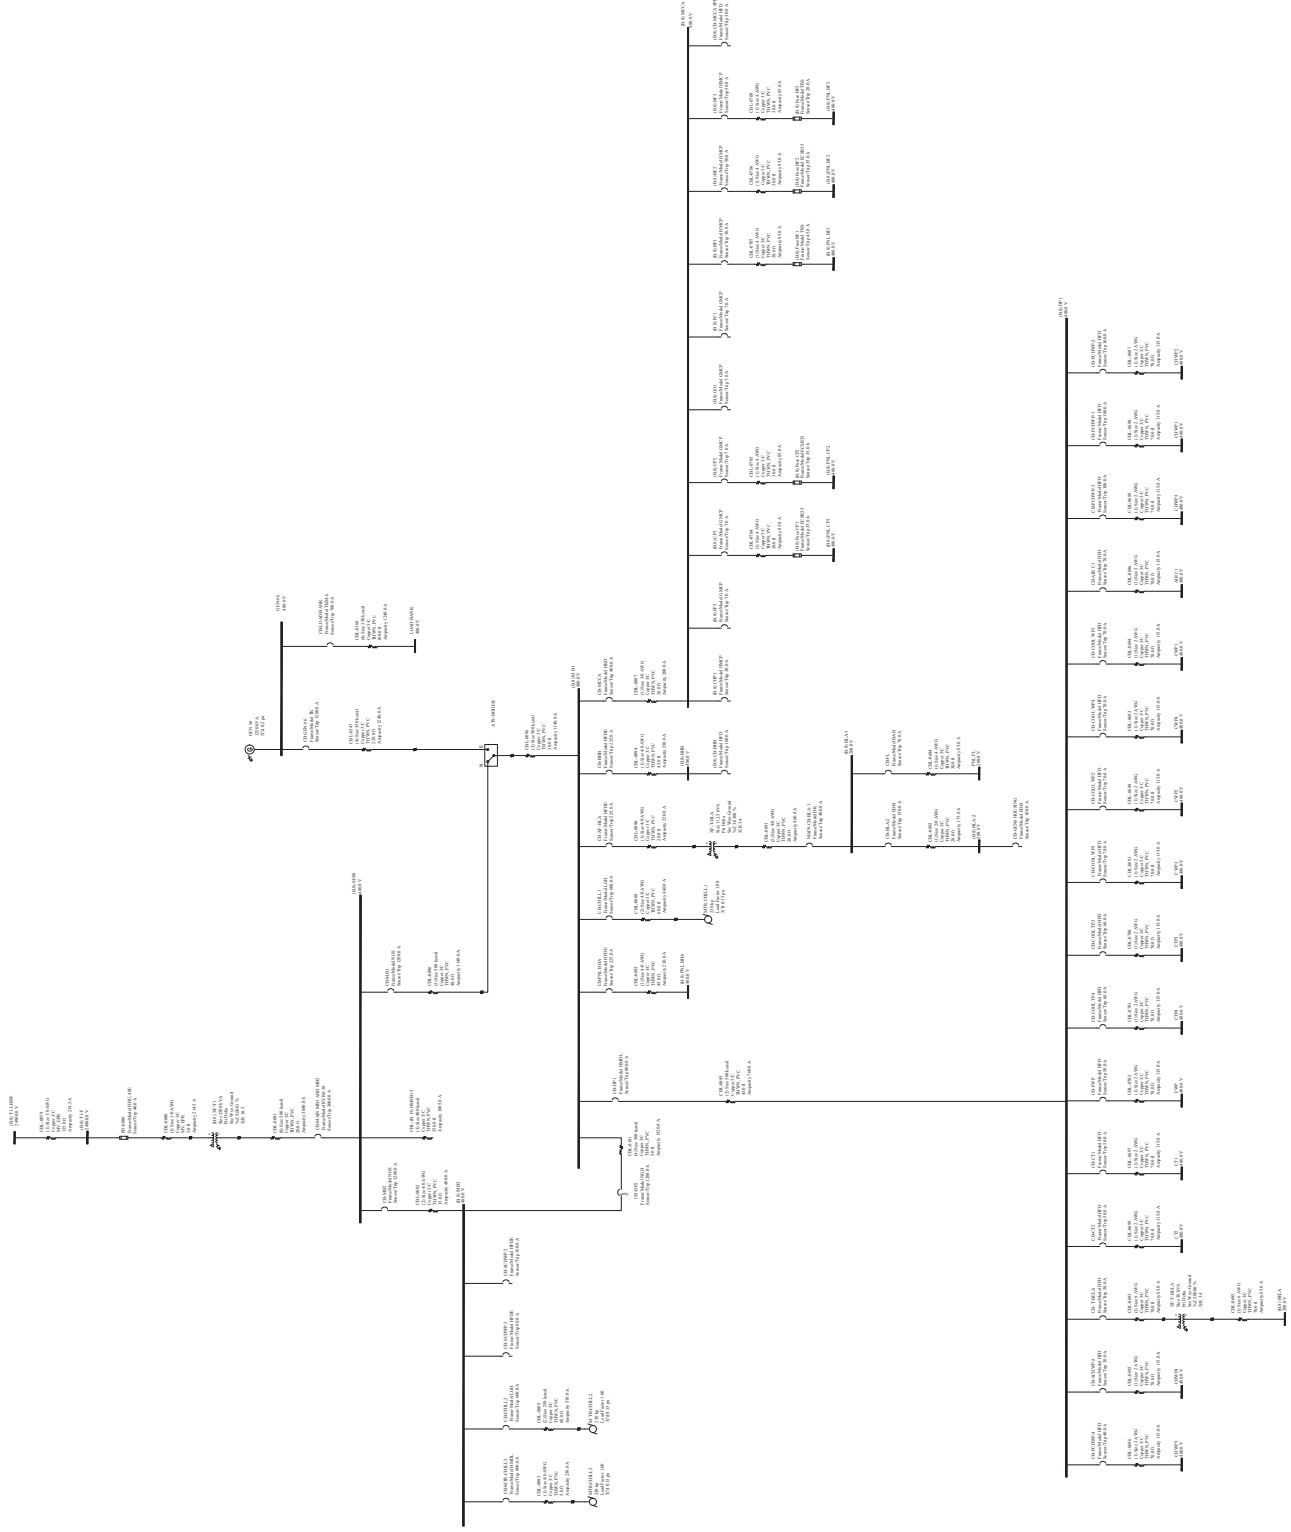

THIS DRAWING IS THE PROPERTY OF LIND TECHNICAL SERVICES, LLC AND IS NOT TO BE REPRODUCED OR TRANSMITTED IN ANY FORM OR BY ANY MEANS, ELECTRONIC OR MECHANICAL, INCLUDING PHOTOCOPYING, RECORDING, OR BY ANY INFORMATION STORAGE AND RETRIEVAL SYSTEM, WITHOUT THE WRITTEN PERMISSION OF LIND TECHNICAL SERVICES, LLC. THE DRAWING INCLUDING ANY PATENTED OR UNPATENTED INVENTIONS OR DISCOVERIES OF LIND TECHNICAL SERVICES, LLC AND ITS USE IS CONDITIONED UPON THE USER'S AGREEMENT NOT TO REPRODUCE OR TRANSMIT IN ANY FORM OR BY ANY MEANS, ELECTRONIC OR MECHANICAL, INCLUDING PHOTOCOPYING, RECORDING, OR BY ANY INFORMATION STORAGE AND RETRIEVAL SYSTEM, WITHOUT THE WRITTEN PERMISSION OF LIND TECHNICAL SERVICES, LLC. NO PART OF THIS DRAWING IS TO BE USED FOR ANY PURPOSE OTHER THAN THAT SPECIFICALLY INTENDED IN WRITING BY THE LIND TECHNICAL SERVICES, LLC.



LIND TECHNICAL SERVICES, LLC
Address: 9337 Katy Fwy, STE B-51
Houston, TX 77024
+1 858-697-9557

PROFESSIONAL SEALS

Client: Department of Veterans Affairs

Address:
Phone:
Fax:
Email:

Consultant:
Address:
Phone:
Fax:
Email:


STAGES DESIGN	
ISSUED FOR APPROVAL	IFA
ISSUED FOR INFORMATION	IFI
ISSUED FOR BID	IFB
ISSUED FOR CONSTRUCTION	IFC
ISSUED FOR AS-BUILT	IFAB
ISSUED FOR RECORD	IFR

REV	DESCRIPTION	DATE
A	IFA	07/18/2024
B	IFA	08/04/2024
-	-	-
-	-	-
-	-	-

SIERRA NEVADA HEALTH CARE SYSTEM

ADJ0861

DRAWING TITLE	
SINGLE LINE DIAGRAM BLDG10	
SYSTEM:	
ELECTRICAL	
DRAWING BY:	Shan Phan
DESIGNED BY:	Long Tran
REVIEWED BY:	Deepak Maragal
APPROVED:	
DRAWING NUMBER:	BLDG10
REV:	B

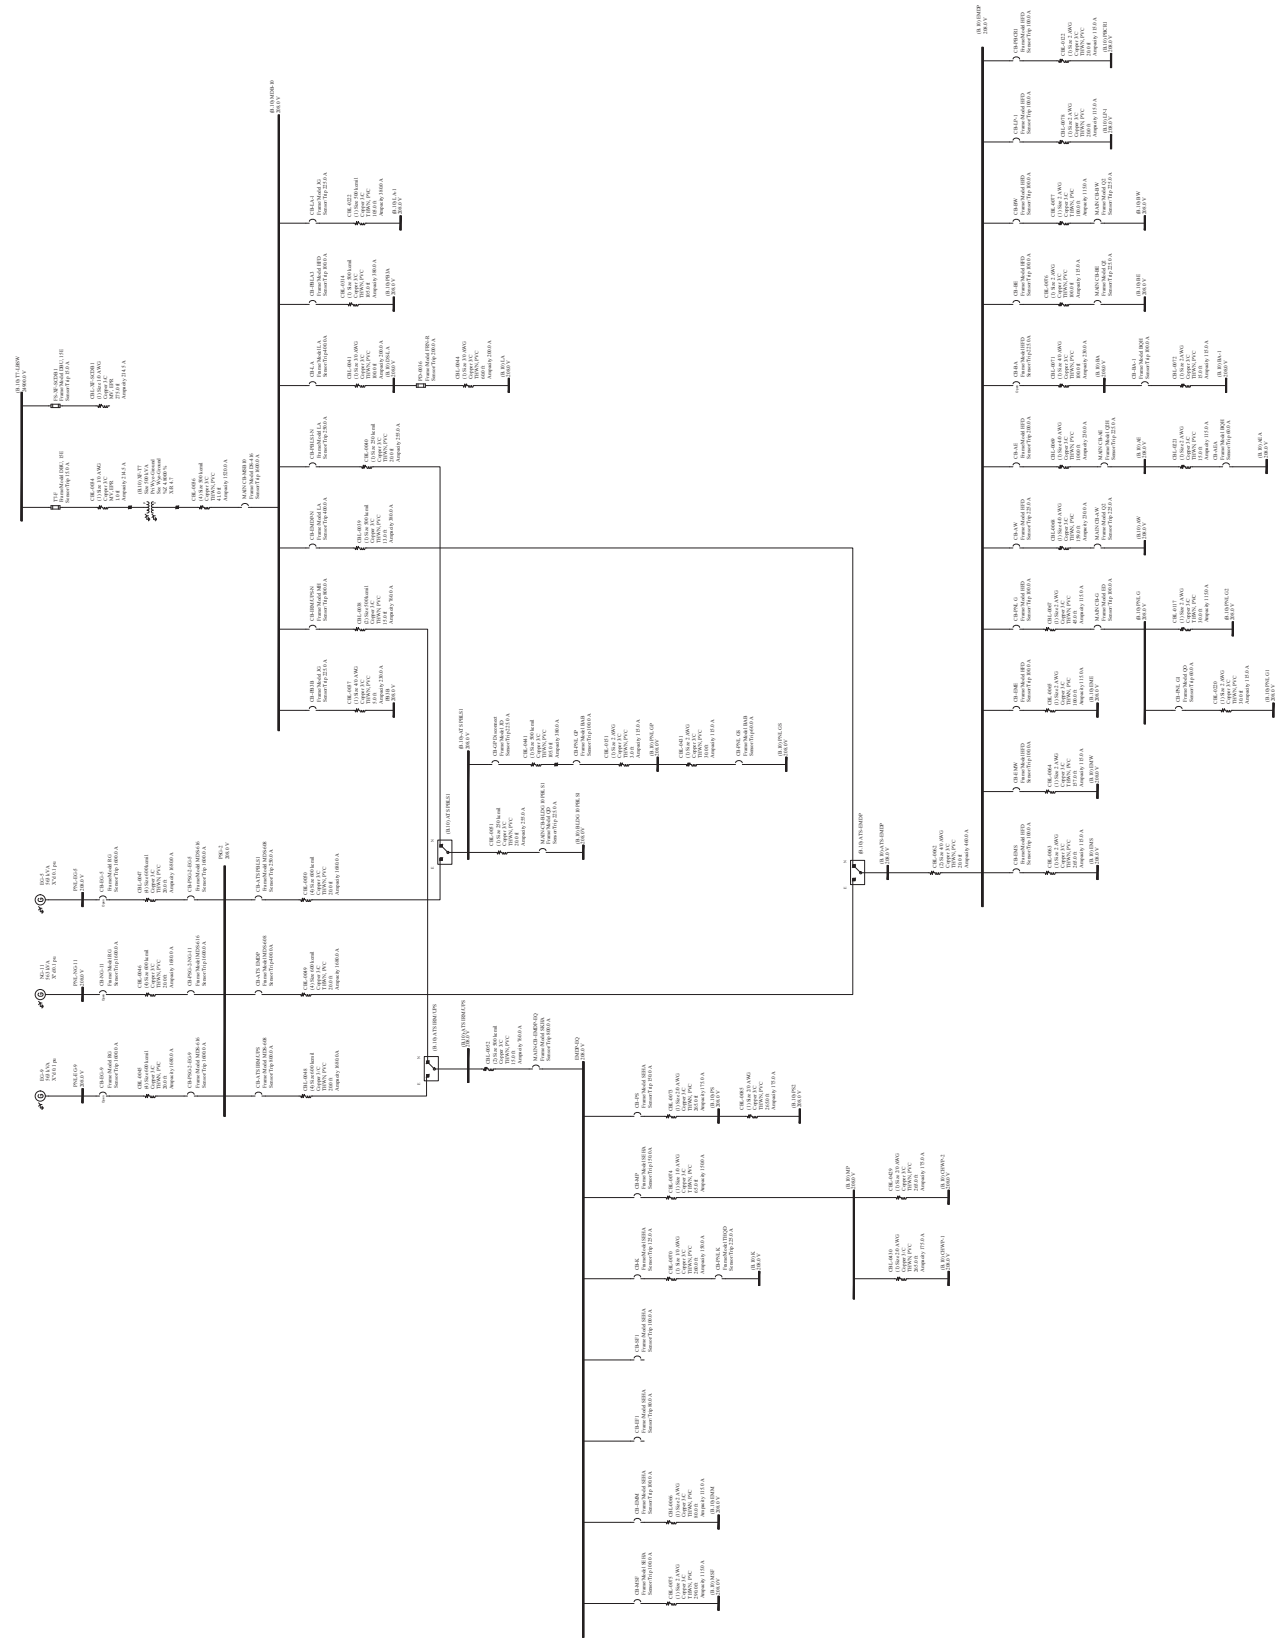

THIS DRAWING, INCLUDING ANY PATENTED OR UNPATENTED DESIGN OR INVENTION, IS THE PROPERTY OF LIND TECHNICAL SERVICES, LLC AND ITS USE IS CONDITIONED UPON THE USER'S AGREEMENT NOT TO REPRODUCE, COPIY, OR TRANSMIT IN ANY PART, NOR THE MATERIAL DESCRIBED THEREON, NOR TO USE THE DRAWING FOR ANY PURPOSE OTHER THAN THAT SPECIFICALLY INTENDED IN WRITING BY THE LIND TECHNICAL SERVICE, LLC.



LIND TECHNICAL SERVICES, LLC
Address: 9337 Katy Fwy, STE B-51
Houston, TX 77024
+1 888-609-9837

PROFESSIONAL SEALS

Client: Department of Veterans Affairs
Address:
Phone:
Fax:
Email:

Consultant:
Address:
Phone:
Fax:
Email:

STAGES DESIGN	
☒ ISSUED FOR APPROVAL	IFA
☐ ISSUED FOR INFORMATION	IFI
☐ ISSUED FOR BID	IFB
☐ ISSUED FOR CONSTRUCTION	IFC
☐ ISSUED FOR AS-BUILT	IFAB
☐ ISSUED FOR RECORD	IFR

REVISIONS	
REV	DESCRIPTION
A	IFA
B	IFA
-	-
-	-
-	-
-	-

SIERRA NEVADA HEALTH CARE SYSTEM

ADDRESS:

DRAWING TITLE
SINGLE LINE DIAGRAM
BLDG 12-1

SYSTEM:	
ELECTRICAL	
Drawing by:	Ham Tran
Design by:	Long Tran
Reviewed by:	DEPAK MARAGAL
Approved:	

DRAWING NUMBER:	REV:
BLDG 12-1	B



THIS DRAWING, INCLUDING ANY PATENTED OR PATENTABLE FEATURES, EMBODIES CONFIDENTIAL INFORMATION OF THE LND TECHNICAL SERVICE, LCC AND ITS USE IS CONDITIONED UPON THE USER'S AGREEMENT NOT TO REPRODUCE THE DRAWING IN WHOLE OR IN PART, NOR THE MATERIAL DESCRIBED THEREON, NOR TO USE THE DRAWING FOR ANY PURPOSE OTHER THAN SPECIFICALLY PERMITTED IN WRITING BY THE LND TECHNICAL SERVICE, LLC.



LND TECHNICAL SERVICES, LLC
Address: 9337 Katy Fwy, STE B-51
Houston, TX 77024
+1 858-609-9837

PROFESSIONAL SEALS

Client: Department of Veterans Affairs

Phone:
Fax:
Email:

Consultant:
Address:

Phone:
Fax:
Email:

STAGES DESIGN		IF A
☒	ISSUED FOR APPROVAL	IF A
☐	ISSUED FOR INFORMATION	IF I
☐	ISSUED FOR BID	IF B
☐	ISSUED FOR CONSTRUCTION	IF C
☐	ISSUED FOR AS-BUILT	IF AB
☐	ISSUED FOR RECORD	IF R

REV	DESCRIPTION	DATE
A	IFA	07/18/2024
B	IFA	09/04/2024
-	-	-
-	-	-
-	-	-

SIERRA NEVADA
EALTH CARE SYSTEM

Address:

DRAWING TITLE:
SINGLE LINE DIAGRAM
BLDG12-2

SYSTEM:
ELECTRIC AL

Drawing by:	NAM TRAN
Design by:	LONG TRAN

Rechecked:
DEEPAK MA

DRAWING NUMBER:	REV:
BLDG12-2	B

